


 





NOTES:

1. PIPING AND SPRINKLER HEAD LOCATIONS ARE FOR ILLUSTRATIVE PURPOSES OF REQUIRED COVERAGE ONLY. THE CONTRACTOR SHALL LOCATE PIPING AND SPRINKLERS AS REQUIRED BY ITS DESIGN, IN COMPLIANCE WITH GENERAL NOTE 6 ON DRAWING NO. FP-002.

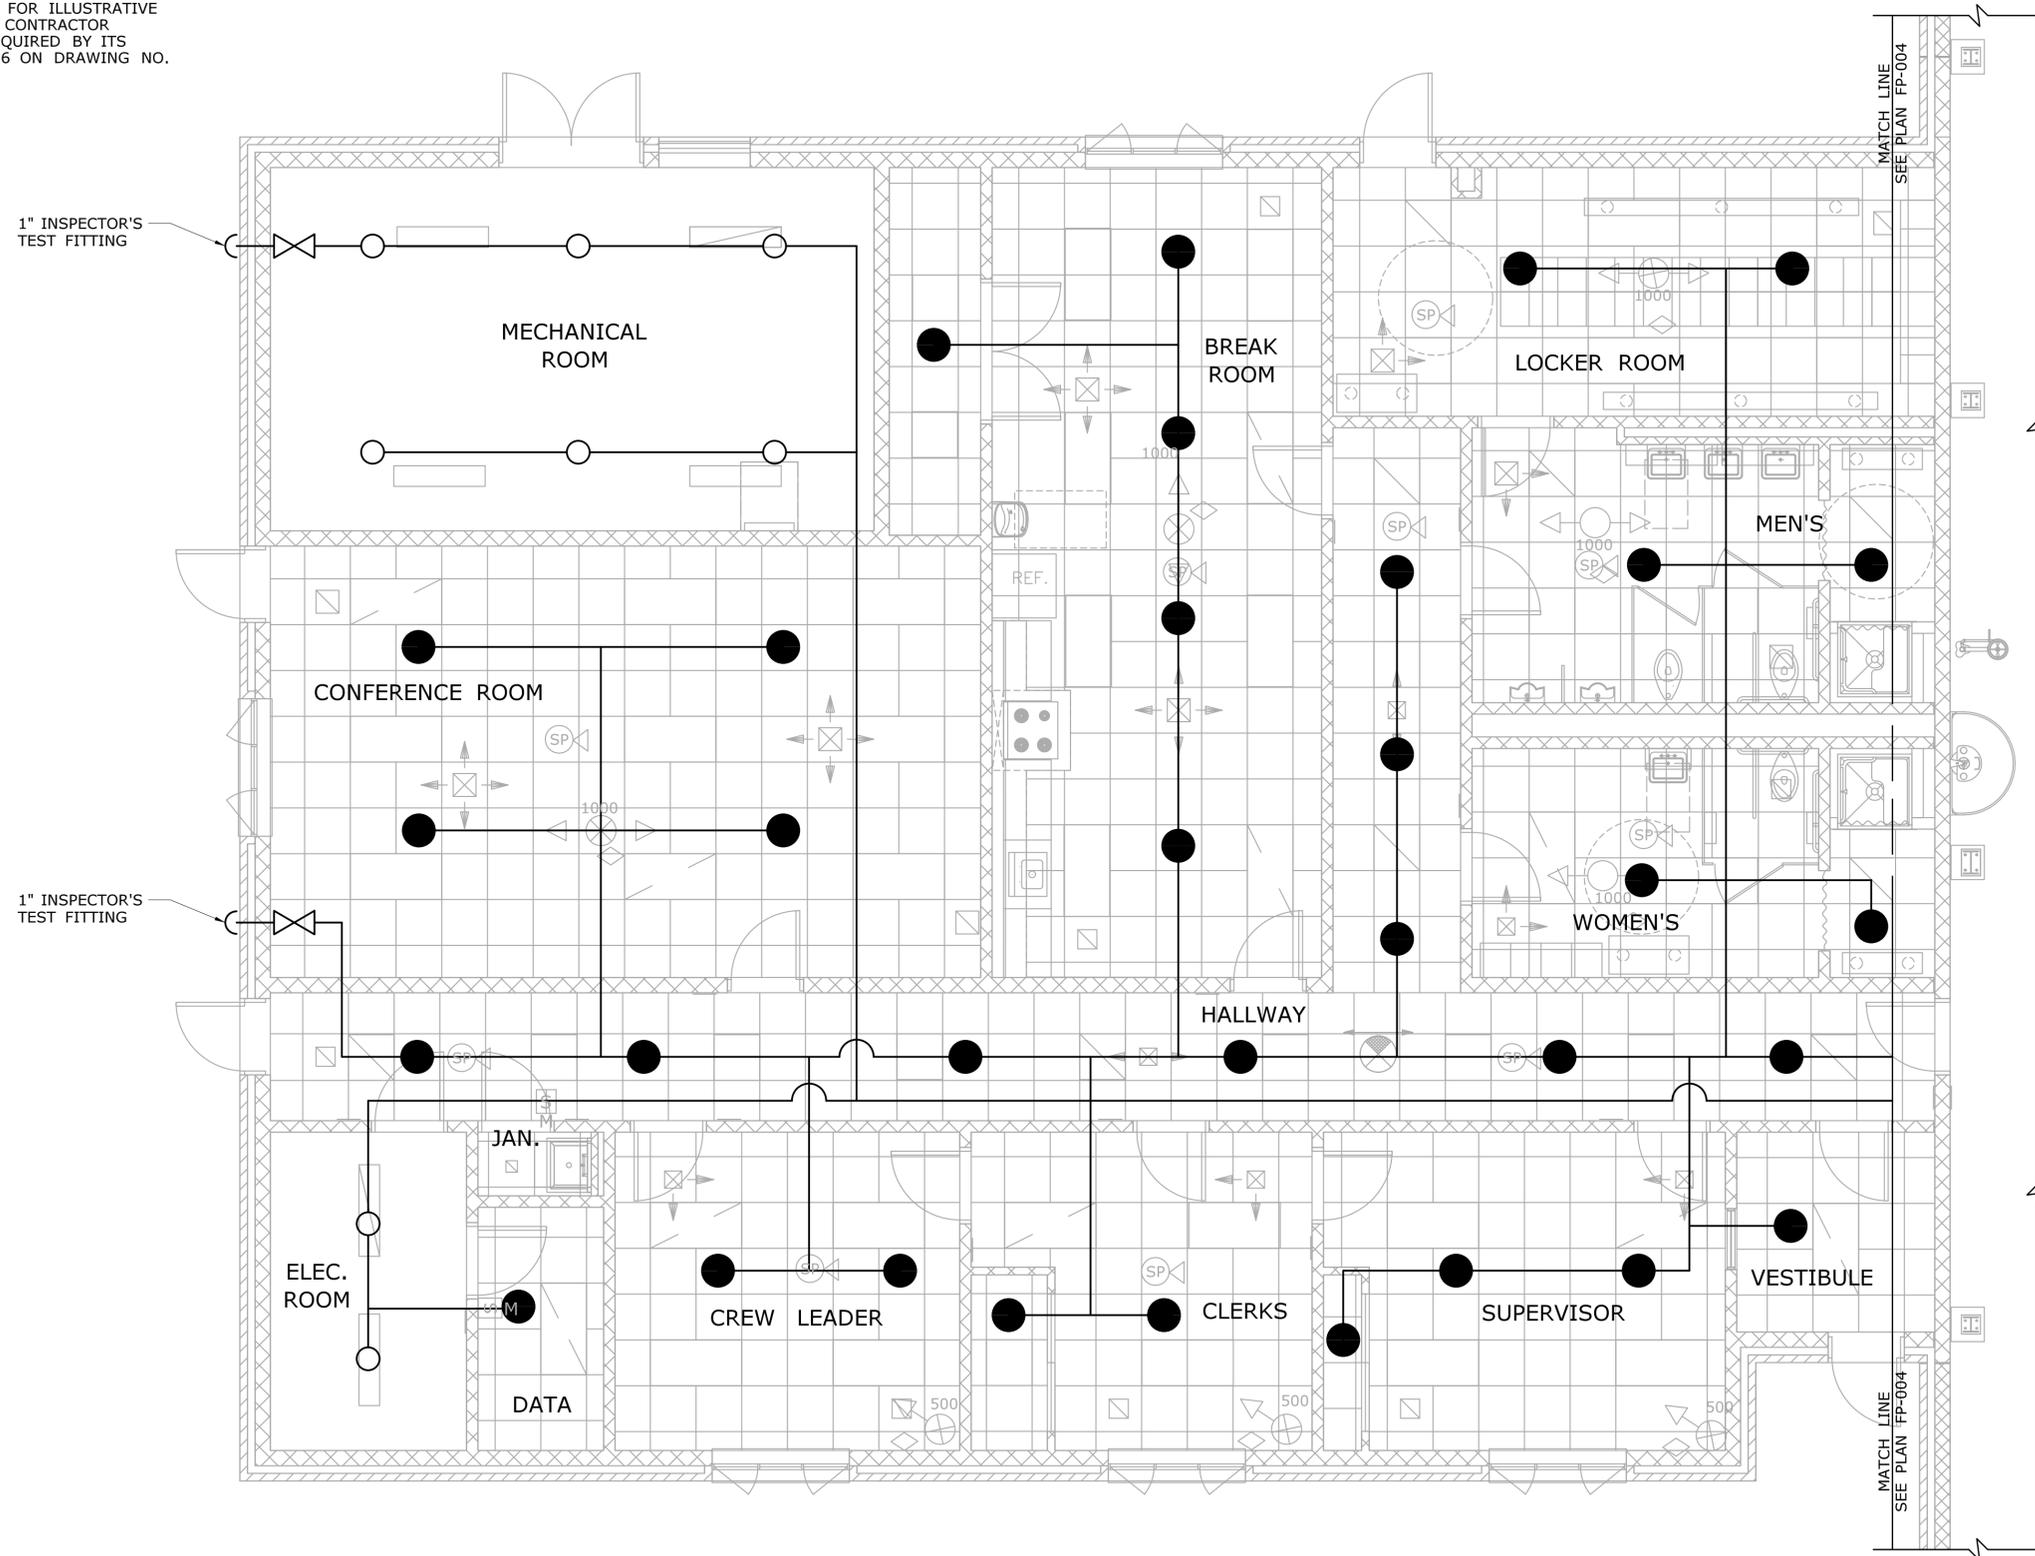


THE INFORMATION, INCLUDING ESTIMATED QUANTITIES OF WORK, SHOWN ON THESE SHEETS IS BASED ON LIMITED INVESTIGATIONS BY THE STATE AND IS IN NO WAY WARRANTED TO INDICATE THE CONDITIONS OF ACTUAL QUANTITIES OF WORK WHICH WILL BE REQUIRED.		DESIGNER/DRAFTER: <b>JAB</b> CHECKED BY: <b>JWW</b> SCALE: 1/4" = 1'-0"	 <b>STATE OF CONNECTICUT</b> <b>DEPARTMENT OF TRANSPORTATION</b> <small>Filename: ...FD_MSH_MEC_0103_0247_FP003.dgn</small>	SIGNATURE/ BLOCK: <b>OFFICE OF ENGINEERING</b> APPROVED BY: 	PROJECT TITLE: <b>OCCUM MAINTENANCE FACILITY</b>	TOWN: <b>OCCUM</b>	PROJECT NO. <b>103-247</b> DRAWING NO. <b>FP-003</b> SHEET NO. <b>07.03</b>
REV.	DATE	REVISION DESCRIPTION	SHEET NO.	Plotted Date: 6/11/2015	DRAWING TITLE: <b>OFFICE AREA FIRE PROTECTION</b>		




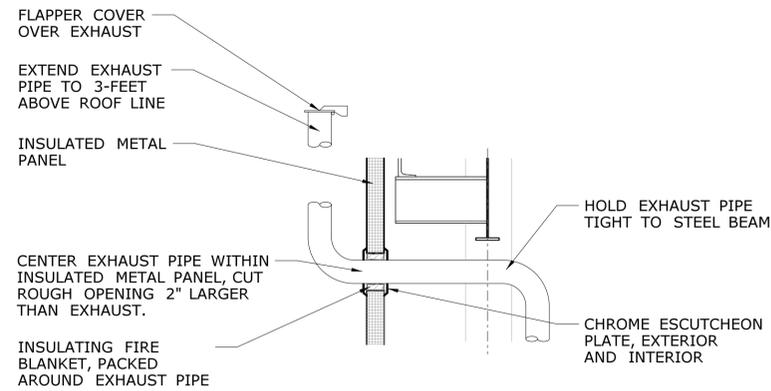

**DIESEL ENGINE EXHAUST THRU INSULATED METAL PANEL**

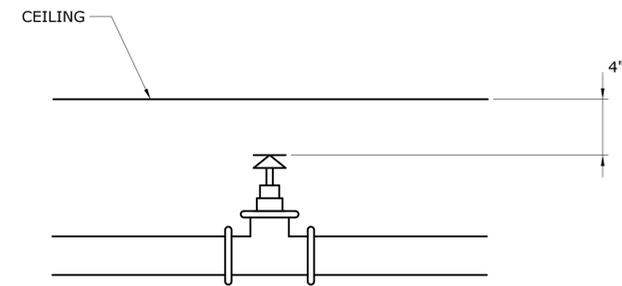


**TYPICAL UPRIGHT SPRINKLER HEAD**

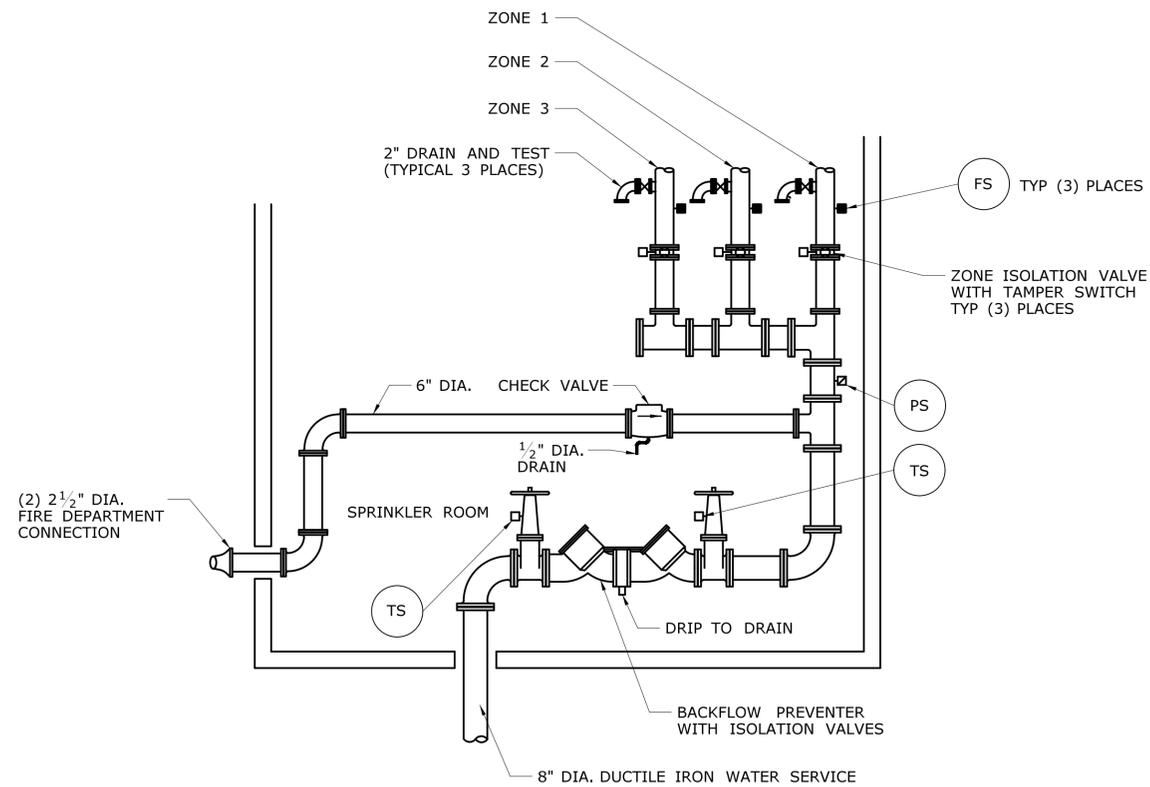

NOTE:  
1. ZONE DIAMETERS SHALL BE AS REQUIRED BY CONTRACTOR HYDRAULIC CALCULATIONS.

**RISER DETAIL**

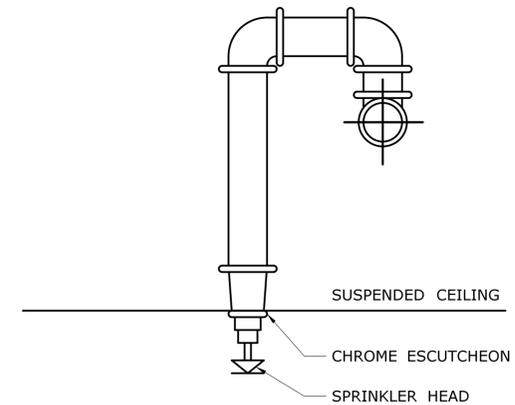

**TYPICAL PENDENT HEAD @ SUSPENDED CEILING**

THE INFORMATION, INCLUDING ESTIMATED QUANTITIES OF WORK, SHOWN ON THESE SHEETS IS BASED ON LIMITED INVESTIGATIONS BY THE STATE AND IS IN NO WAY WARRANTED TO INDICATE THE CONDITIONS OF ACTUAL QUANTITIES OF WORK WHICH WILL BE REQUIRED.		DESIGNER/DRAFTER: <b>JAB</b> CHECKED BY: <b>JWW</b> NOT TO SCALE	<b>STATE OF CONNECTICUT</b> DEPARTMENT OF TRANSPORTATION Filename: ...FD_MSH_MEC.0103_0247_FP005.dgn	SIGNATURE/BLOCK: <b>OFFICE OF ENGINEERING</b> APPROVED BY: <i>Anthony D. P.</i>	PROJECT TITLE: <b>OCCUM MAINTENANCE FACILITY</b>	TOWN: <b>OCCUM</b>	PROJECT NO. <b>103-247</b> DRAWING NO. <b>FP-005</b> SHEET NO. <b>07.05</b>
REV.	DATE	REVISION DESCRIPTION	SHEET NO.	Plotted Date: 6/11/2015	DRAWING TITLE: <b>FIRE PROTECTION DETAILS</b>		