

09 - PLUMBING INDEX OF DRAWINGS

DRAWING NUMBER	DRAWING TITLE	DRAWING NUMBER	DRAWING TITLE
PLM-001	PLUMBING LIST OF DRAWINGS	PLM-301	PLUMBING FLUID & AIR - PART PLAN A
PLM-002	PLUMBING LEGEND	PLM-302	PLUMBING FLUID & AIR - PART PLAN B
PLM-101U	PLUMBING UNDERGROUND - PART PLAN A	PLM-303	PLUMBING FLUID & AIR - PART PLAN C
PLM-102U	PLUMBING UNDERGROUND - PART PLAN B	PLM-304	PLUMBING FLUID & AIR - PART PLAN D
PLM-103U	PLUMBING UNDERGROUND - PART PLAN C	PLM-305	PLUMBING FLUID & AIR - PART PLAN E
PLM-104U	PLUMBING UNDERGROUND - PART PLAN D	PLM-306	PLUMBING FLUID & AIR - PART PLAN F
PLM-105U	PLUMBING UNDERGROUND - PART PLAN E	PLM-307	PLUMBING FLUID & AIR - PART PLAN G
PLM-106U	PLUMBING UNDERGROUND - PART PLAN F	PLM-401	PLUMBING ROOF - PART PLAN A
PLM-107U	PLUMBING UNDERGROUND - PART PLAN G	PLM-402	PLUMBING ROOF - PART PLAN B
PLM-101	PLUMBING DRAINAGE - PART PLAN A	PLM-403	PLUMBING ROOF - PART PLAN C
PLM-102	PLUMBING DRAINAGE - PART PLAN B	PLM-404	PLUMBING ROOF - PART PLAN D
PLM-103	PLUMBING DRAINAGE - PART PLAN C	PLM-405	PLUMBING ROOF - PART PLAN E
PLM-104	PLUMBING DRAINAGE - PART PLAN D	PLM-406	PLUMBING ROOF - PART PLAN F
PLM-105	PLUMBING DRAINAGE - PART PLAN E & PLATFORM	PLM-407	PLUMBING ROOF - PART PLAN G
PLM-106	PLUMBING DRAINAGE - PART PLAN F	PLM-500	PLUMBING RISER DIAGRAM - SANITARY
PLM-107	PLUMBING DRAINAGE - PART PLAN G	PLM-501	PLUMBING RISER DIAGRAM - WATER
PLM-201	PLUMBING WATER DIST. - PART PLAN A	PLM-502	PLUMBING RISER DIAGRAM - RAIN LEADER
PLM-202	PLUMBING WATER DIST. - PART PLAN B	PLM-503	PLUMBING RISER DIAGRAM - SPECIAL WASTE
PLM-203	PLUMBING WATER DIST. - PART PLAN C	PLM-600	PLUMBING DETAILS
PLM-204	PLUMBING WATER DIST. - PART PLAN D	PLM-601	PLUMBING DETAILS
PLM-205	PLUMBING WATER DIST. - PART PLAN E & PLATFORM	PLM-700	PLUMBING SCHEDULES
PLM-206	PLUMBING WATER DIST. - PART PLAN F	PLM-800	PLUMBING PART PLANS
PLM-207	PLUMBING WATER DIST. - PART PLAN G	PLM-801	PLUMBING PART PLANS



<small>THE INFORMATION, INCLUDING ESTIMATED QUANTITIES OF WORK, SHOWN ON THESE SHEETS IS BASED ON LIMITED INVESTIGATIONS BY THE STATE AND IS IN NO WAY WARRANTED TO INDICATE THE CONDITIONS OF ACTUAL QUANTITIES OF WORK WHICH WILL BE REQUIRED.</small>			DESIGNER/DRAFTER RHL CHECKED BY: RSL SCALE NTS	 STATE OF CONNECTICUT DEPARTMENT OF TRANSPORTATION <small>File Name: C:\Users\HMarshall\Documents\ARCH_CT_DOT_Rocky Hill Repair Facility_Central_HMarshall.rvt</small>	SIGNATURE/BLOCK: 	REPAIR FACILITY	TOWN ROCKY HILL	PROJECT NO. 118-0167	
							DRAWING TITLE PLUMBING LIST OF DRAWINGS	DRAWING NO. PLM-001	
								SHEET NO. 09.01	

GENERAL NOTES

1. PIPING AND EQUIPMENT IS SHOWN DIAGRAMMATICALLY. THE ACTUAL ROUTING OF PIPING AND EXACT LOCATION OF EQUIPMENT SHALL BE DETERMINED IN THE FIELD.
2. REVIEW AND COORDINATE WITH THE OTHER TRADES (CIVIL, STRUCTURAL, ARCHITECTURAL, FIRE PROTECTION, HVAC, AND ELECTRICAL).
3. FURNISH AND INSTALL ALL NECESSARY PIPING, EQUIPMENT SUPPORTS AND ANY EQUIPMENT NOT SHOWN ON DRAWINGS OR CALLED FOR IN THE SPECIFICATIONS BUT NECESSARY TO PROVIDE A COMPLETE AND WORKABLE SYSTEM.
4. PROVIDE ACCESSIBLE SHUTOFF VALVES ON ALL BRANCH PIPING AND ON ALL SUPPLY PIPING TO INDIVIDUAL FIXTURES AND EQUIPMENT.
5. PROVIDE ACCESS TO ALL EQUIPMENT REQUIRING PERIODIC SERVICE AND MAINTENANCE.
6. FURNISH ACCESS PANELS TO THE GENERAL CONTRACTOR FOR INSTALLATION UNDER THE RELATED TRADES.
7. PITCH ALL WATER LINES TO DRAIN.
8. INSTALL HORIZONTAL RUNS OF WATER PIPING AS HIGH AS POSSIBLE AND PROVIDE DRAIN-OFFS AT ALL LOW POINTS.
9. HOT WATER TAKEOFFS SHALL HAVE NOT LESS THAN THREE ELBOW SWINGS.
10. PROVIDE DRAIN VALVE ON HOUSE SIDE OF WATER METER.
11. PIPING SHALL RUN CONCEALED IN ALL AREAS WITH THE EXCEPTION OF MECHANICAL ROOMS, AREAS WHERE NO CEILING EXISTS OR WHERE NOTED ON THE PLANS.
12. INSTALL DIELECTRIC COUPLINGS BETWEEN DISSIMILAR MATERIALS.
13. PROVIDE DANDY CLEANOUTS AT THE BASE OF ALL SANITARY AND RAINWATER STACKS.
14. PROVIDE DRIP LEGS FOR ALL GAS RISERS.
15. AN AIR GAP OF AT LEAST TWICE THE EFFECTIVE DIAMETER OF THE DRAIN SERVED SHALL BE PROVIDED ON ALL EQUIPMENT DRAINS PIPED TO FLOOR DRAINS.
16. REQUIRED FIRE RESISTANCE RATING OF FLOORS, WALLS AND CEILINGS SHALL BE MAINTAINED WHEN PIPE PENETRATIONS ARE MADE.
17. REFER TO RISER DIAGRAMS AND DETAILS FOR PIPE AND EQUIPMENT SIZES NOT SHOWN ON THE PLANS.
18. ALL WORK SHOWN ON RISER DIAGRAMS BUT NOT ON PLANS OR VICE VERSA SHALL BE INCLUDED AS IF SHOWN ON BOTH.
19. TRAPS AT ALL TRENCH DRAINS SHALL BE DEEP SEAL.

ABBREVIATIONS

ACT	ACOUSTICAL TILE
AFF	ABOVE FINISH FLOOR
AP	ACCESS PANEL
ARCH	ARCHITECT
BLDG	BUILDING
CFH	CUBIC FEET PER HOUR
CFM	CUBIC FEET PER MINUTE
CI	CAST IRON
CLG	CEILING
CLDI	CEMENT LINED DUCTILE IRON
CO	CLEANOUT
CONC	CONCRETE
CONT	CONTINUATION
CONTR	CONTRACTOR
CP	CHROME PLATED
CW	COLD WATER
DCVA	DOUBLE CHECK VALVE ASSEMBLY
DIA	DIAMETER
DN	DOWN
DWG	DRAWING
EC	ELECTRICAL CONTRACTOR
EL/ELEV	ELEVATION
FCO	FLOOR CLEANOUT
FFE	FINISH FLOOR ELEVATION
P-#	FIXTURE NUMBER
FLR	FLOOR
FP	FIRE PROTECTION
FS	FLOW SWITCH
FT	FOOT
FV	FLUSH VALVE
GALV	GALVANIZED
GC	GENERAL CONTRACTOR
GI	GREASE INTERCEPTOR
GPF	GALLON PER FLUSH
GPM	GALLONS PER MINUTE
HC	HANDICAPPED
HW	HOT WATER
HWR	HOT WATER RETURN
ID	INSIDE DIAMETER
INV	INVERT
IW	INDIRECT WASTE
LPC	LIMIT OF PLUMBING CONTRACTOR
MECH	MECHANICAL
NC	NORMALLY CLOSED
NO	NORMALLY OPEN
NTS	NOT TO SCALE
NIC	NOT IN CONTRACT
OD	OUTSIDE DIAMETER
OED	OPEN END DRAIN
PC	PLUMBING CONTRACTOR
PLBG	PLUMBING
PSI	POUNDS PER SQUARE INCH
RPBP	REDUCED PRESSURE BACKFLOW PREVENTER
SA	SHOCK ABSORBER
SPEC	SPECIFICATION
SS	SOIL STACK
SV	SPECIAL VENT
SVTR	SPECIAL VENT THRU ROOF
SW	SPECIAL WASTE
ST.ST.	STAINLESS STEEL
T	P-TRAP
TW	TEMPERED WATER
TYP	TYPICAL
V	VENT
VB	VACUUM BREAKER
VS	VENT STACK
VTR	VENT THRU ROOF
W	WASTE

GENERAL

	FD	FLOOR DRAIN
	RD	ROOF DRAIN
	TD	TRENCH DRAIN
	AD	AREA DRAIN
	CO	CLEANOUT
	FCO	FLOOR CLEANOUT
	GCO	GRADE CLEANOUT
		P-TRAP
		ELBOW UP OR RISE
		ELBOW DOWN OR DROP
		CAP OR END OF PIPE
	HB	HOSE BIBB
	WH	WALL HYDRANT
	CA	COMPRESSED AIR STATION SEE DETAIL 06 ON PLM-600
		TEE LOOKING UP
		TEE LOOKING DOWN
		UNION
	VIV	VALVE IN VERTICAL
	RPBP	REDUCED PRESSURE ZONE BACKFLOW PREVENTER
		STRAINER
	WHA/SA	WATER HAMMER ARRESTOR/SHOCK ABSORBER
		FLOW IN DIRECTION OF ARROW
		DIRECTION OF SLOPE
	CNR	CONCENTRIC REDUCER
		PIPE SLEEVE
	ECC	ECCENTRIC REDUCER
		DOUBLE WALL PIPING
		PIPE ANCHOR
		PIPE GUIDE
		EXPANSION JOINT
		FLEXIBLE CONNECTOR
		IN-LINE FILTER
		FLOW METER
		LIMIT OF WORK
	HC	HANDICAPPED ACCESSIBLE
	NUM	KEY NOTE DESIGNATION
	TP	TRAP PRIMER

PIPING LEGEND

	CW	COLD WATER
		COLD WATER BELOW SLAB
	HW	HOT WATER
		HOT WATER BELOW SLAB
	HWR	HOT WATER RETURN
		HOT WATER RETURN BELOW SLAB
	FW	FILTERED COLD WATER
	S or W	SOIL OR WASTE ABOVE GROUND
	S or W	SOIL OR WASTE BELOW SLAB
	V	VENT ABOVE GROUND
	V	VENT BELOW SLAB
	SW	SPECIAL WASTE ABOVE GROUND
	SW	SPECIAL WASTE BELOW SLAB
	SV	SPECIAL VENT ABOVE GROUND
	SV	SPECIAL VENT BELOW SLAB
	RL	RAIN LEADER ABOVE GROUND
	RL	RAIN LEADER BELOW SLAB
	IW	INDIRECT WASTE
	G	NATURAL GAS PIPING
	GV	GAS VENT PIPING
	TW	TEMPERED WATER
	A,CA	COMPRESSED AIR
	NPCW	NON POTABLE COLD WATER
	NPHW	NON POTABLE HOT WATER
	TP	TRAP PRIMER


VALVE LEGEND

		BALL VALVE
		BALL VALVE (NORMALLY CLOSED)
		GATE VALVE
		GATE VALVE (NORMALLY CLOSED)
	OS&Y	OUTSIDE SCREW AND YOKE VALVE
		BUTTERFLY VALVE
		CHECK VALVE
		BALL VALVE (GAS)
		GAS COCK
		PLUG VALVE
	MV	MIXING VALVE
		BALANCING VALVE
		ANGLE VALVE
	T&P	TEMPERATURE AND PRESSURE RELIEF VALVE
		VACUUM RELIEF VALVE
		AQUASTAT
		THERMOMETER
	PRV	PRESSURE REDUCING/REGULATING VALVE
	PG	PRESSURE GAUGE
		BACK WATER VALVE
		GLOBE VALVE
		FLOW SWITCH
		SOLENOID VALVE
		NEEDLE VALVE
		MOTOR OPERATED GATE VALVE
		MOTOR OPERATED BALL VALVE

DESIGNATION INDICATOR

	1	DETAIL DESIGNATION NUMBER
	P-1	DETAIL DESIGNATION DRAWING
	F 1	RISER SERVICE DESIGNATION
	1	RISER NUMBER DESIGNATION
	P-1	RISER DESIGNATION DRAWING
	A	SECTION DESIGNATION LETTER
	P-1	SECTION DESIGNATION DRAWING


NO.	Revision Description	Date	Plotted: 10/21/2014 3:40:59 PM	DESIGNER/DRAFTER RHL	<p>STATE OF CONNECTICUT DEPARTMENT OF TRANSPORTATION</p> <p>File Name: MPPP_CTDOT_Rocky Hill Repair Facility_Central.rvt</p>	SIGNATURE/BLOCK: 	PROJECT TITLE REPAIR FACILITY	TOWN ROCKY HILL	PROJECT NO. 118-0167
				CHECKED BY: RSL		SCALE NONE	DRAWING TITLE PLUMBING LEGEND	DRAWING NO. PLM-002	
								SHEET NO. 09.02	

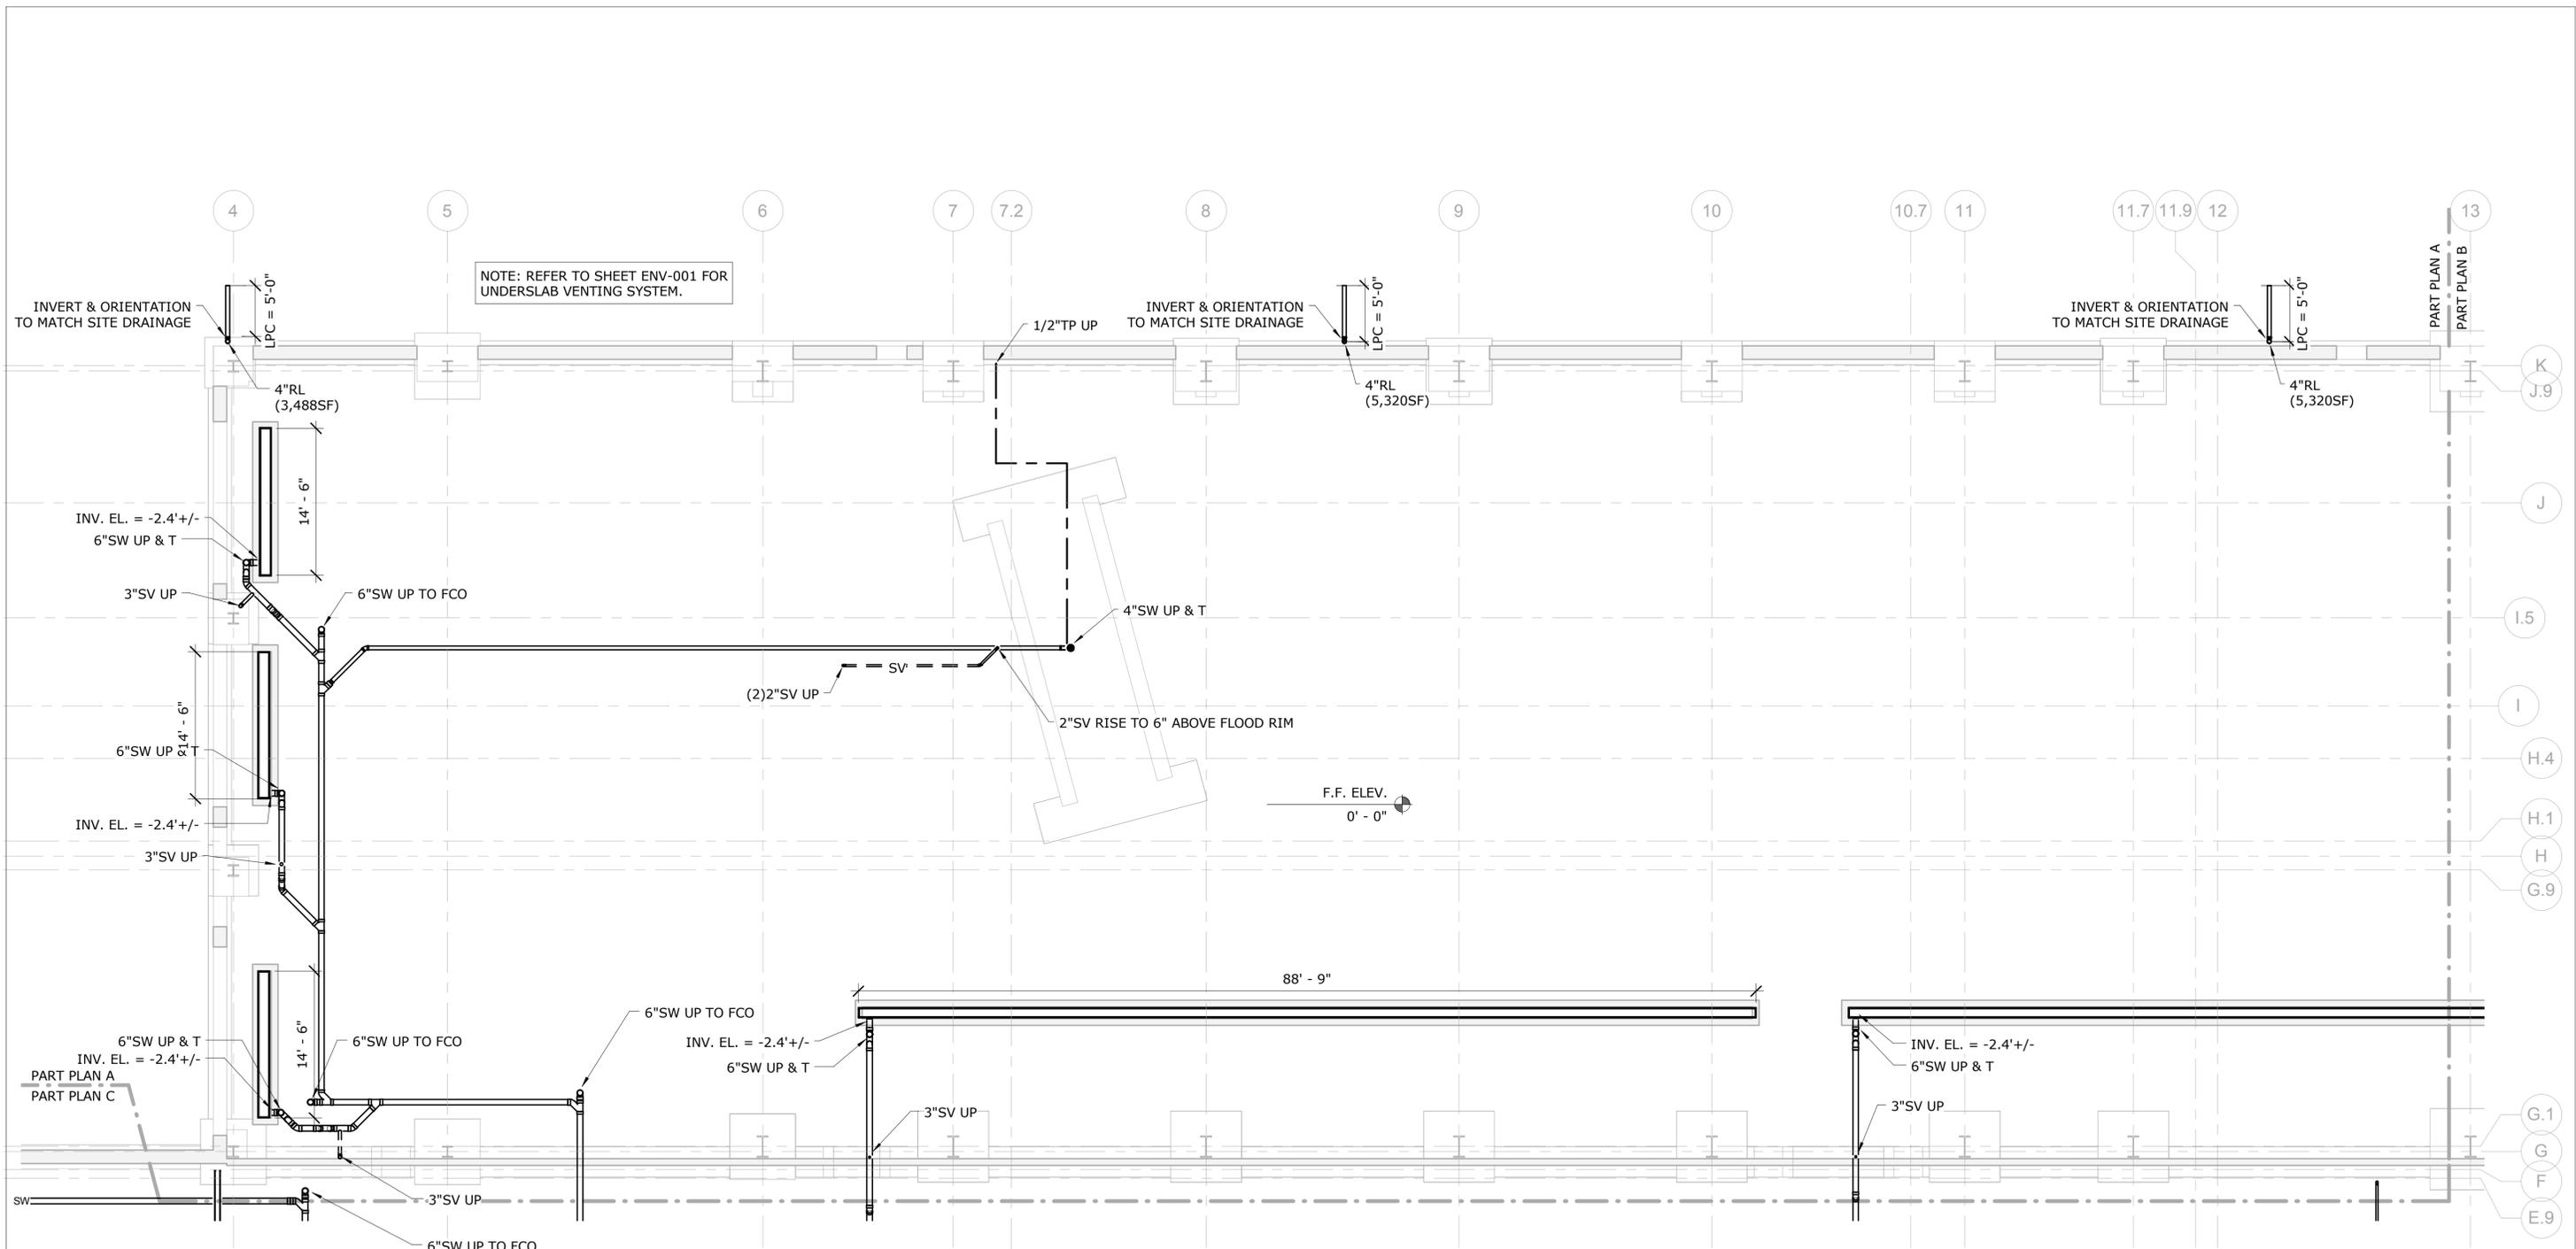

1 PLUMBING - FOUNDATION - PART PLAN A - NORTH REPAIR BAYS
SCALE: 1/8" = 1'-0"

PARTIAL PLAN LEGEND:

- A - NORTH REPAIR BAYS
- B - SOUTH REPAIR BAYS
- C - LUBE AND WASH BAYS
- D - STORES
- E - OFFICE AREA
- F - MACHINE SHOP
- G - PAINT AREA

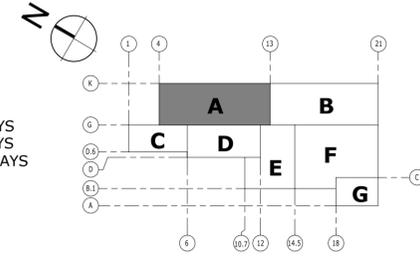

KEY PLAN

NO.	Revision Description	Date

THE INFORMATION, INCLUDING ESTIMATED QUANTITIES OF WORK, SHOWN ON THESE SHEETS IS BASED ON LIMITED INVESTIGATIONS BY THE STATE AND IS IN NO WAY WARRANTED TO INDICATE THE CONDITIONS OF ACTUAL QUANTITIES OF WORK WHICH WILL BE REQUIRED.

DESIGNER/DRAFTER
RHL
CHECKED BY:
RSL
SCALE
1/8" = 1'-0"



SIGNATURE/BLOCK:
[Signature]


PROJECT TITLE
REPAIR FACILITY

TOWN
ROCKY HILL
DRAWING TITLE
PLUMBING UNDERGROUND - PART PLAN A

PROJECT NO.
118-0167
DRAWING NO.
PLM-101U
SHEET NO.
09.03

Plotted: 10/21/2014 3:41:08 PM

File Name: MPPP_CTDOT_Rocky Hill Repair Facility_Central.rvt

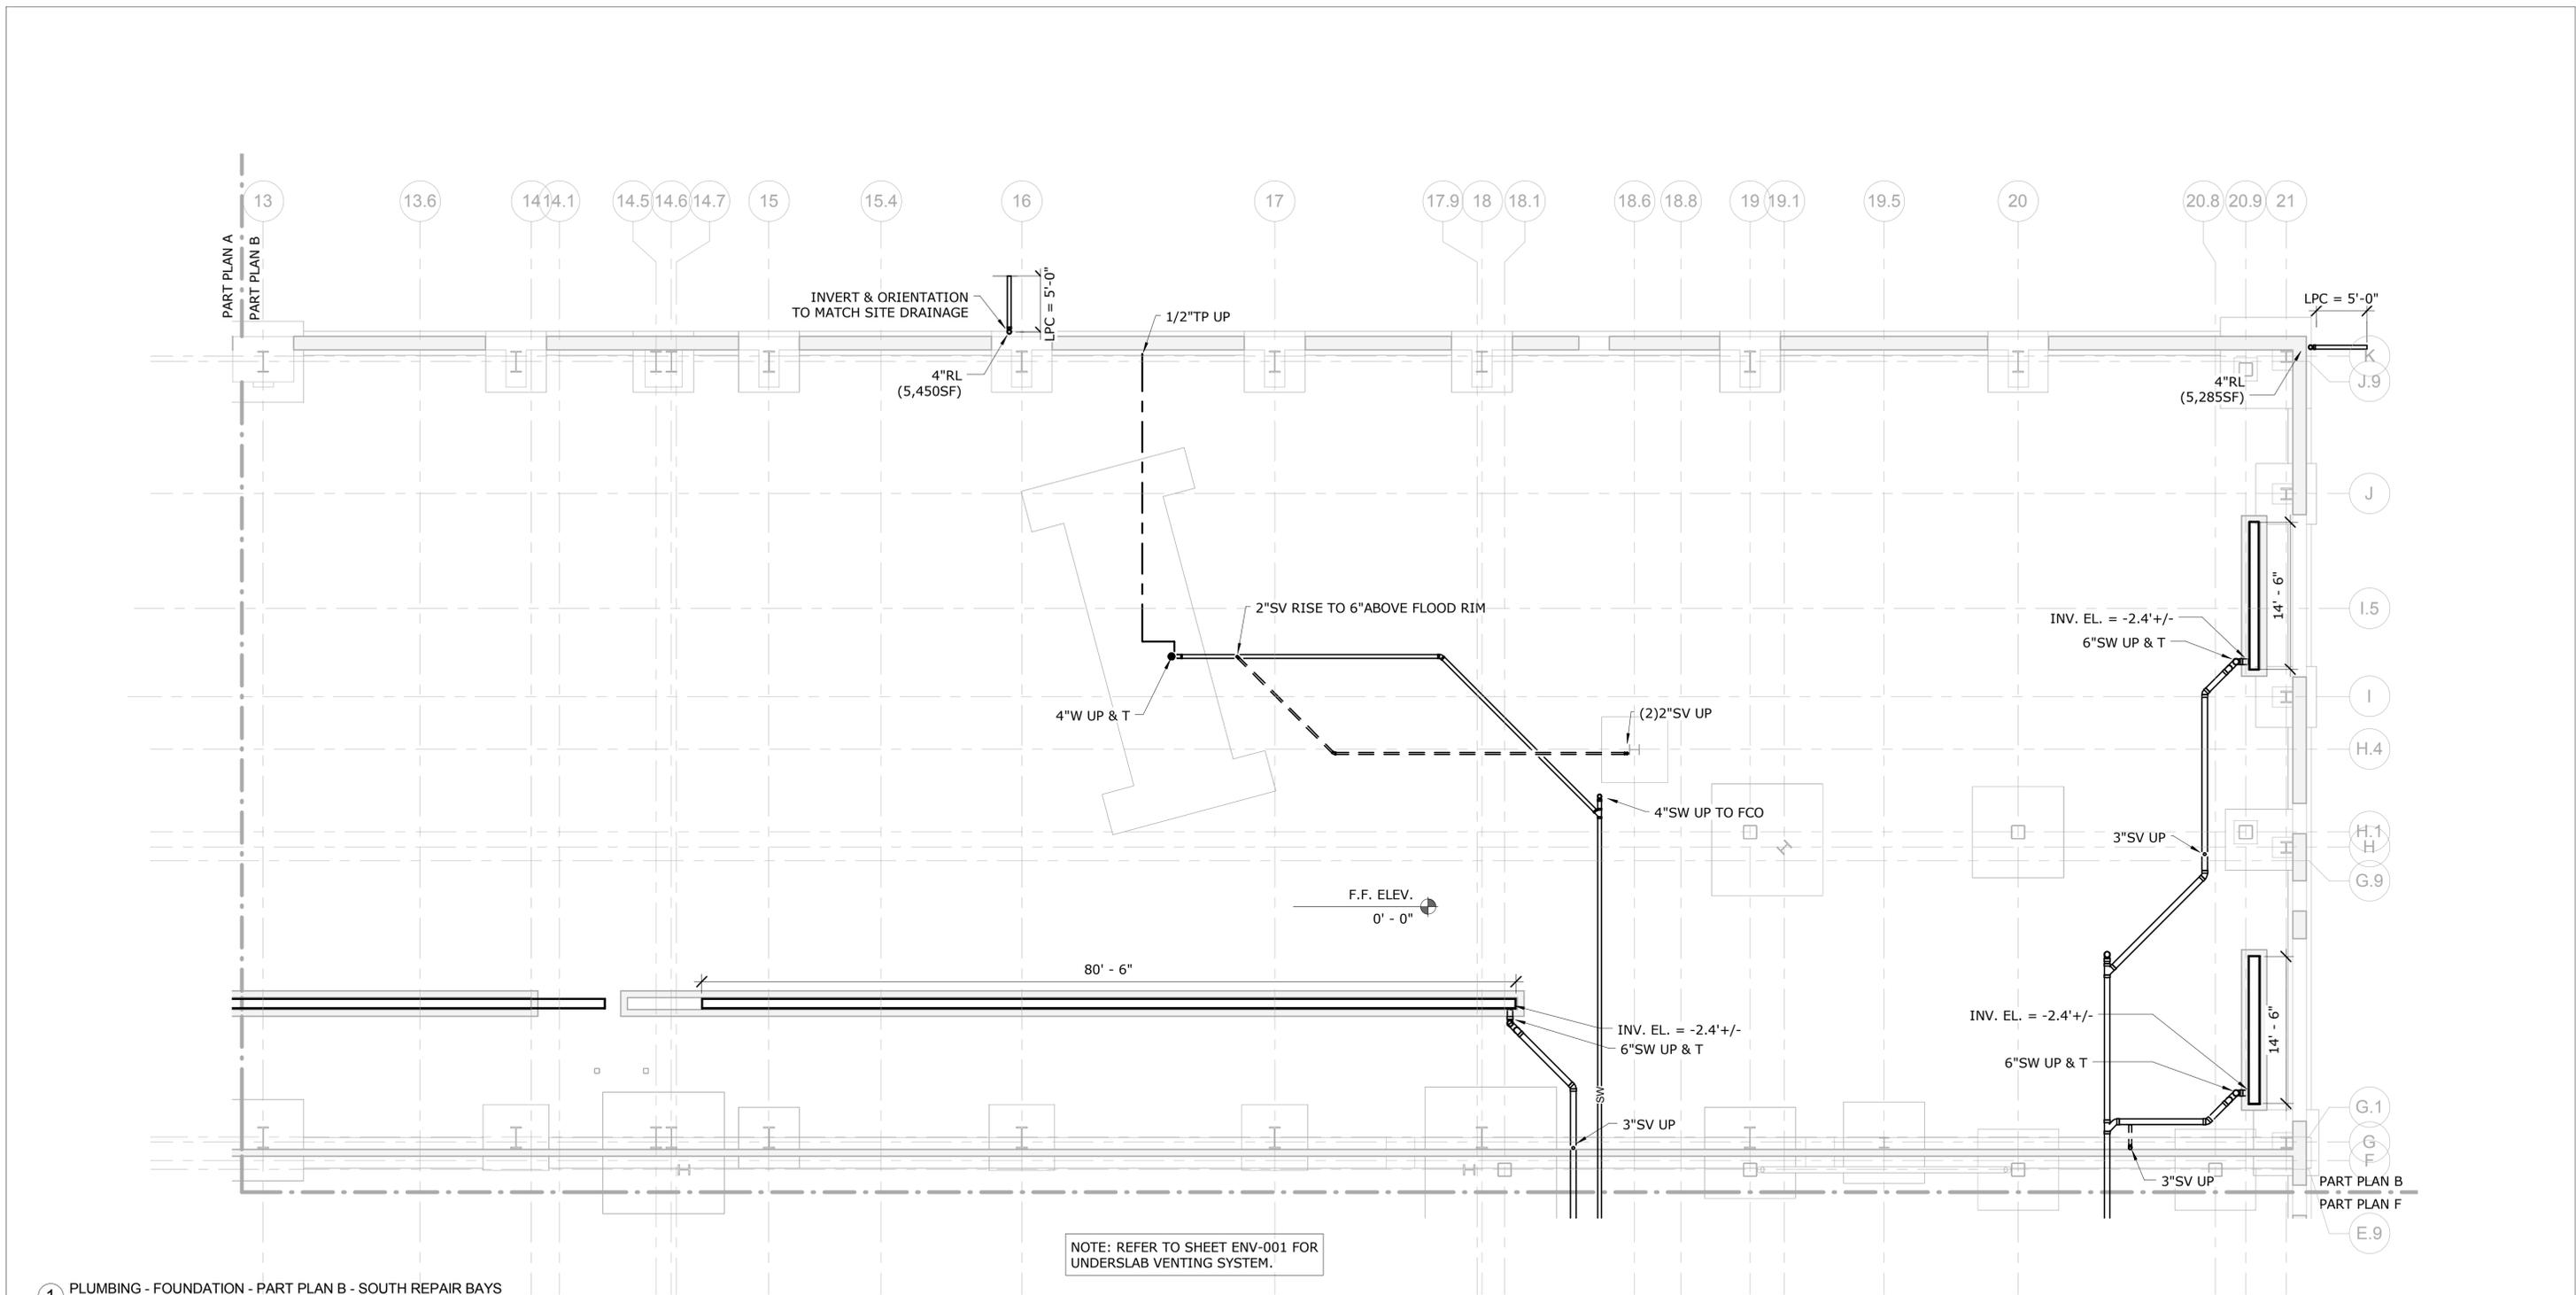


1 PLUMBING - FOUNDATION - PART PLAN B - SOUTH REPAIR BAYS
SCALE: 1/8" = 1'-0"

NOTE: REFER TO SHEET ENV-001 FOR UNDERSLAB VENTING SYSTEM.

PARTIAL PLAN LEGEND:

- A - NORTH REPAIR BAYS
- B - SOUTH REPAIR BAYS
- C - LUBE AND WASH BAYS
- D - STORES
- E - OFFICE AREA
- F - MACHINE SHOP
- G - PAINT AREA

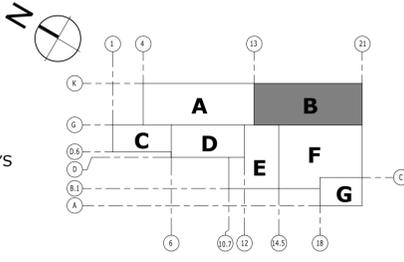

NO.	Revision Description	Date

THE INFORMATION, INCLUDING ESTIMATED QUANTITIES OF WORK, SHOWN ON THESE SHEETS IS BASED ON LIMITED INVESTIGATIONS BY THE STATE AND IS IN NO WAY WARRANTED TO INDICATE THE CONDITIONS OF ACTUAL QUANTITIES OF WORK WHICH WILL BE REQUIRED.

Plotted: 10/21/2014 3:41:15 PM

DESIGNER/DRAFTER
RHL

CHECKED BY:
RSL

SCALE
1/8" = 1'-0"



SIGNATURE/BLOCK:

PROJECT TITLE
REPAIR FACILITY


TOWN
ROCKY HILL

DRAWING TITLE
PLUMBING UNDERGROUND - PART PLAN B

PROJECT NO.
118-0167

DRAWING NO.
PLM-102U


SHEET NO.
09.04

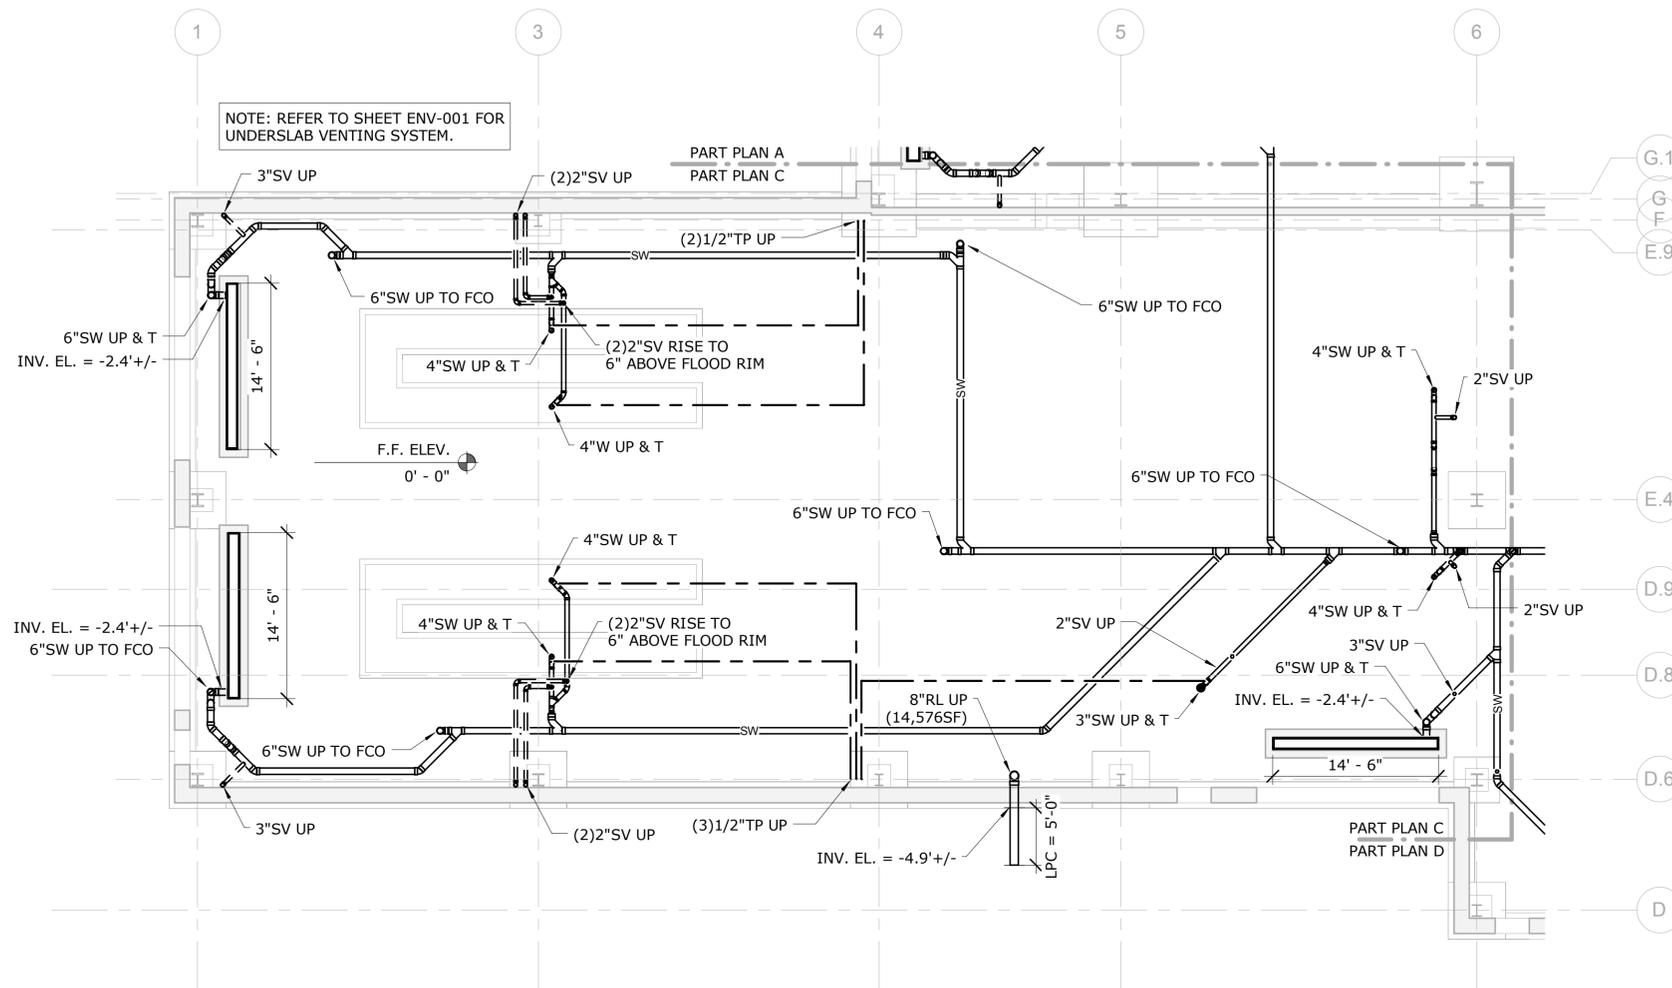

1 PLUMBING - FOUNDATION - PART PLAN C - LUBE & WASH BAYS
SCALE: 1/8" = 1'-0"

PARTIAL PLAN LEGEND:

- A - NORTH REPAIR BAYS
- B - SOUTH REPAIR BAYS
- C - LUBE AND WASH BAYS
- D - STORES
- E - OFFICE AREA
- F - MACHINE SHOP
- G - PAINT AREA

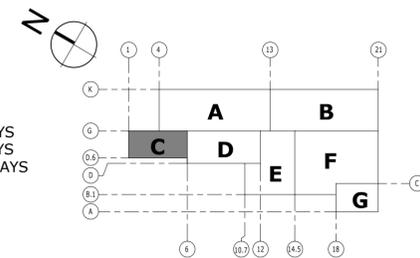

KEY PLAN

NO.	Revision Description	Date

THE INFORMATION, INCLUDING ESTIMATED QUANTITIES OF WORK, SHOWN ON THESE SHEETS IS BASED ON LIMITED INVESTIGATIONS BY THE STATE AND IS IN NO WAY WARRANTED TO INDICATE THE CONDITIONS OF ACTUAL QUANTITIES OF WORK WHICH WILL BE REQUIRED.

DESIGNER/DRAFTER
RHL
CHECKED BY:
RSL
SCALE
1/8" = 1'-0"



STATE OF CONNECTICUT
DEPARTMENT OF TRANSPORTATION

File Name: MPPP_CTDOT_Rocky Hill Repair Facility_Central.rvt

SIGNATURE/BLOCK:

[Signature]

PROJECT TITLE

REPAIR FACILITY


TOWN

ROCKY HILL

DRAWING TITLE
PLUMBING UNDERGROUND - PART PLAN C

PROJECT NO.
118-0167
DRAWING NO.
PLM-103U
SHEET NO.
09.05

Plotted: 10/21/2014 3:41:22 PM

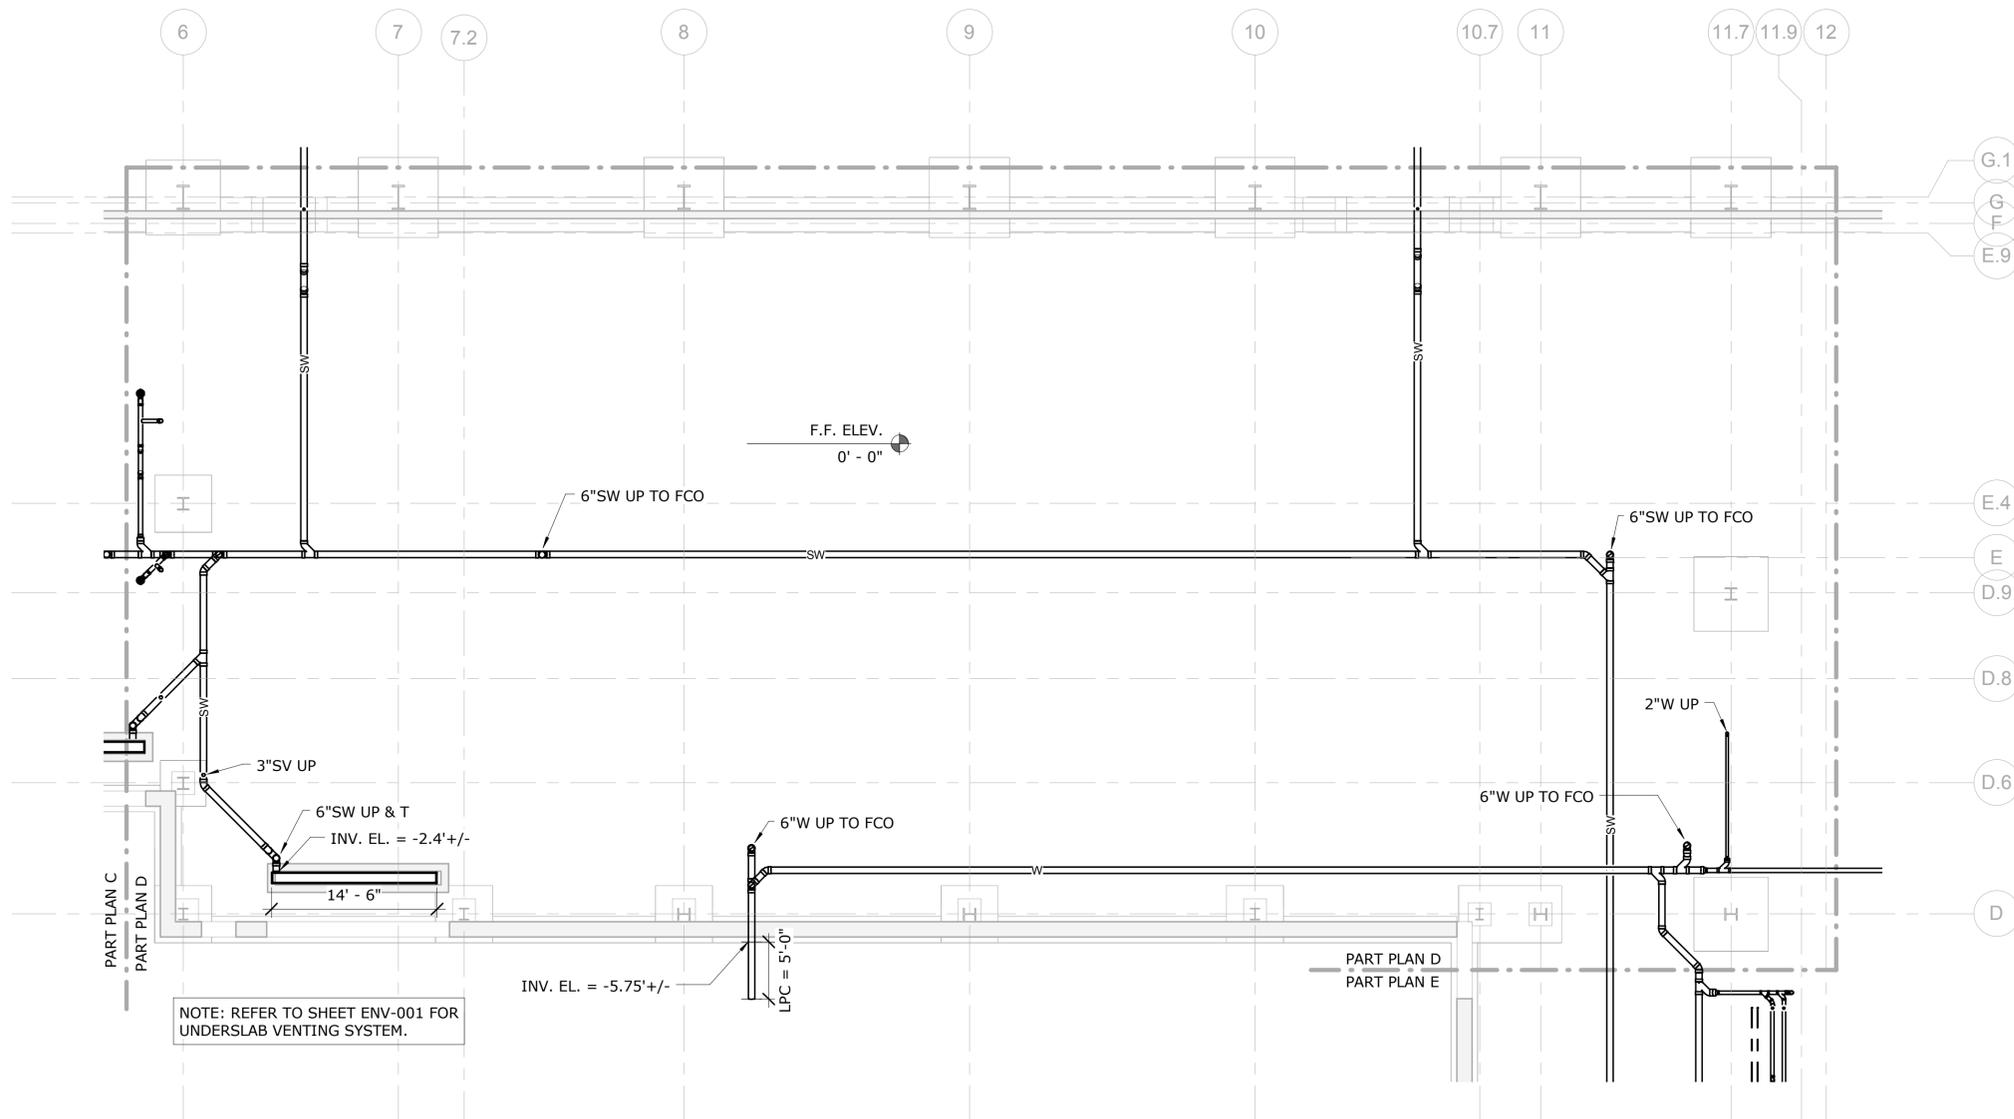


NOTE: REFER TO SHEET ENV-001 FOR UNDERSLAB VENTING SYSTEM.

1 PLUMBING - FOUNDATION - PART PLAN D - STORES
SCALE: 1/8" = 1'-0"

PARTIAL PLAN LEGEND:

- A - NORTH REPAIR BAYS
- B - SOUTH REPAIR BAYS
- C - LUBE AND WASH BAYS
- D - STORES
- E - OFFICE AREA
- F - MACHINE SHOP
- G - PAINT AREA

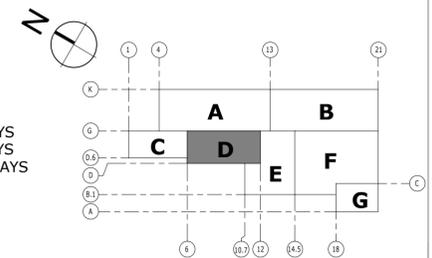

KEY PLAN

NO.	Revision Description	Date

THE INFORMATION, INCLUDING ESTIMATED QUANTITIES OF WORK, SHOWN ON THESE SHEETS IS BASED ON LIMITED INVESTIGATIONS BY THE STATE AND IS IN NO WAY WARRANTED TO INDICATE THE CONDITIONS OF ACTUAL QUANTITIES OF WORK WHICH WILL BE REQUIRED.

Plotted: 10/21/2014 3:41:29 PM

DESIGNER/DRAFTER
RHL
CHECKED BY:
RSL
SCALE
1/8" = 1'-0"



STATE OF CONNECTICUT
DEPARTMENT OF TRANSPORTATION

File Name: MPPP_CTDOT_Rocky Hill Repair Facility_Central.rvt



SIGNATURE/BLOCK:

RHL

PROJECT TITLE

REPAIR FACILITY

TOWN

ROCKY HILL

DRAWING TITLE
PLUMBING UNDERGROUND - PART PLAN D

PROJECT NO.


118-0167

DRAWING NO.

PLM-104U

SHEET NO.

09.06

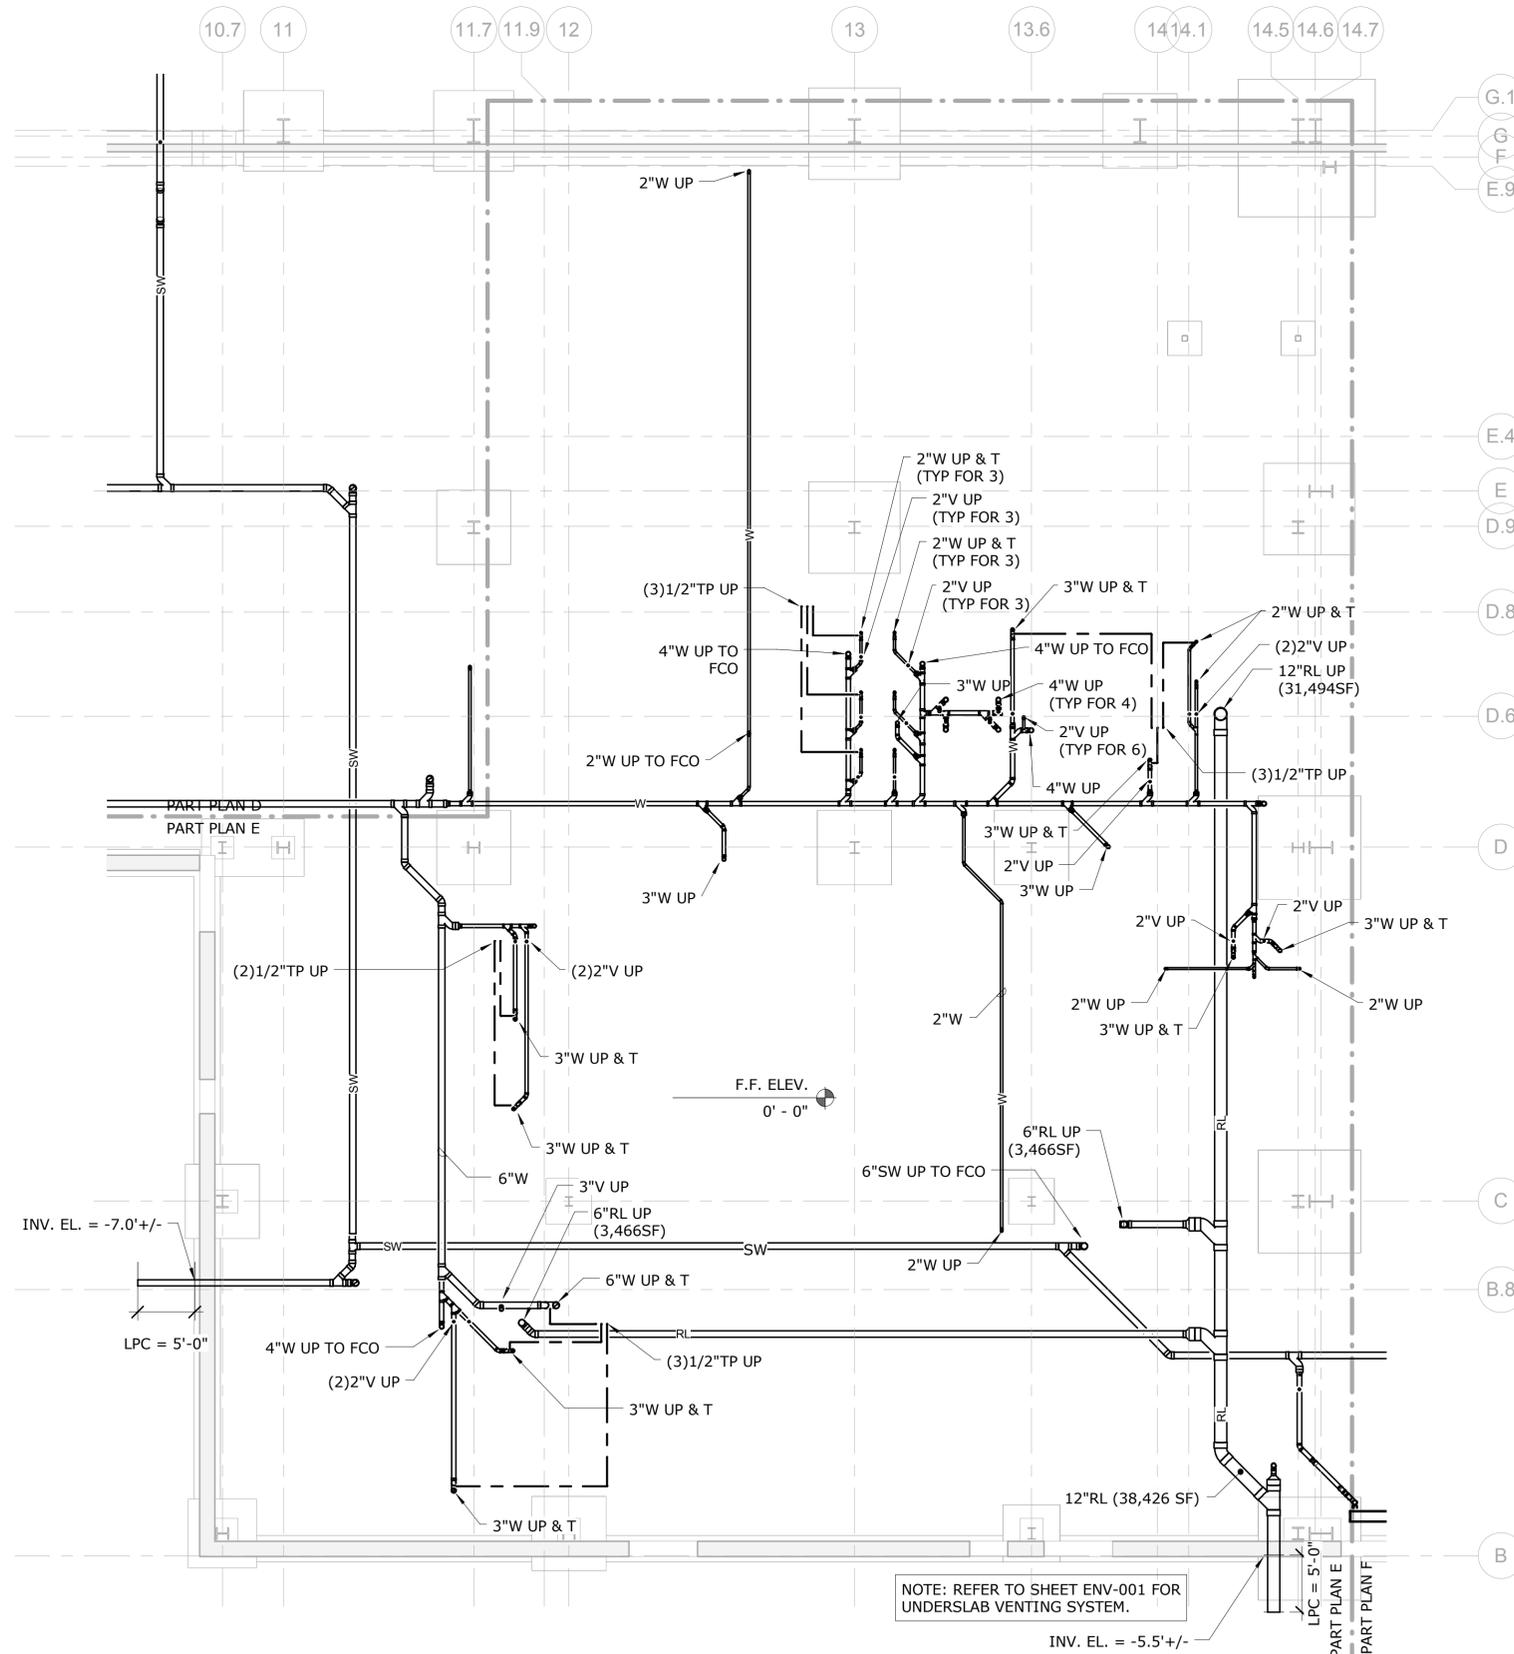


1 PLUMBING - FOUNDATION - PART PLAN E - OFFICE AREA
SCALE: 1/8" = 1'-0"

NOTE: REFER TO SHEET ENV-001 FOR UNDERSLAB VENTING SYSTEM.

PARTIAL PLAN LEGEND:

- A - NORTH REPAIR BAYS
- B - SOUTH REPAIR BAYS
- C - LUBE AND WASH BAYS
- D - STORES
- E - OFFICE AREA
- F - MACHINE SHOP
- G - PAINT AREA

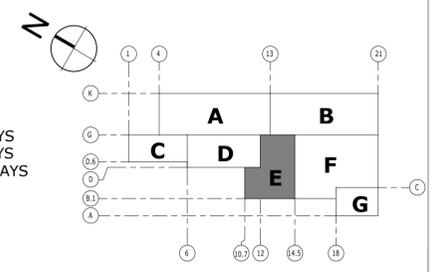

KEY PLAN

NO.	Revision Description	Date

THE INFORMATION, INCLUDING ESTIMATED QUANTITIES OF WORK, SHOWN ON THESE SHEETS IS BASED ON LIMITED INVESTIGATIONS BY THE STATE AND IS IN NO WAY WARRANTED TO INDICATE THE CONDITIONS OF ACTUAL QUANTITIES OF WORK WHICH WILL BE REQUIRED.

DESIGNER/DRAFTER
RHL
CHECKED BY:
RSL
SCALE
1/8" = 1'-0"




SIGNATURE/BLOCK:
[Signature]

PROJECT TITLE
REPAIR FACILITY

TOWN
ROCKY HILL
DRAWING TITLE
PLUMBING UNDERGROUND - PART PLAN E


PROJECT NO.
118-0167
DRAWING NO.
PLM-105U
SHEET NO.
09.07

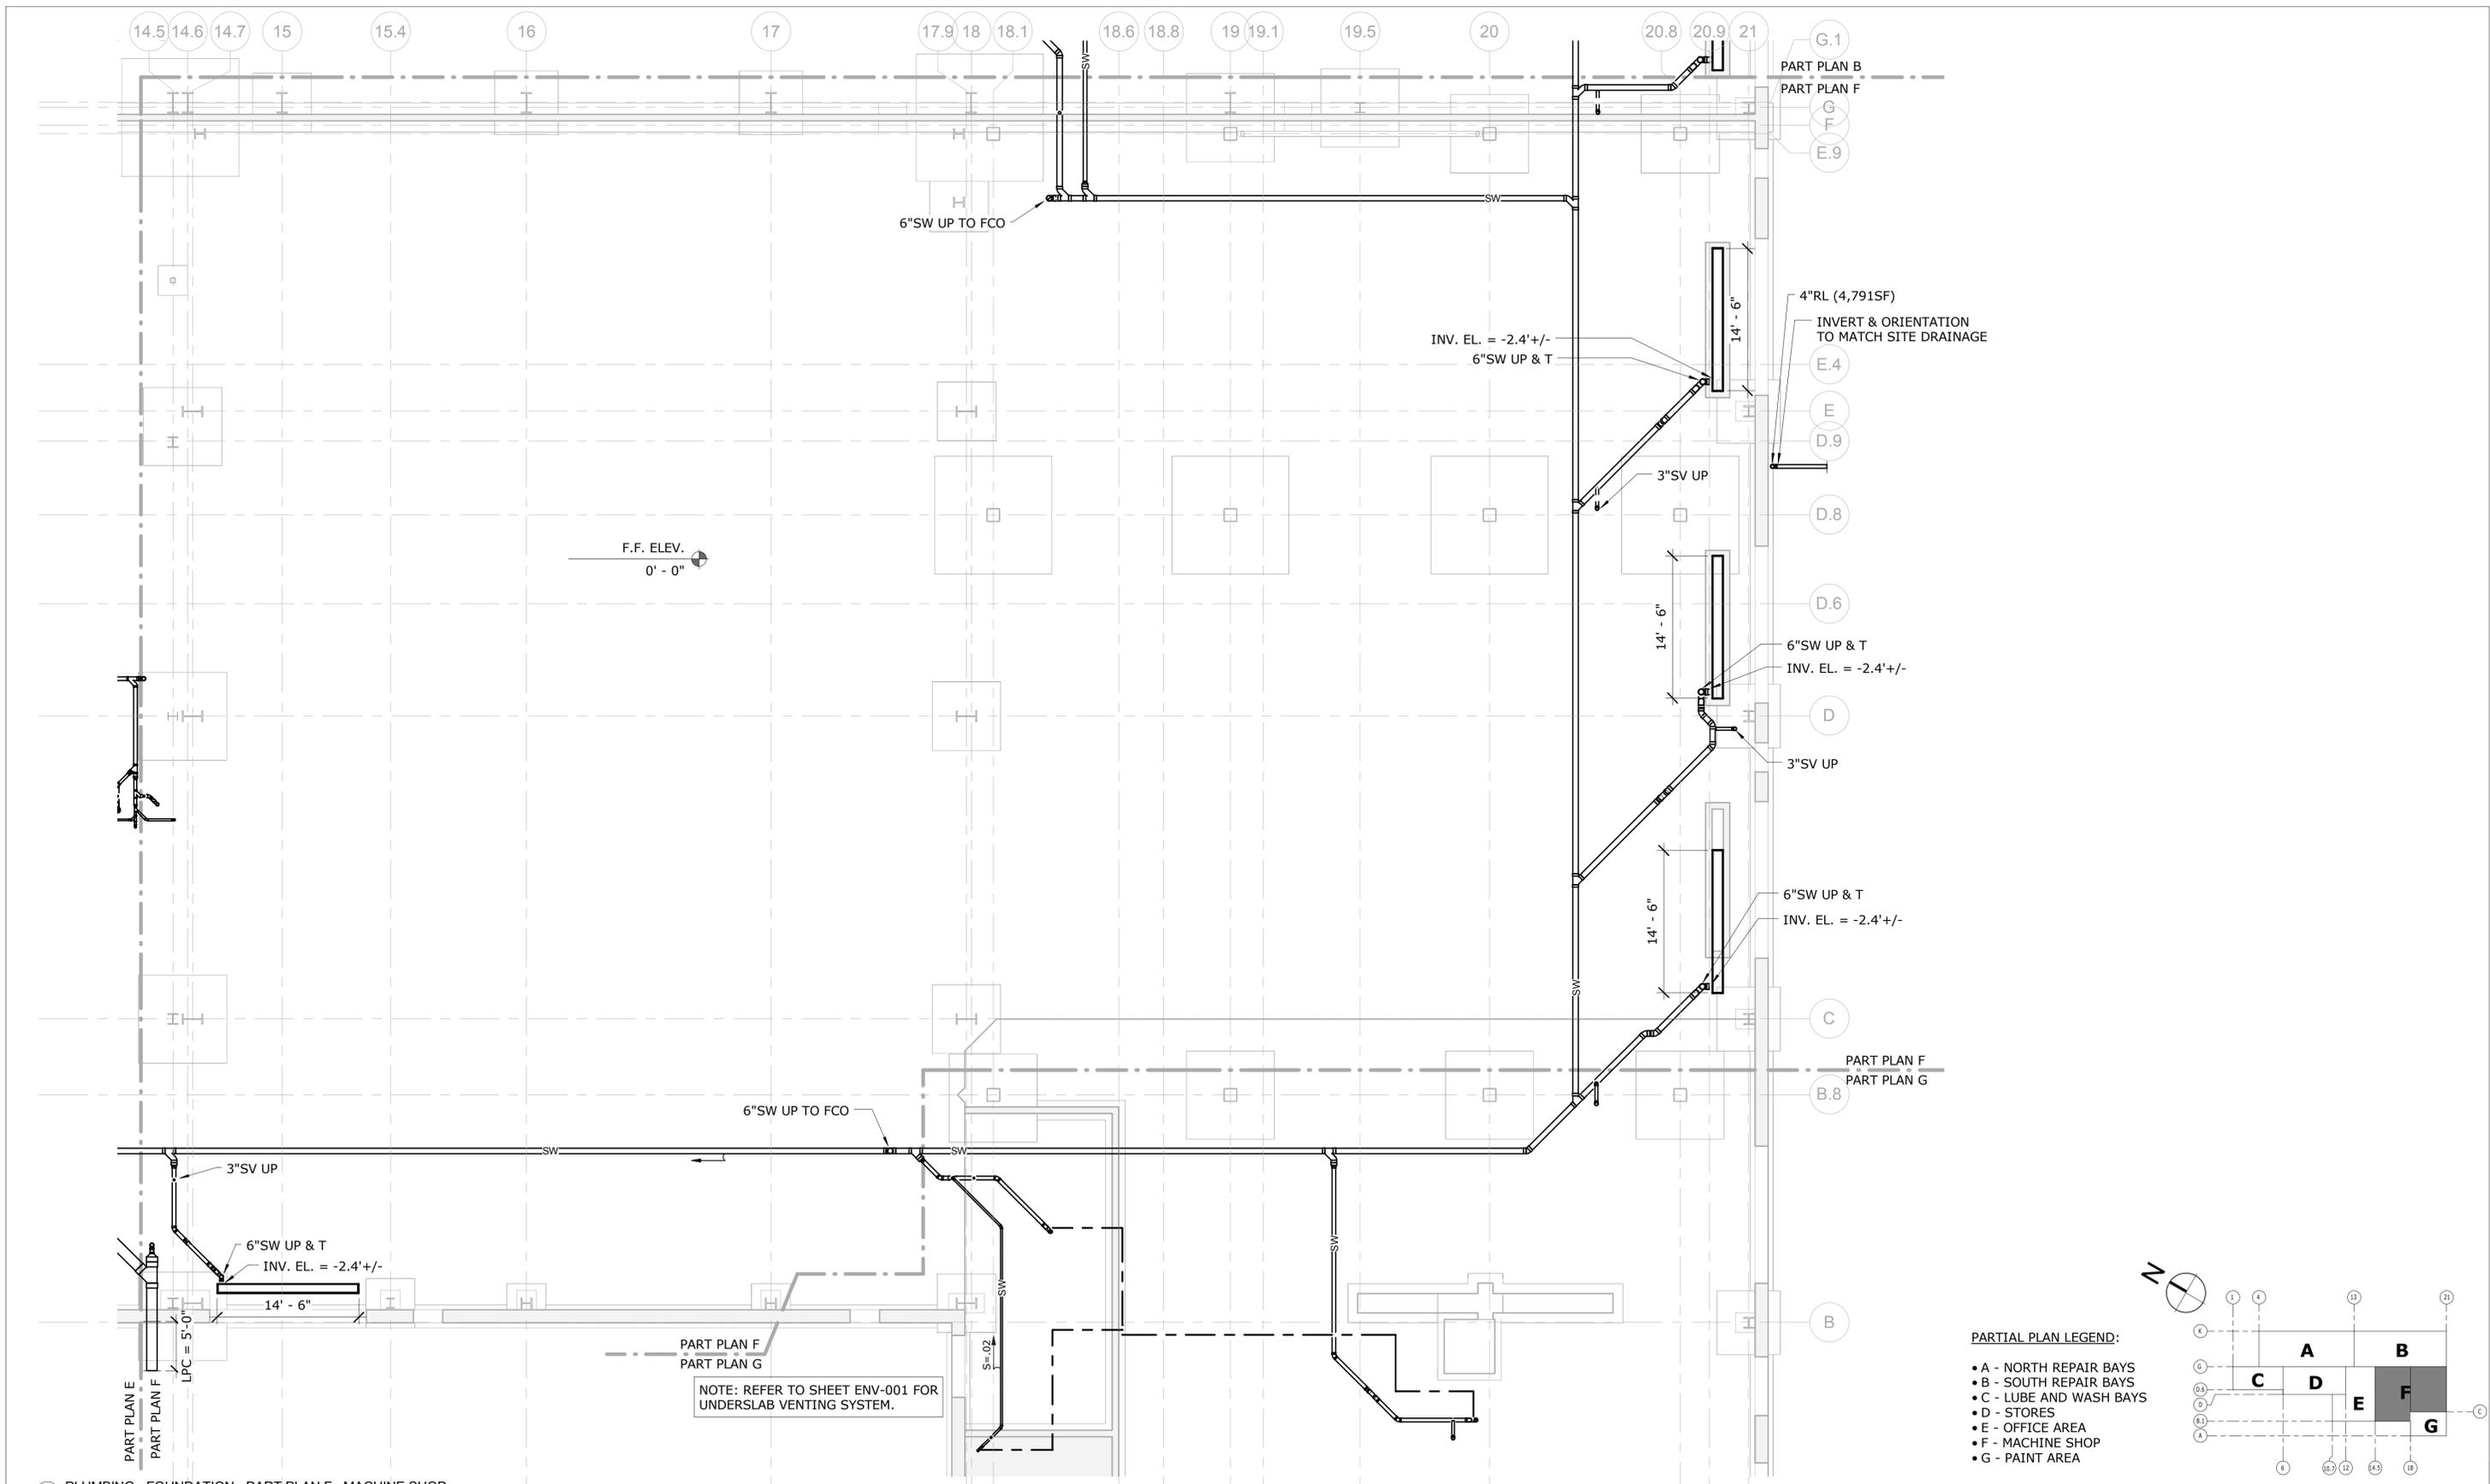

1 PLUMBING - FOUNDATION - PART PLAN F - MACHINE SHOP
SCALE: 1/8" = 1'-0"

NOTE: REFER TO SHEET ENV-001 FOR UNDERSLAB VENTING SYSTEM.

- PARTIAL PLAN LEGEND:**
- A - NORTH REPAIR BAYS
 - B - SOUTH REPAIR BAYS
 - C - LUBE AND WASH BAYS
 - D - STORES
 - E - OFFICE AREA
 - F - MACHINE SHOP
 - G - PAINT AREA

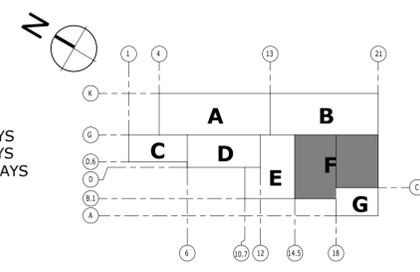

NO.	Revision Description	Date

THE INFORMATION, INCLUDING ESTIMATED QUANTITIES OF WORK, SHOWN ON THESE SHEETS IS BASED ON LIMITED INVESTIGATIONS BY THE STATE AND IS IN NO WAY WARRANTED TO INDICATE THE CONDITIONS OF ACTUAL QUANTITIES OF WORK WHICH WILL BE REQUIRED.

Plotted: 10/21/2014 3:41:49 PM

DESIGNER/DRAFTER
RHL

CHECKED BY:
RSL

SCALE
1/8" = 1'-0"



SIGNATURE/BLOCK:

[Handwritten Signature]

PROJECT TITLE
REPAIR FACILITY


TOWN
ROCKY HILL

DRAWING TITLE
PLUMBING UNDERGROUND - PART PLAN F

PROJECT NO.
118-0167

DRAWING NO.
PLM-106U


SHEET NO.
09.08

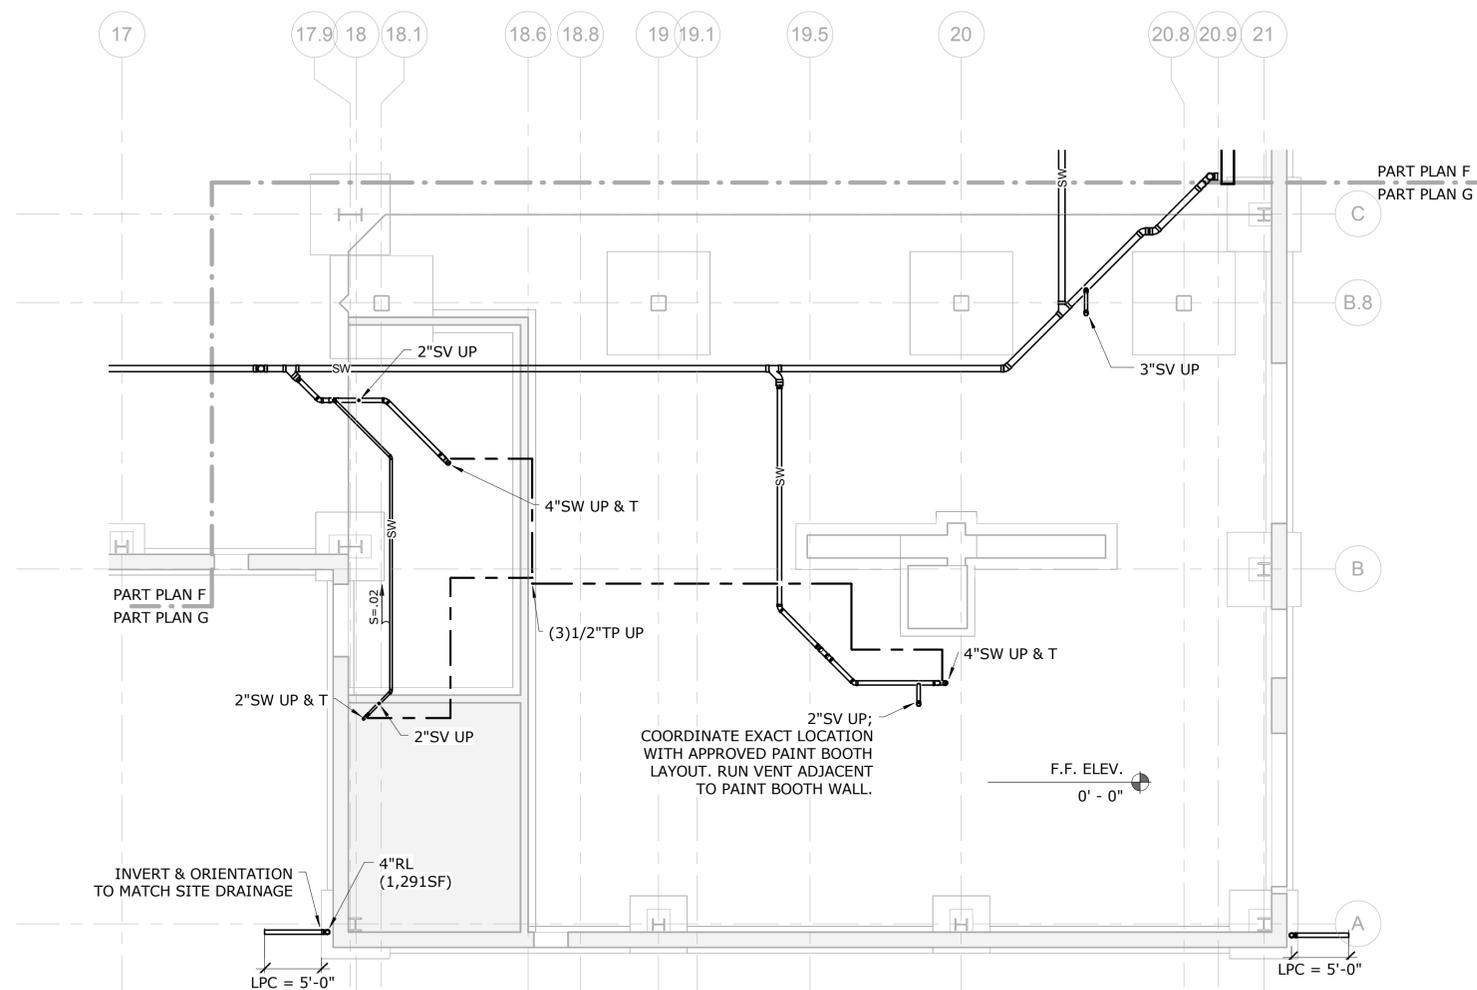

1 PLUMBING - FOUNDATION - PART PLAN G - PAINT AREA
SCALE: 1/8" = 1'-0"

PARTIAL PLAN LEGEND:

- A - NORTH REPAIR BAYS
- B - SOUTH REPAIR BAYS
- C - LUBE AND WASH BAYS
- D - STORES
- E - OFFICE AREA
- F - MACHINE SHOP
- G - PAINT AREA

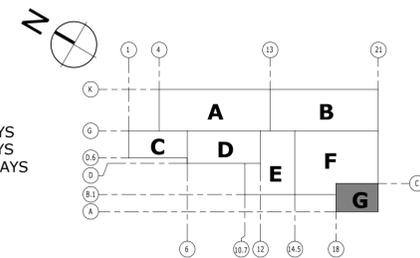

KEY PLAN

NO.	Revision Description	Date

THE INFORMATION, INCLUDING ESTIMATED QUANTITIES OF WORK, SHOWN ON THESE SHEETS IS BASED ON LIMITED INVESTIGATIONS BY THE STATE AND IS IN NO WAY WARRANTED TO INDICATE THE CONDITIONS OF ACTUAL QUANTITIES OF WORK WHICH WILL BE REQUIRED.

DESIGNER/DRAFTER
RHL
CHECKED BY:
RSL
SCALE
1/8" = 1'-0"




SIGNATURE/BLOCK:
[Signature]

PROJECT TITLE
REPAIR FACILITY

TOWN
ROCKY HILL
DRAWING TITLE
PLUMBING UNDERGROUND - PART PLAN G


PROJECT NO.
118-0167
DRAWING NO.
PLM-107U
SHEET NO.
09.09

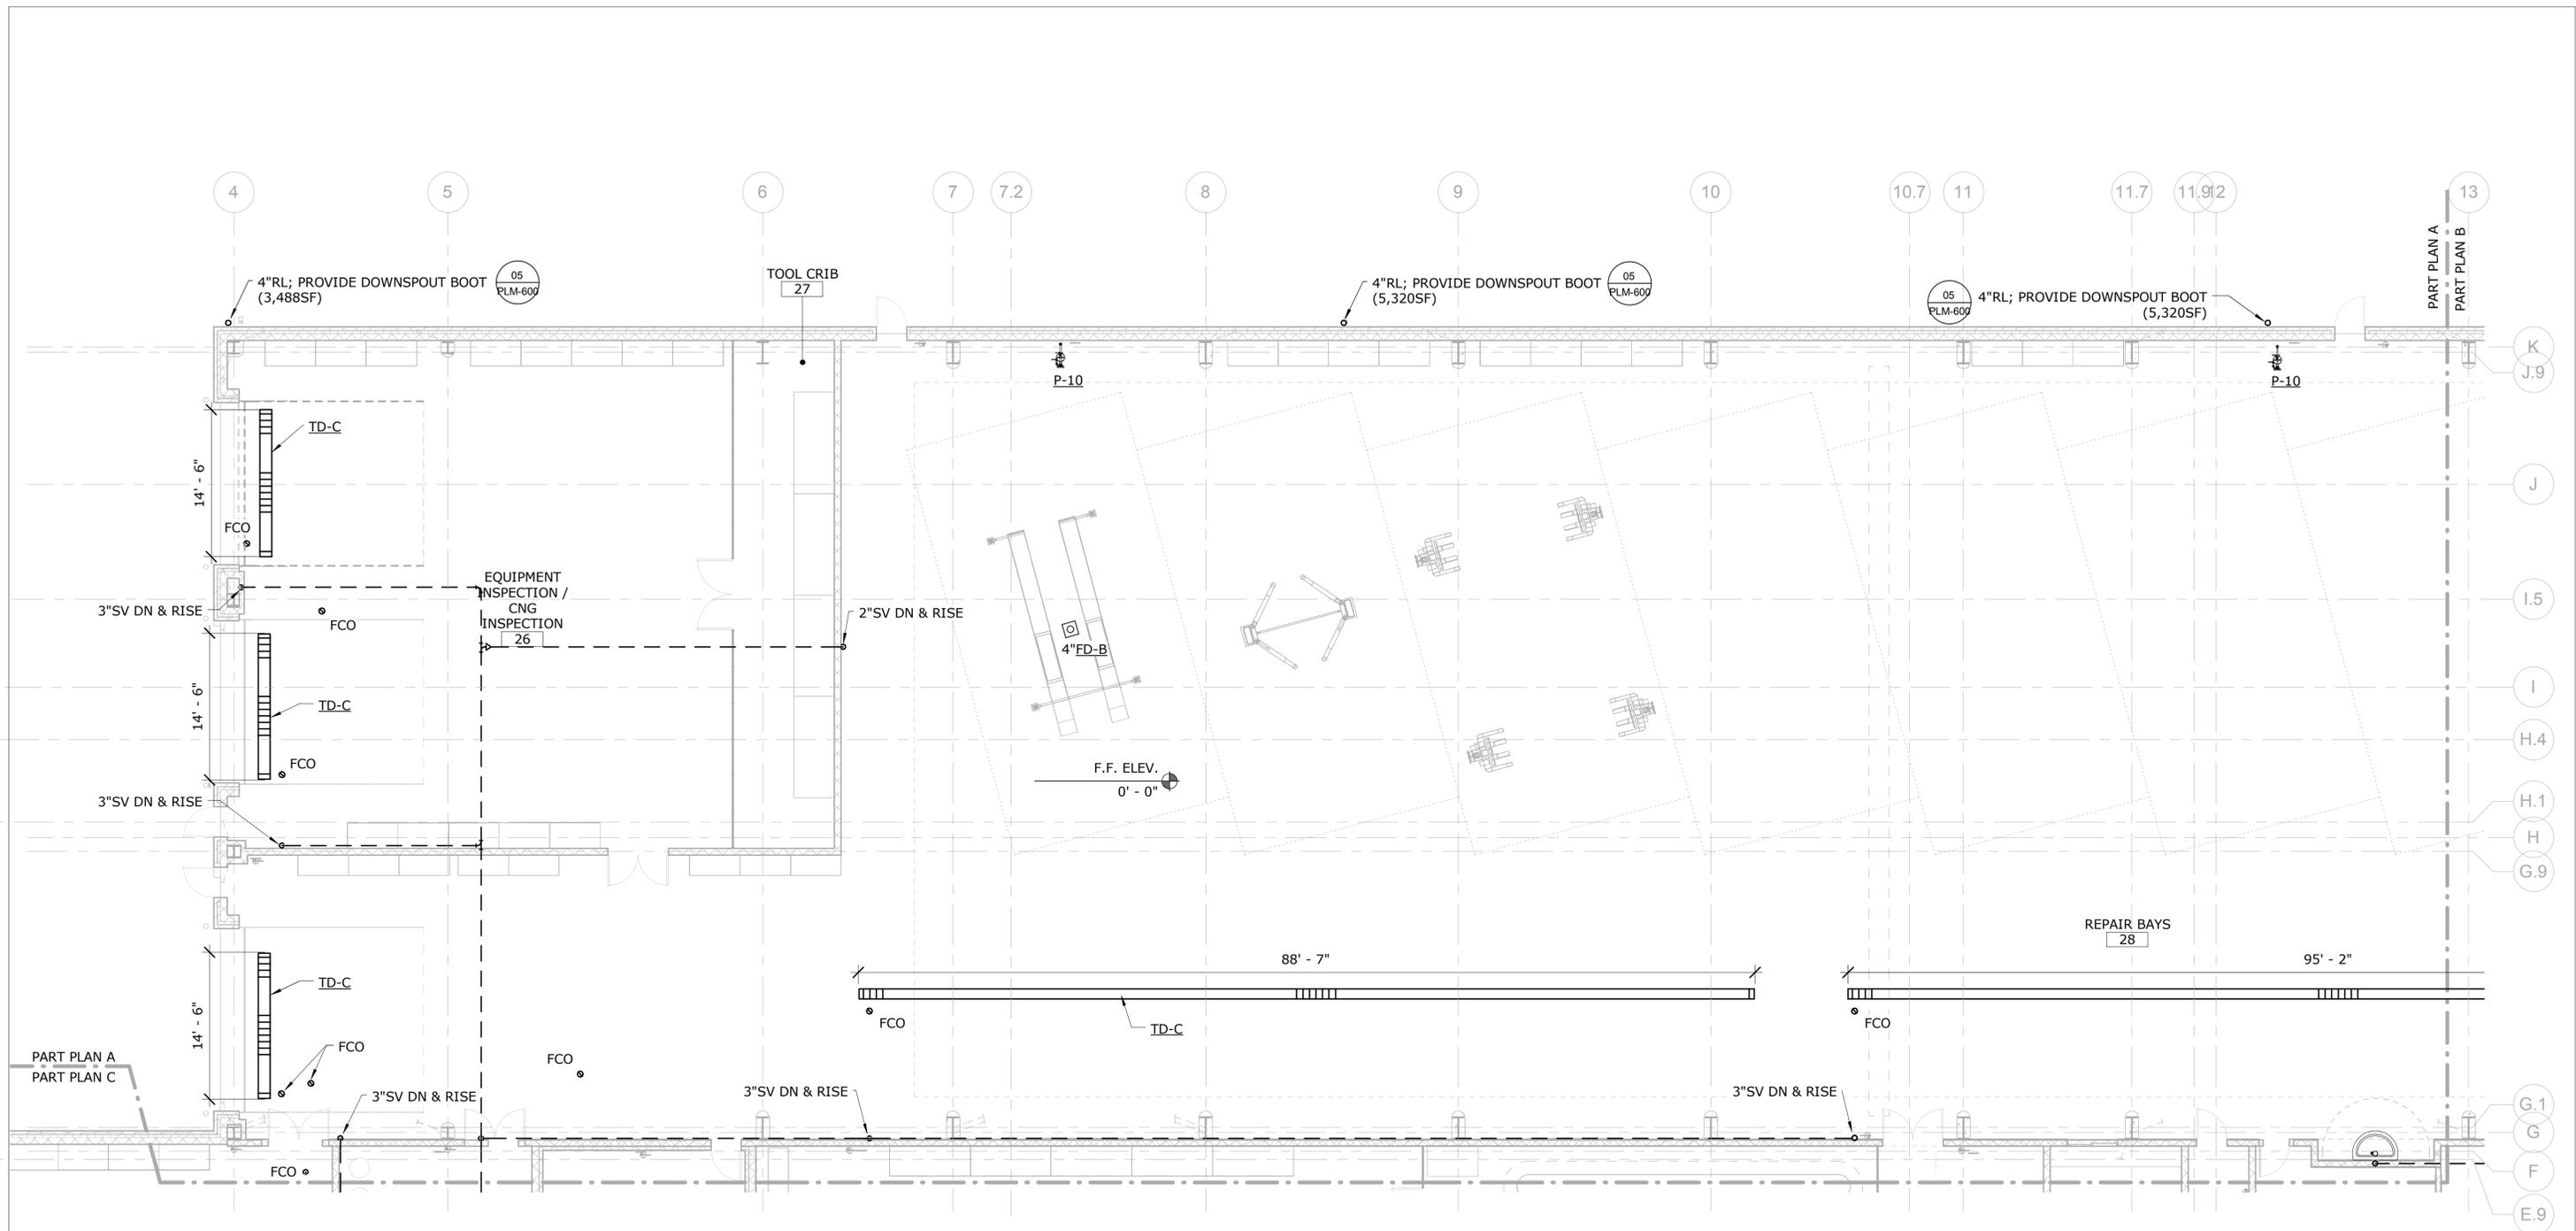

1 PLUMBING - DRAINAGE - PART PLAN A - NORTH REPAIR BAY
SCALE: 1/8" = 1'-0"

NOTES:
1. REFER TO PLUMBING FIXTURE SCHEDULE ON PLM-700 FOR PIPE SIZES TO FIXTURES.

- PARTIAL PLAN LEGEND:
- A - NORTH REPAIR BAYS
 - B - SOUTH REPAIR BAYS
 - C - LUBE AND WASH BAYS
 - D - STORES
 - E - OFFICE AREA
 - F - MACHINE SHOP
 - G - PAINT AREA

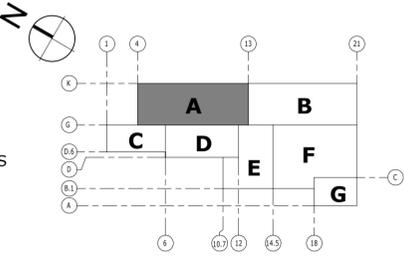

NO.	Revision Description	Date

THE INFORMATION, INCLUDING ESTIMATED QUANTITIES OF WORK, SHOWN ON THESE SHEETS IS BASED ON LIMITED INVESTIGATIONS BY THE STATE AND IS IN NO WAY WARRANTED TO INDICATE THE CONDITIONS OF ACTUAL QUANTITIES OF WORK WHICH WILL BE REQUIRED.

Plotted: 10/21/2014 3:41:05 PM

DESIGNER/DRAFTER
RHL

CHECKED BY:
RSL

SCALE
1/8" = 1'-0"



SIGNATURE/BLOCK:
[Signature]

PROJECT TITLE
REPAIR FACILITY


TOWN
ROCKY HILL

DRAWING TITLE
PLUMBING DRAINAGE - PART PLAN A

PROJECT NO.
118-0167

DRAWING NO.
PLM-101

SHEET NO.
09.10

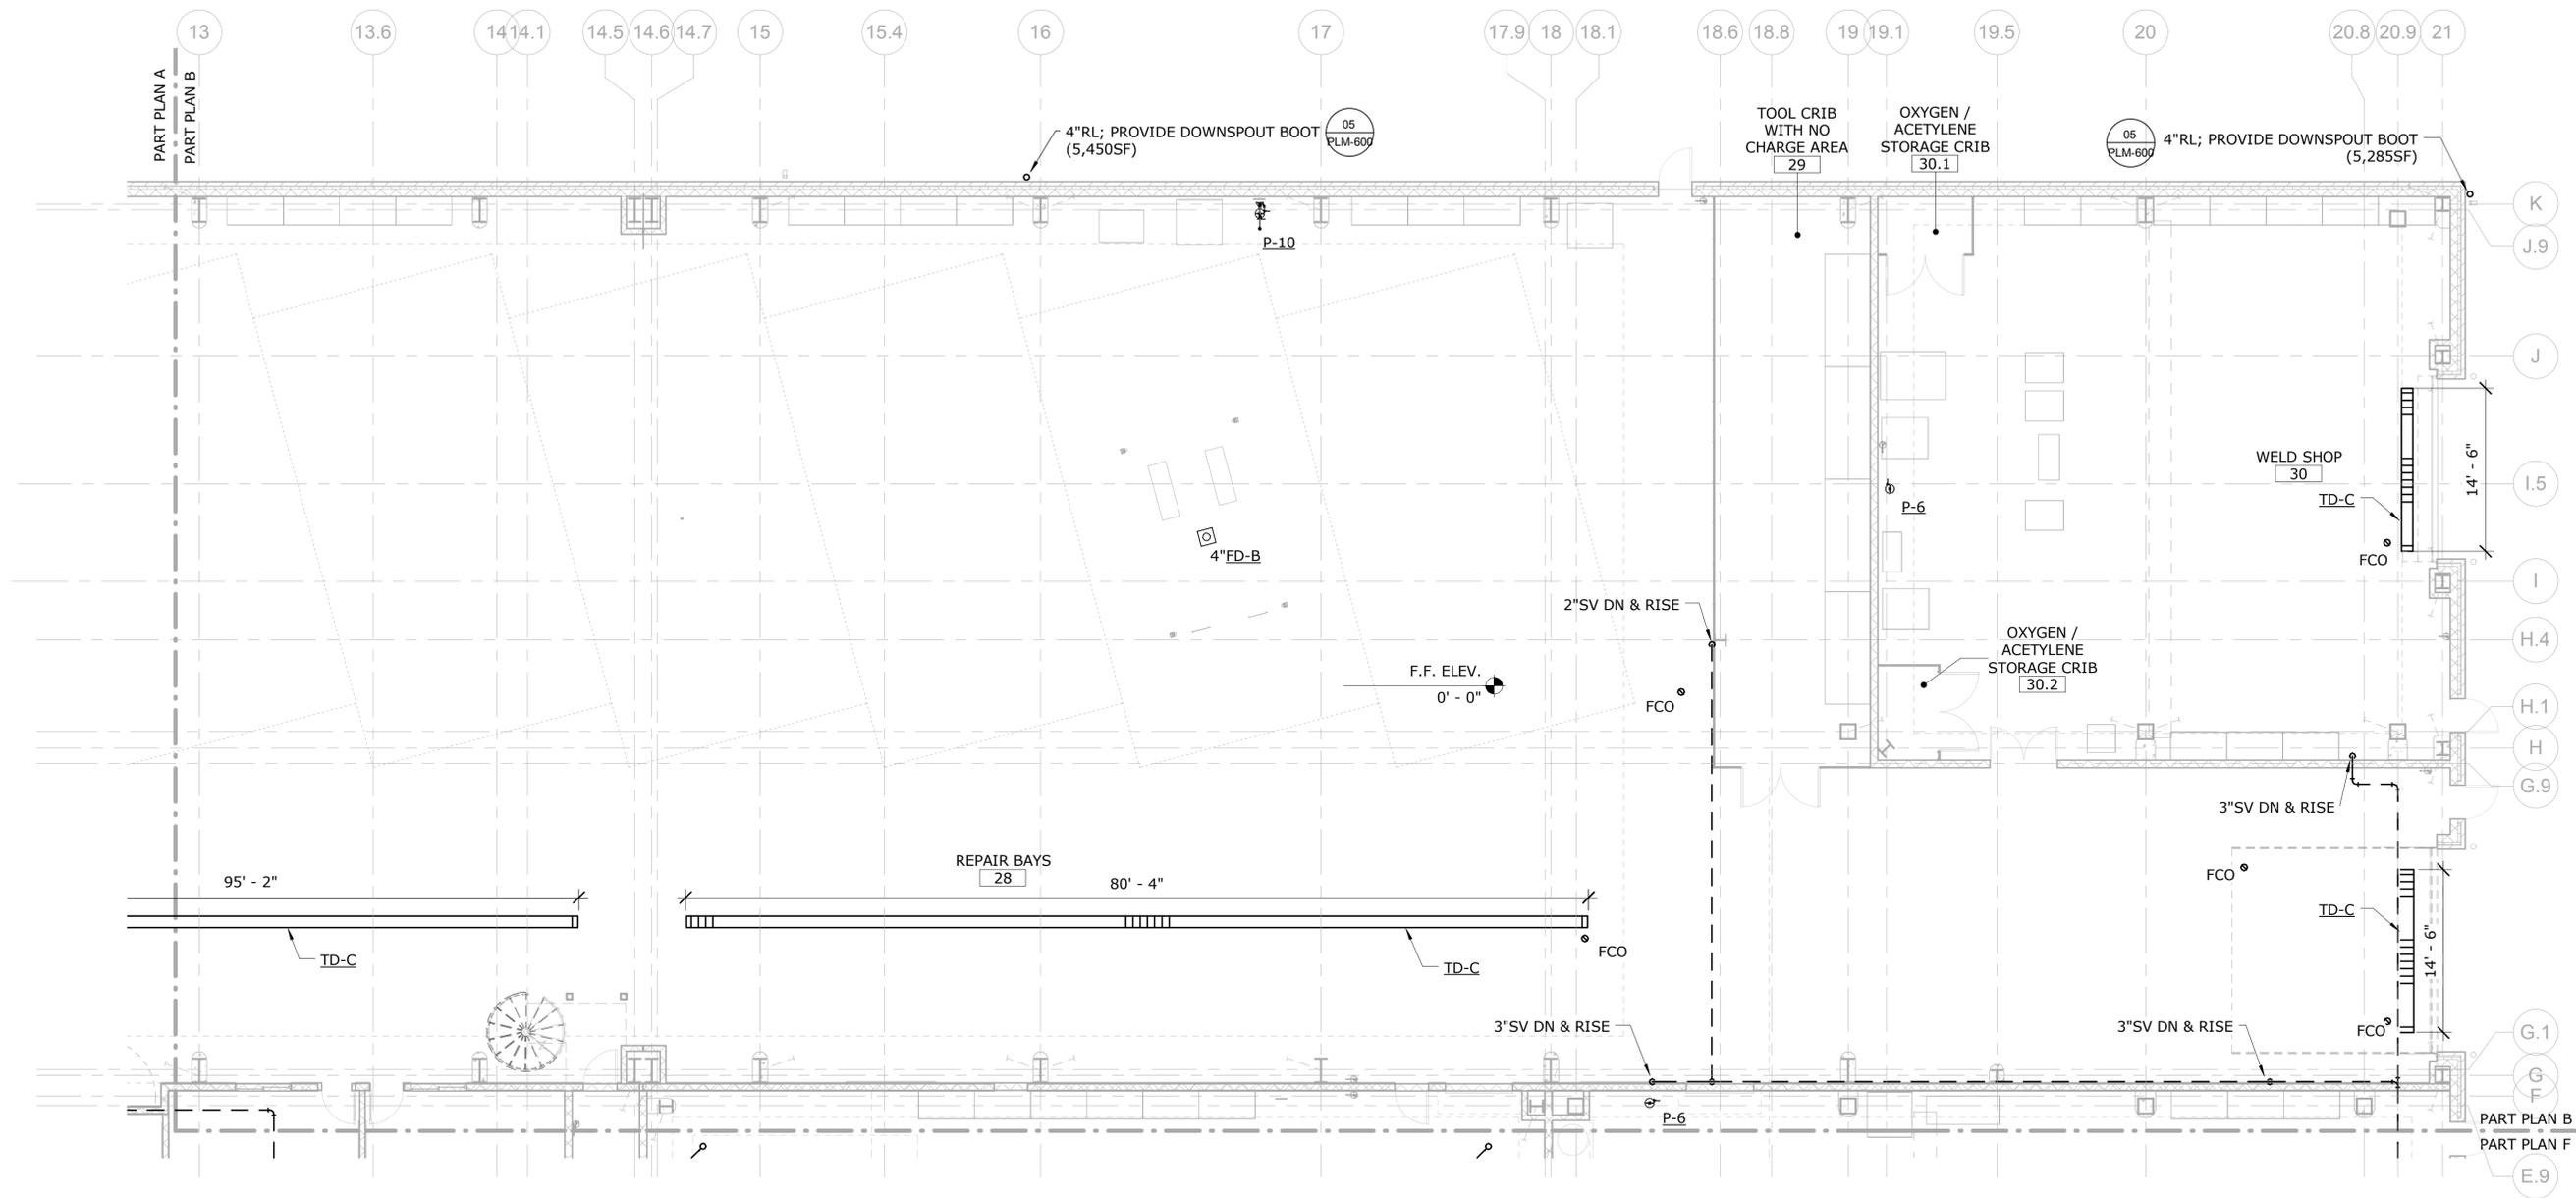


1 PLUMBING - DRAINAGE - PART PLAN B - SOUTH REPAIR BAYS
SCALE: 1/8" = 1'-0"

NOTES:
1. REFER TO PLUMBING FIXTURE SCHEDULE ON PLM-700 FOR PIPE SIZES TO FIXTURES.

PARTIAL PLAN LEGEND:

- A - NORTH REPAIR BAYS
- B - SOUTH REPAIR BAYS
- C - LUBE AND WASH BAYS
- D - STORES
- E - OFFICE AREA
- F - MACHINE SHOP
- G - PAINT AREA

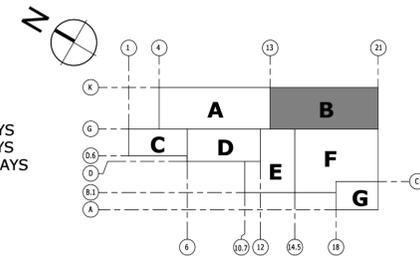

NO.	Revision Description	Date

THE INFORMATION, INCLUDING ESTIMATED QUANTITIES OF WORK, SHOWN ON THESE SHEETS IS BASED ON LIMITED INVESTIGATIONS BY THE STATE AND IS IN NO WAY WARRANTED TO INDICATE THE CONDITIONS OF ACTUAL QUANTITIES OF WORK WHICH WILL BE REQUIRED.

Plotted: 10/21/2014 3:41:12 PM

DESIGNER/DRAFTER
RHL
CHECKED BY:
RSL
SCALE
1/8" = 1'-0"



STATE OF CONNECTICUT
DEPARTMENT OF TRANSPORTATION

File Name: MPPP_CTDOT_Rocky Hill Repair Facility_Central.rvt



SIGNATURE/BLOCK:

RHL

PROJECT TITLE

REPAIR FACILITY

TOWN

ROCKY HILL

DRAWING TITLE
PLUMBING DRAINAGE - PART PLAN B

PROJECT NO.


118-0167

DRAWING NO.

PLM-102

SHEET NO.


09.11

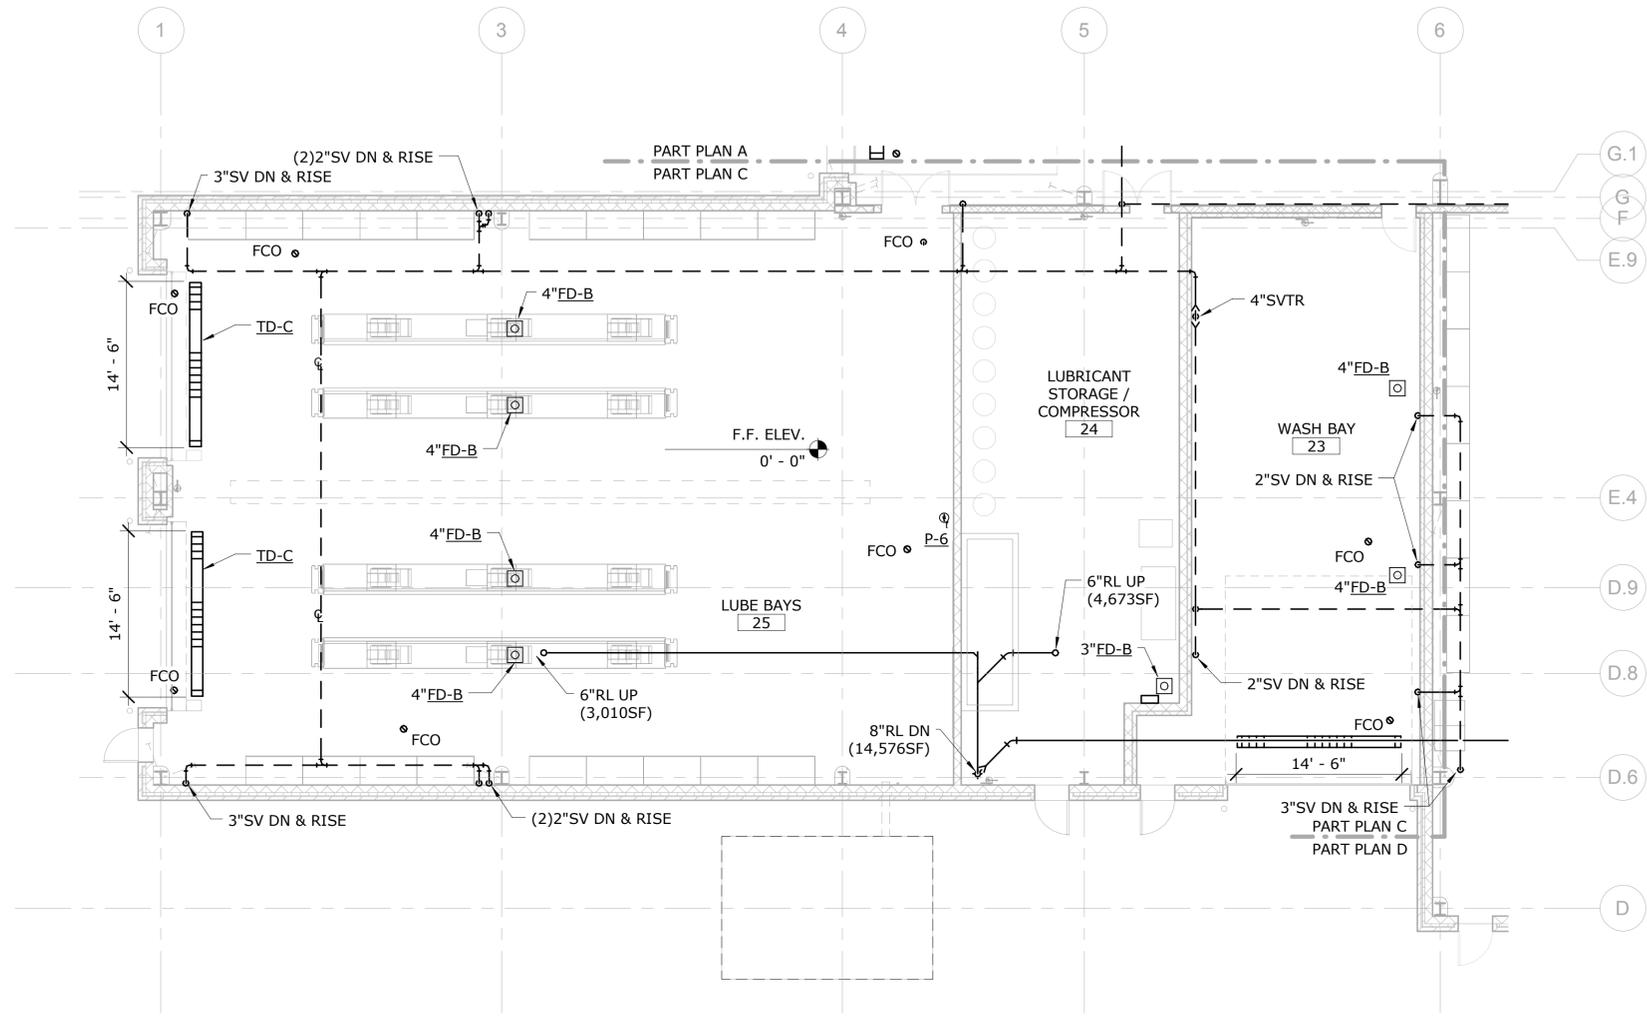

1 PLUMBING - DRAINAGE - PART PLAN C - LUBE & WASH BAYS
SCALE: 1/8" = 1'-0"

NOTES:
1. REFER TO PLUMBING FIXTURE SCHEDULE ON PLM-700 FOR PIPE SIZES TO FIXTURES.

- PARTIAL PLAN LEGEND:
- A - NORTH REPAIR BAYS
 - B - SOUTH REPAIR BAYS
 - C - LUBE AND WASH BAYS
 - D - STORES
 - E - OFFICE AREA
 - F - MACHINE SHOP
 - G - PAINT AREA

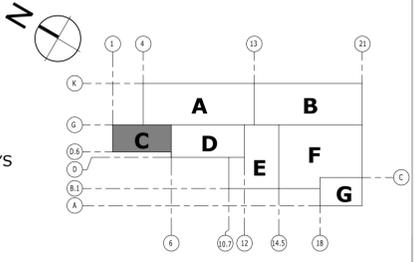

NO.	Revision Description	Date

THE INFORMATION, INCLUDING ESTIMATED QUANTITIES OF WORK, SHOWN ON THESE SHEETS IS BASED ON LIMITED INVESTIGATIONS BY THE STATE AND IS IN NO WAY WARRANTED TO INDICATE THE CONDITIONS OF ACTUAL QUANTITIES OF WORK WHICH WILL BE REQUIRED.

Plotted: 10/21/2014 3:41:19 PM

DESIGNER/DRAFTER
RHL

CHECKED BY:
RSL

SCALE
1/8" = 1'-0"



SIGNATURE/BLOCK:

PROJECT TITLE
REPAIR FACILITY


TOWN
ROCKY HILL

DRAWING TITLE
PLUMBING DRAINAGE - PART PLAN C

PROJECT NO.
118-0167

DRAWING NO.
PLM-103

SHEET NO.
09.12

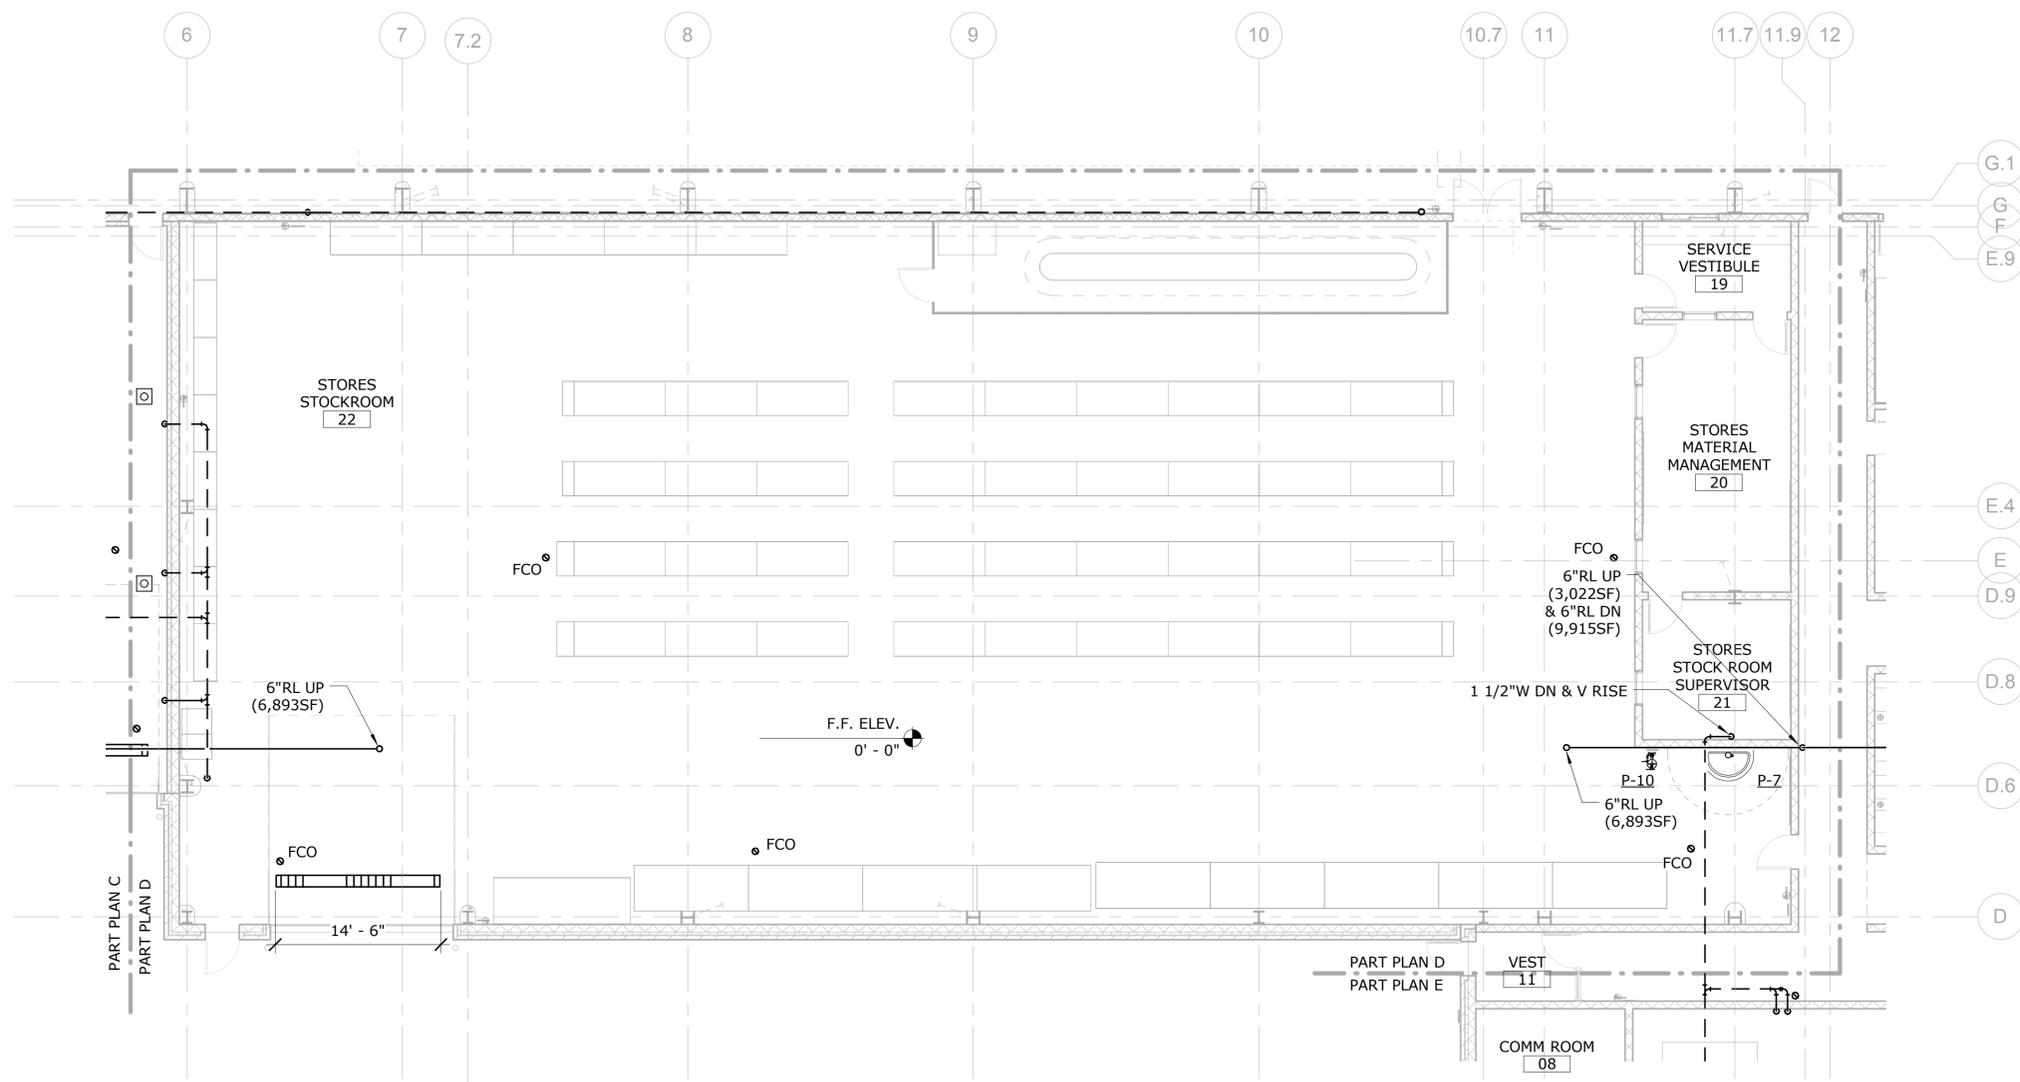


1 PLUMBING - DRAINAGE - PART PLAN D - STORES
SCALE: 1/8" = 1'-0"

NOTES:
1. REFER TO PLUMBING FIXTURE SCHEDULE ON PLM-700 FOR PIPE SIZES TO FIXTURES.

PARTIAL PLAN LEGEND:

- A - NORTH REPAIR BAYS
- B - SOUTH REPAIR BAYS
- C - LUBE AND WASH BAYS
- D - STORES
- E - OFFICE AREA
- F - MACHINE SHOP
- G - PAINT AREA

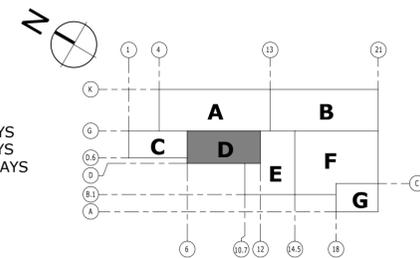

KEY PLAN

NO.	Revision Description	Date

THE INFORMATION, INCLUDING ESTIMATED QUANTITIES OF WORK, SHOWN ON THESE SHEETS IS BASED ON LIMITED INVESTIGATIONS BY THE STATE AND IS IN NO WAY WARRANTED TO INDICATE THE CONDITIONS OF ACTUAL QUANTITIES OF WORK WHICH WILL BE REQUIRED.

DESIGNER/DRAFTER
RHL
CHECKED BY:
RSL
SCALE
1/8" = 1'-0"



STATE OF CONNECTICUT
DEPARTMENT OF TRANSPORTATION

File Name: MPPP_CTDOT_Rocky Hill Repair Facility_Central.rvt

SIGNATURE/BLOCK:

[Signature]

PROJECT TITLE

REPAIR FACILITY

TOWN

ROCKY HILL

DRAWING TITLE

PLUMBING DRAINAGE - PART PLAN D

PROJECT NO.


118-0167

DRAWING NO.


PLM-104

SHEET NO.

09.13

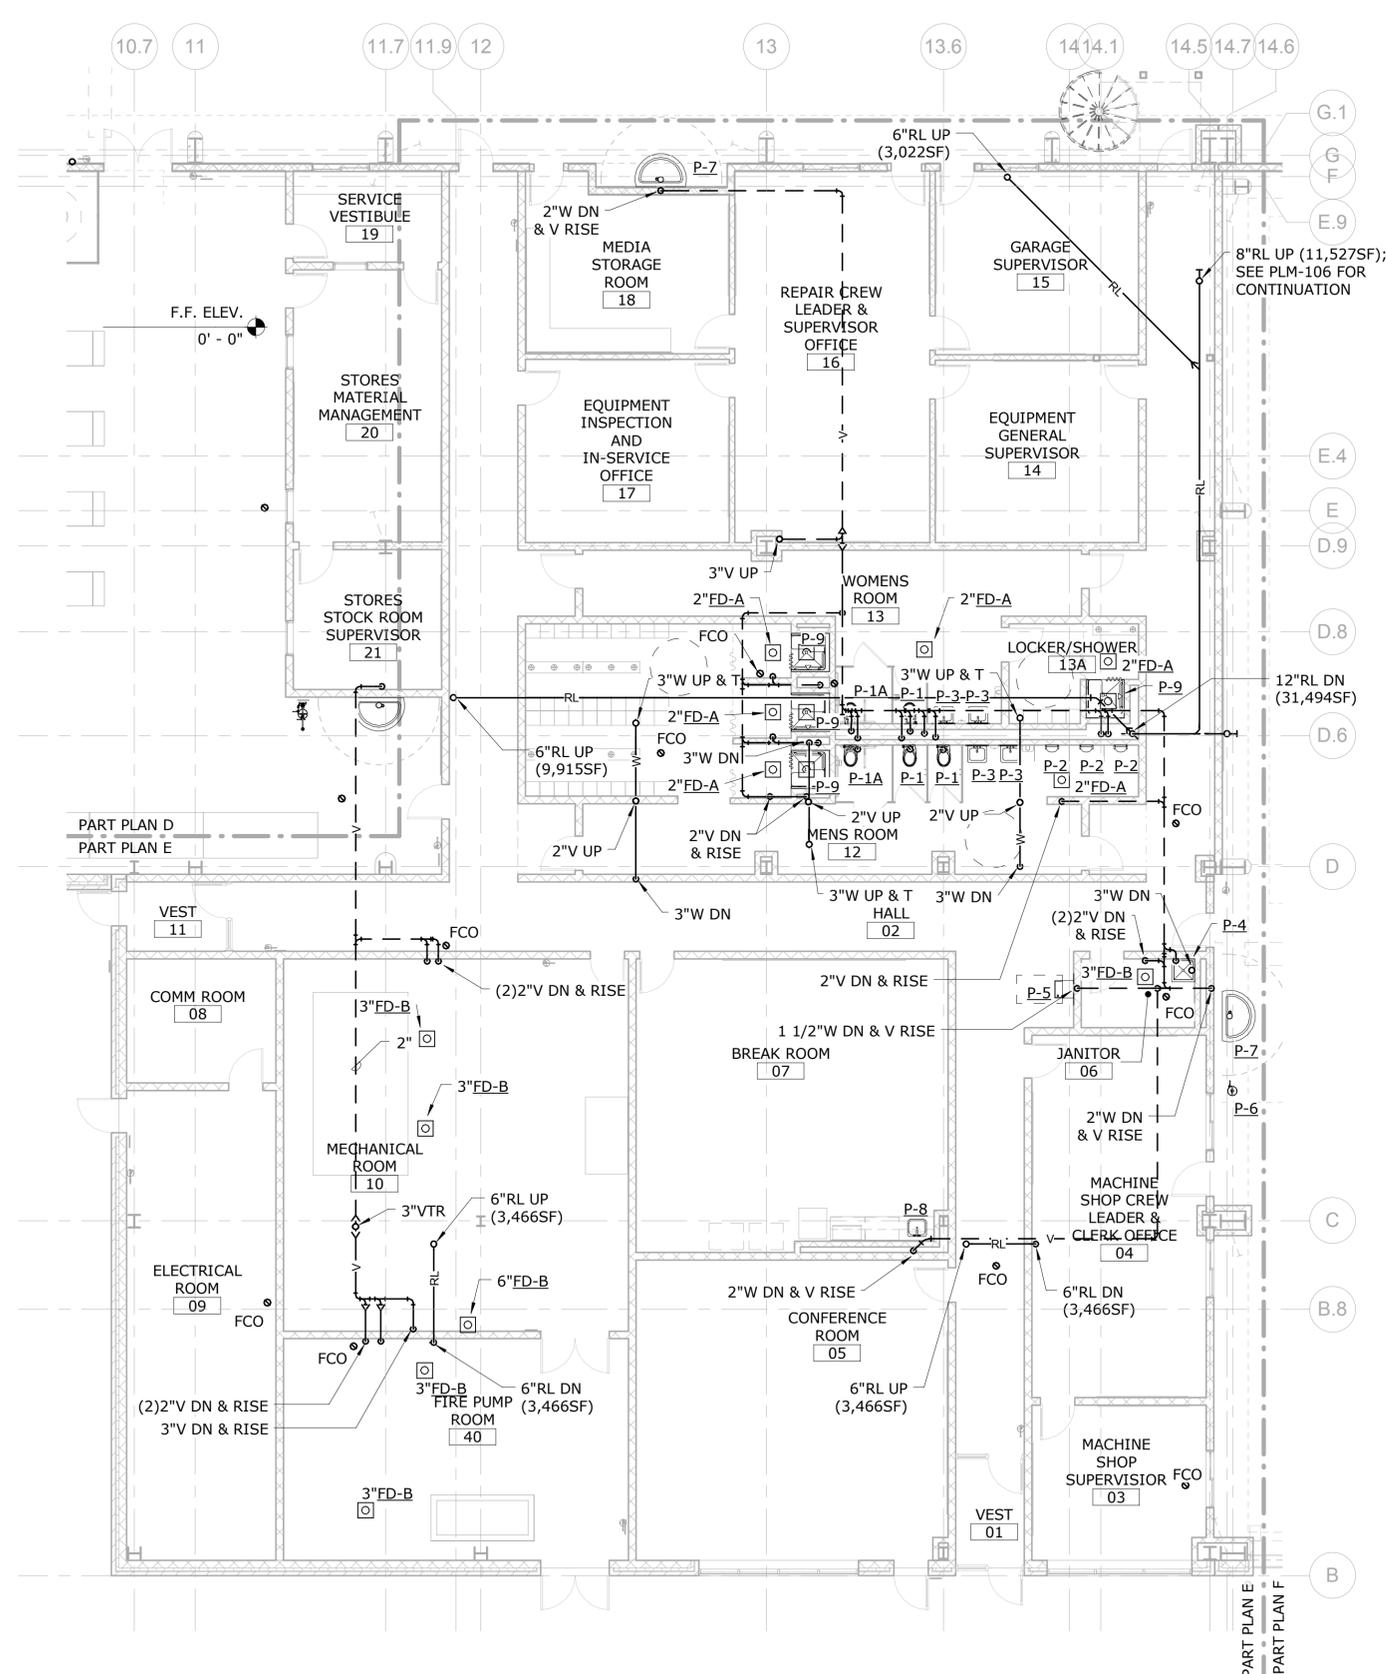


1 PLUMBING - DRAINAGE - PART PLAN E - OFFICE AREA
SCALE: 1/8" = 1'-0"

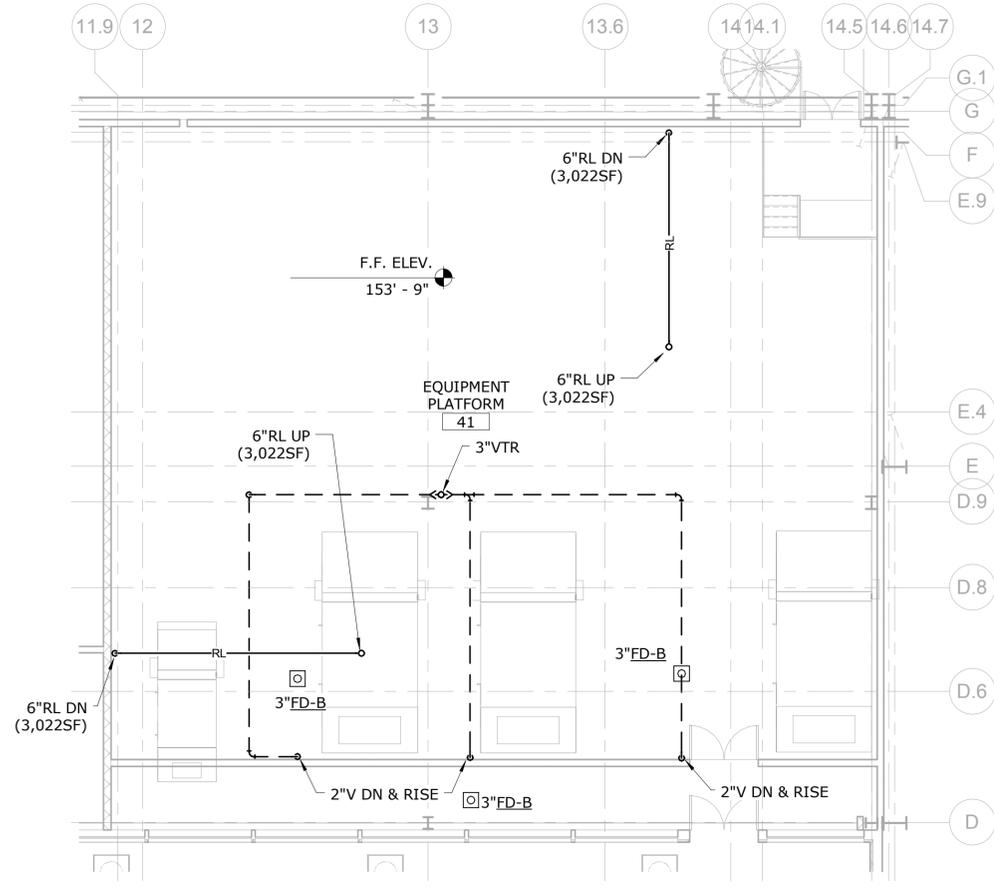

2 PLUMBING - DRAINAGE - EQUIPMENT PLATFORM
SCALE: 1/8" = 1'-0"

NOTES:
1. REFER TO PLUMBING FIXTURE SCHEDULE ON PLM-700 FOR PIPE SIZES TO FIXTURES.

- PARTIAL PLAN LEGEND:
- A - NORTH REPAIR BAYS
 - B - SOUTH REPAIR BAYS
 - C - LUBE AND WASH BAYS
 - D - STORES
 - E - OFFICE AREA
 - F - MACHINE SHOP
 - G - PAINT AREA

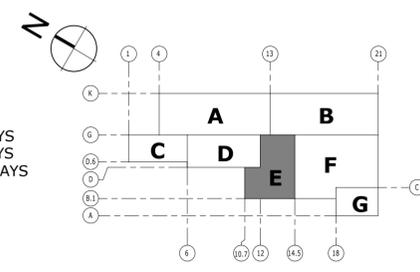

KEY PLAN

NO.	Revision Description	Date

DESIGNER/DRAFTER
RHL

CHECKED BY:
RSL

SCALE
1/8" = 1'-0"

Plotted: 10/21/2014 3:41:35 PM



SIGNATURE/BLOCK:
[Signature]

PROJECT TITLE
REPAIR FACILITY


TOWN
ROCKY HILL

DRAWING TITLE
PLUMBING DRAINAGE - PART PLAN E & PLATFORM

PROJECT NO.
118-0167

DRAWING NO.
PLM-105

SHEET NO.
09.14

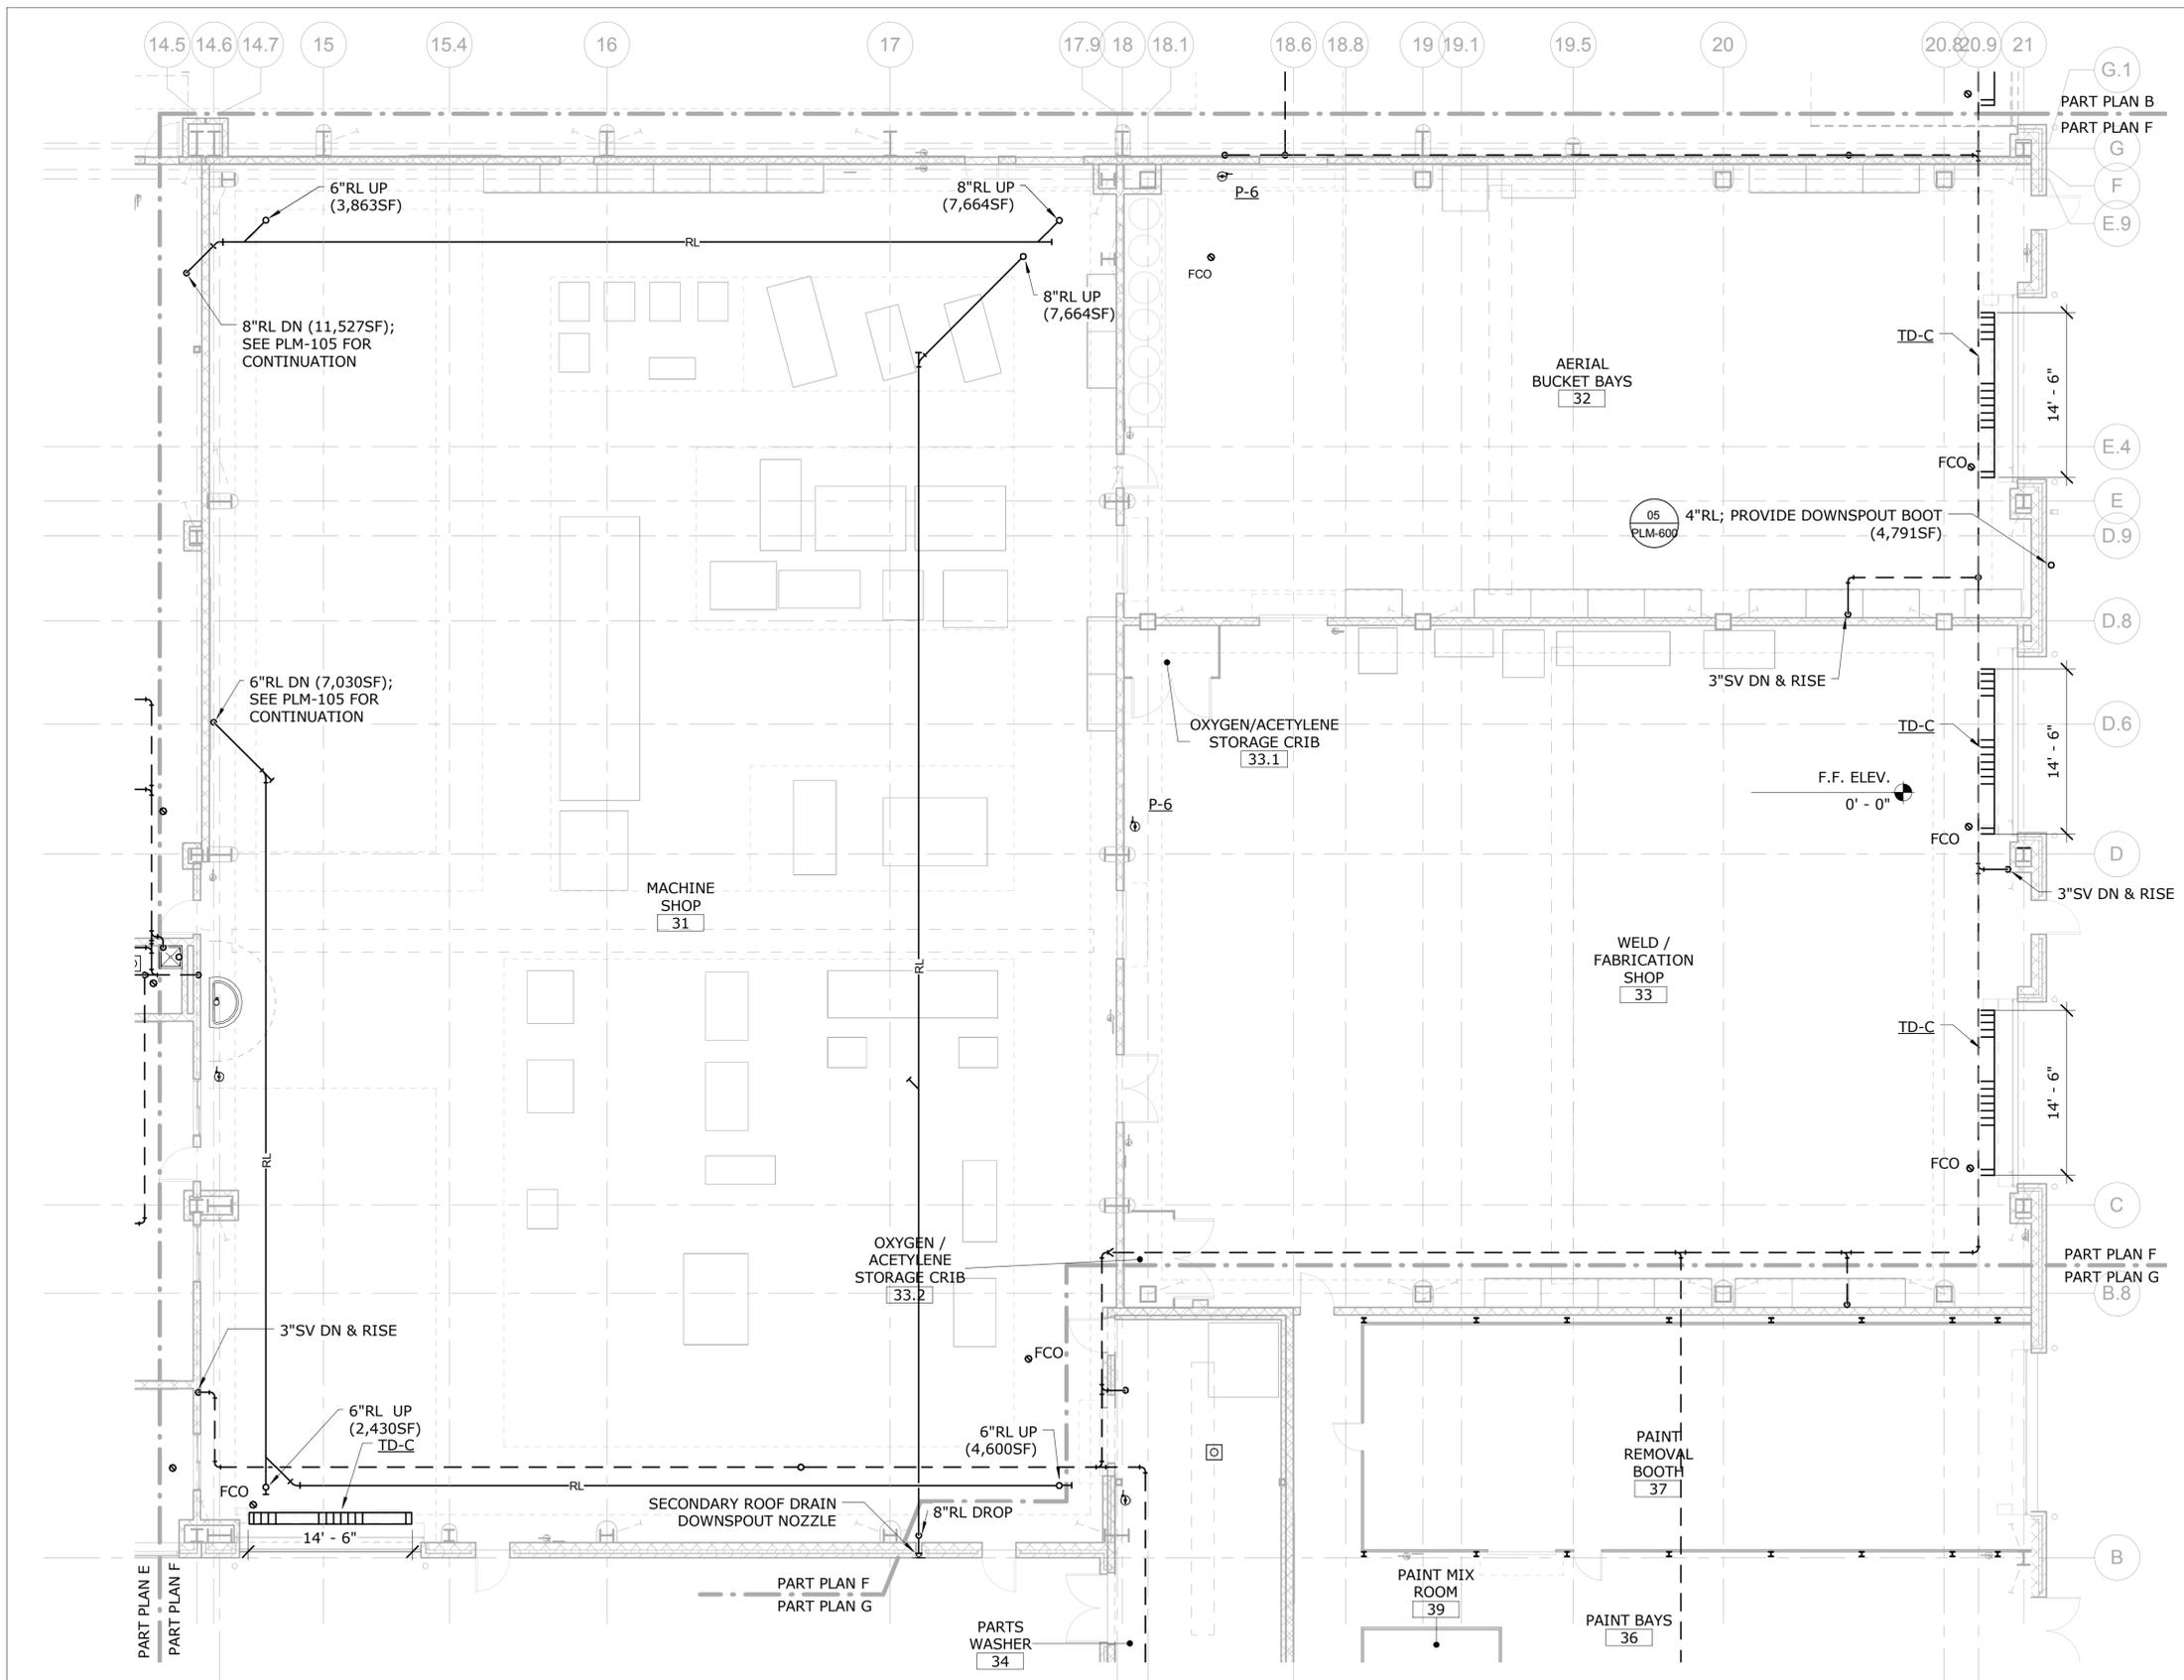


1 PLUMBING - DRAINAGE - PART PLAN F - MACHINE SHOP
SCALE: 1/8" = 1'-0"

NOTES:
1. REFER TO PLUMBING FIXTURE SCHEDULE ON PLM-700 FOR PIPE SIZES TO FIXTURES.

PARTIAL PLAN LEGEND:

- A - NORTH REPAIR BAYS
- B - SOUTH REPAIR BAYS
- C - LUBE AND WASH BAYS
- D - STORES
- E - OFFICE AREA
- F - MACHINE SHOP
- G - PAINT AREA

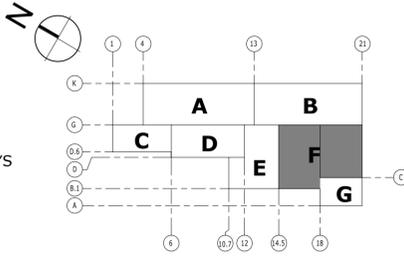

KEY PLAN

NO.	Revision Description	Date

THE INFORMATION, INCLUDING ESTIMATED QUANTITIES OF WORK, SHOWN ON THESE SHEETS IS BASED ON LIMITED INVESTIGATIONS BY THE STATE AND IS IN NO WAY WARRANTED TO INDICATE THE CONDITIONS OF ACTUAL QUANTITIES OF WORK WHICH WILL BE REQUIRED.

DESIGNER/DRAFTER
RHL
CHECKED BY:
RSL
SCALE
1/8" = 1'-0"




SIGNATURE/BLOCK:
[Signature]

PROJECT TITLE
REPAIR FACILITY

TOWN
ROCKY HILL
DRAWING TITLE
PLUMBING DRAINAGE - PART PLAN F


PROJECT NO.
118-0167
DRAWING NO.
PLM-106
SHEET NO.
09.15

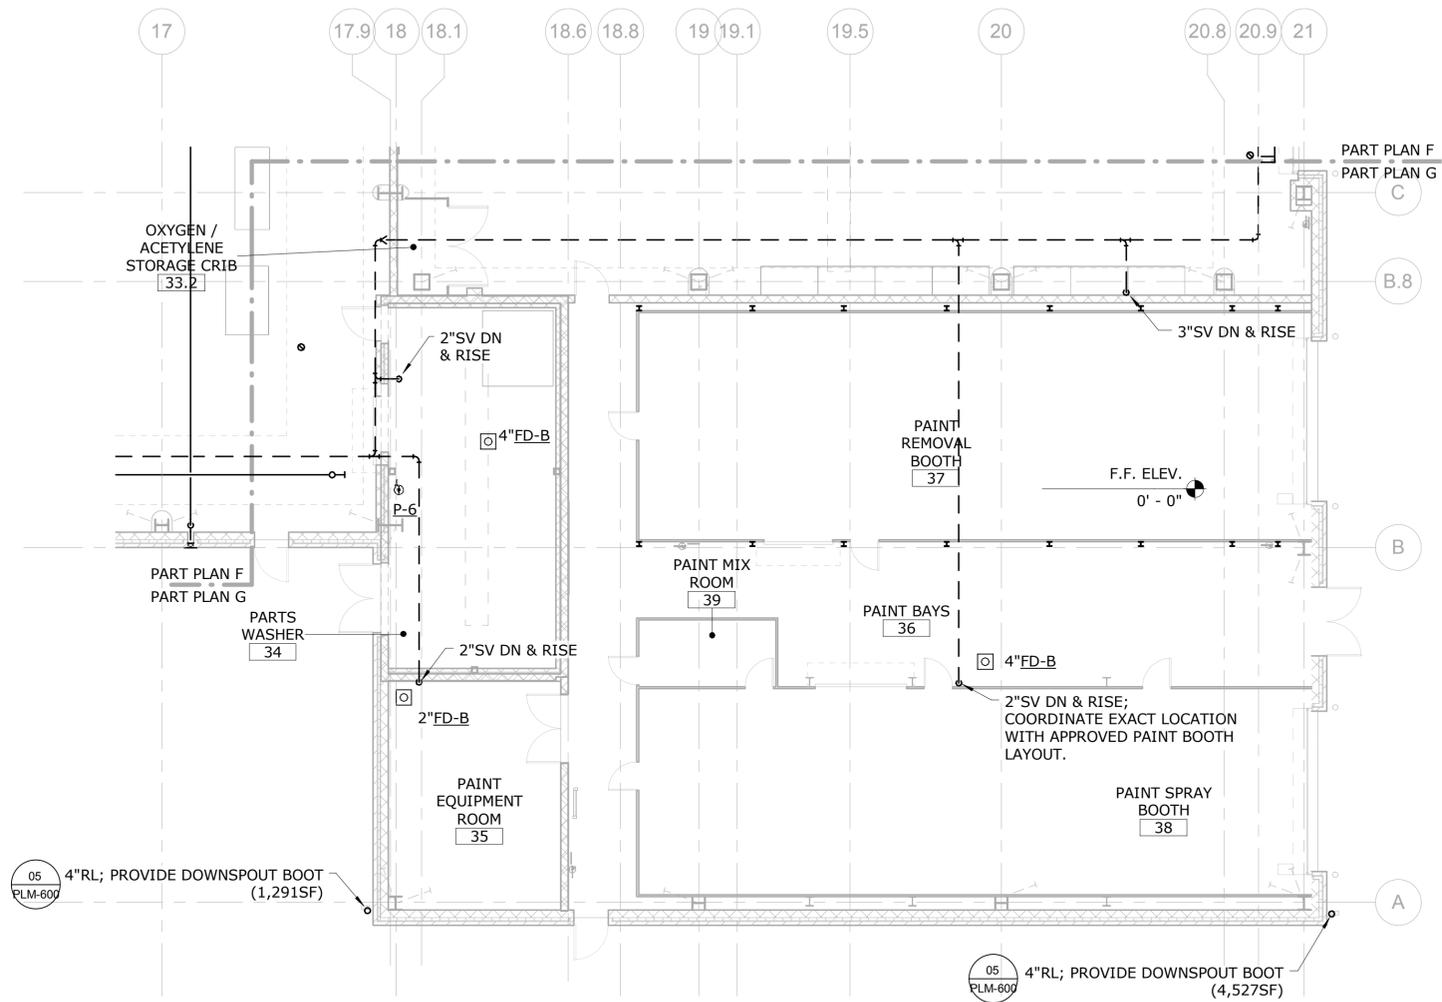

1 PLUMBING - DRAINAGE - PART PLAN G - PAINT AREA
SCALE: 1/8" = 1'-0"

NOTES:
1. REFER TO PLUMBING FIXTURE SCHEDULE ON PLM-700 FOR PIPE SIZES TO FIXTURES.

- PARTIAL PLAN LEGEND:
- A - NORTH REPAIR BAYS
 - B - SOUTH REPAIR BAYS
 - C - LUBE AND WASH BAYS
 - D - STORES
 - E - OFFICE AREA
 - F - MACHINE SHOP
 - G - PAINT AREA

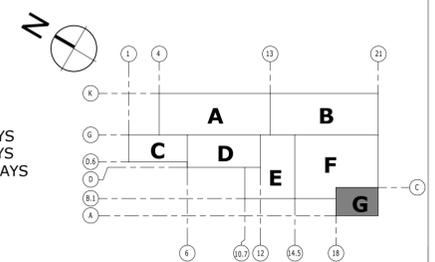

KEY PLAN

NO.	Revision Description	Date

THE INFORMATION, INCLUDING ESTIMATED QUANTITIES OF WORK, SHOWN ON THESE SHEETS IS BASED ON LIMITED INVESTIGATIONS BY THE STATE AND IS IN NO WAY WARRANTED TO INDICATE THE CONDITIONS OF ACTUAL QUANTITIES OF WORK WHICH WILL BE REQUIRED.

Plotted: 10/21/2014 3:41:52 PM

DESIGNER/DRAFTER
RHL

CHECKED BY:
RSL

SCALE
1/8" = 1'-0"



SIGNATURE/BLOCK:

PROJECT TITLE
REPAIR FACILITY


TOWN
ROCKY HILL

DRAWING TITLE
PLUMBING DRAINAGE - PART PLAN G

PROJECT NO.
118-0167

DRAWING NO.
PLM-107


SHEET NO.
09.16

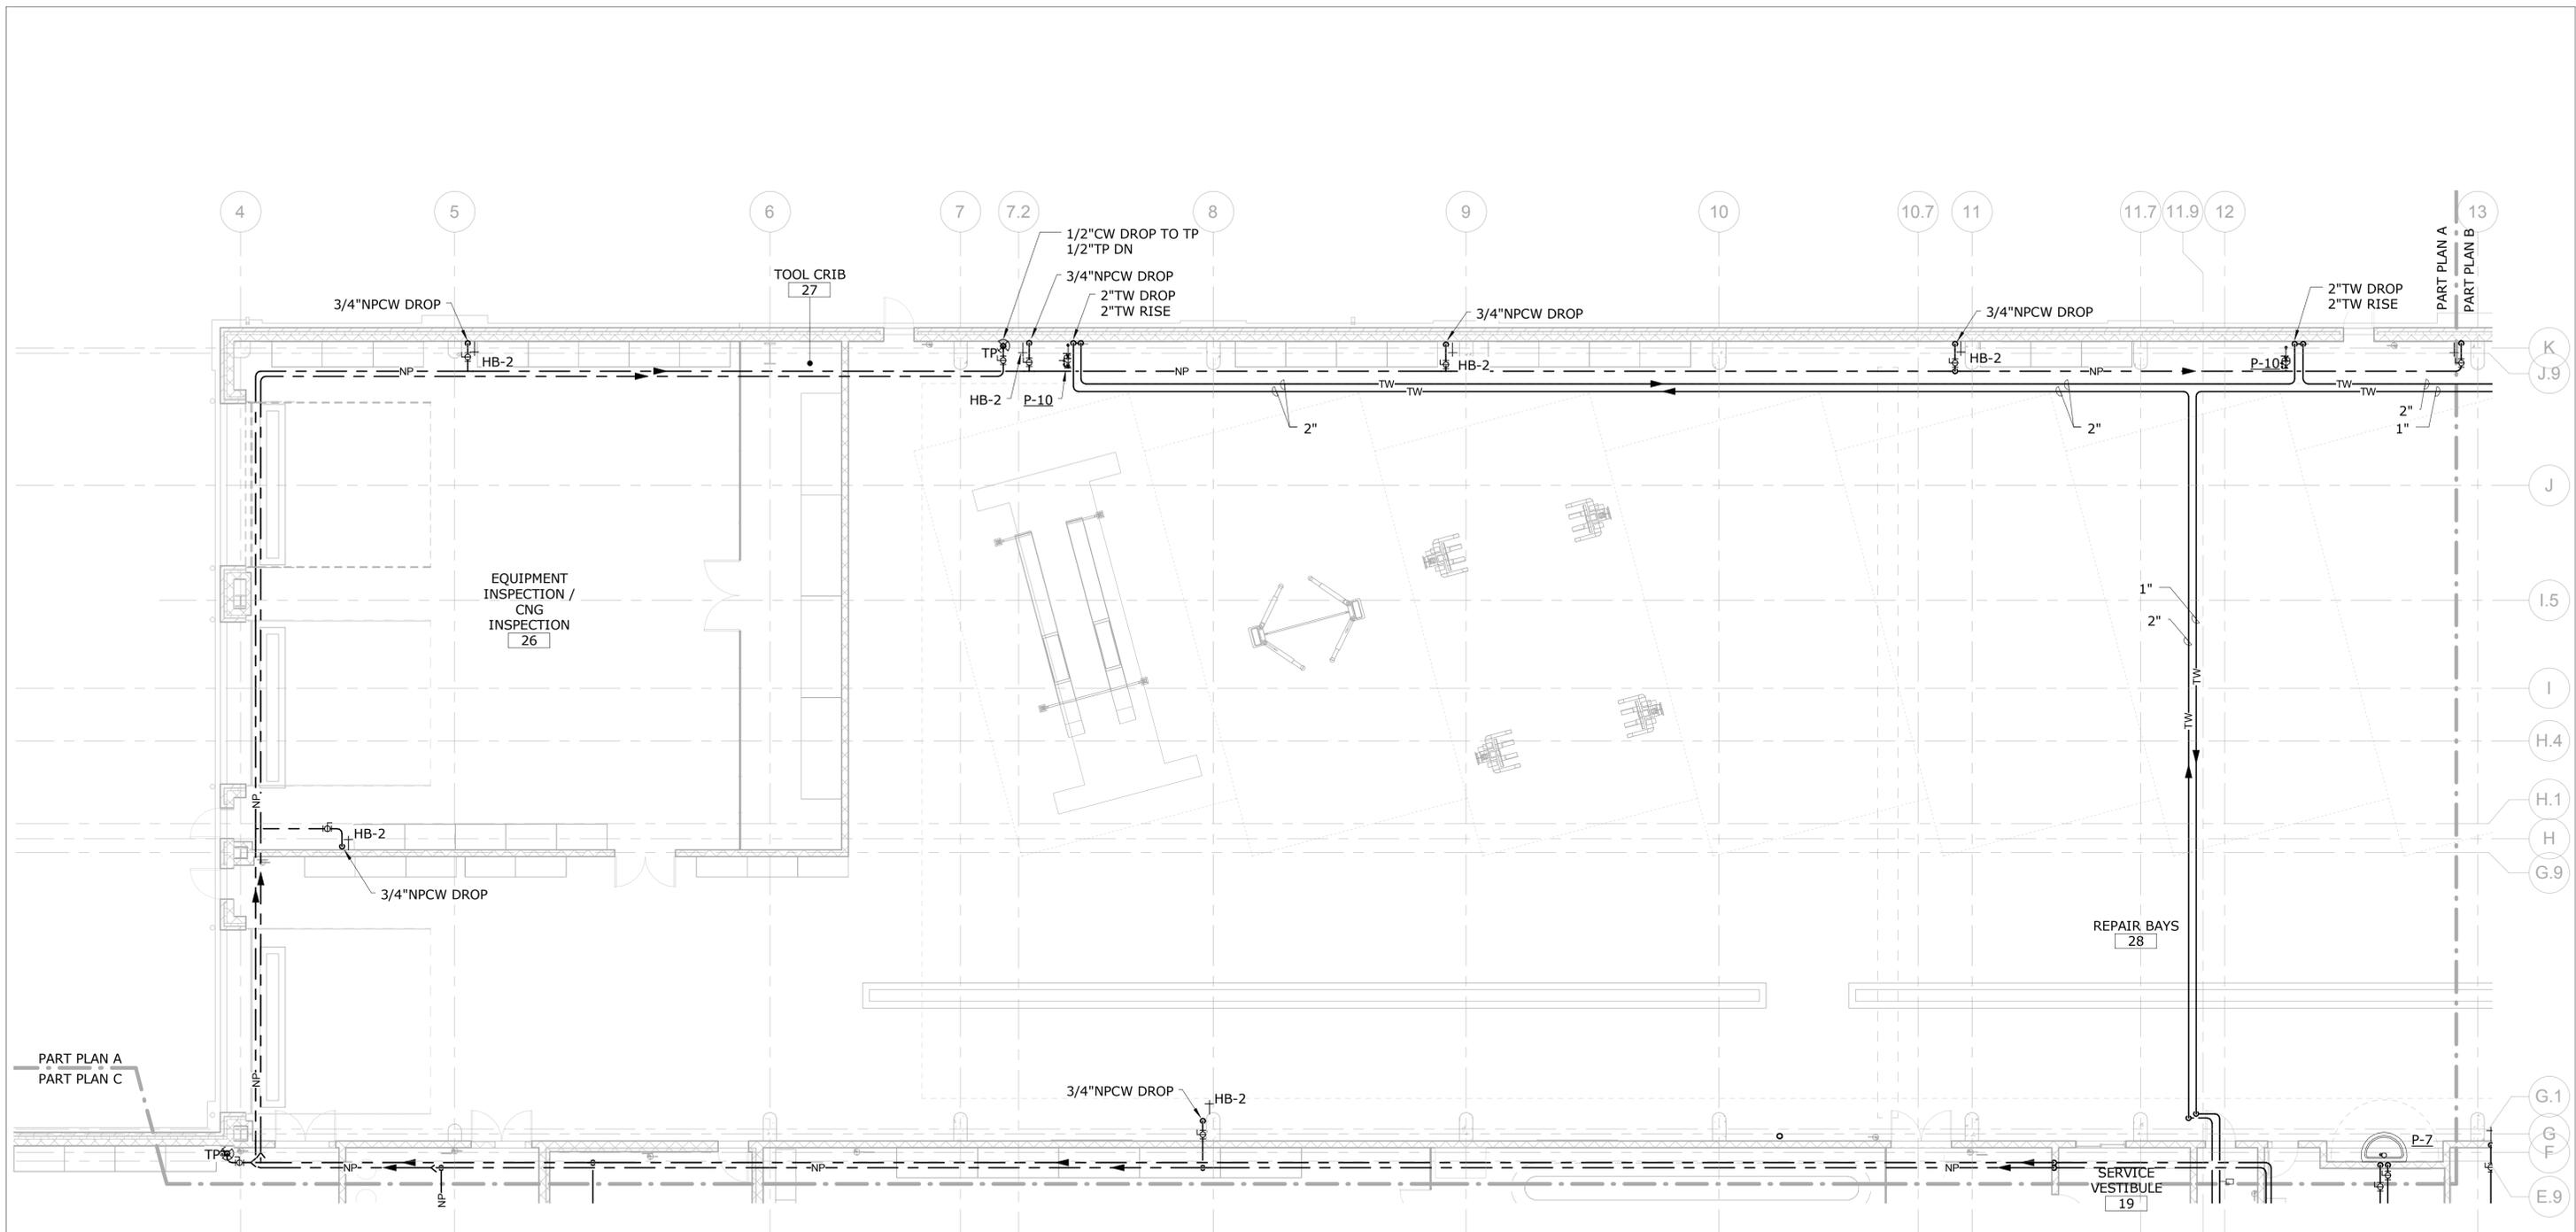

1 PLUMBING - WATER DIST. - PART PLAN A - NORTH REPAIR BAYS
SCALE: 1/8" = 1'-0"

NOTES:
1. REFER TO PLUMBING FIXTURE SCHEDULE ON PLM-700 FOR PIPE SIZES TO FIXTURES.

- PARTIAL PLAN LEGEND:
- A - NORTH REPAIR BAYS
 - B - SOUTH REPAIR BAYS
 - C - LUBE AND WASH BAYS
 - D - STORES
 - E - OFFICE AREA
 - F - MACHINE SHOP
 - G - PAINT AREA

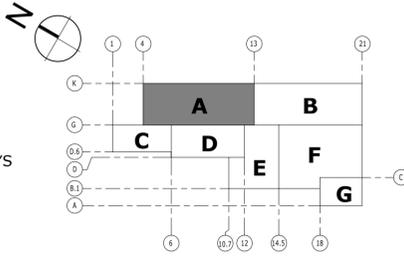

NO.	Revision Description	Date

THE INFORMATION, INCLUDING ESTIMATED QUANTITIES OF WORK, SHOWN ON THESE SHEETS IS BASED ON LIMITED INVESTIGATIONS BY THE STATE AND IS IN NO WAY WARRANTED TO INDICATE THE CONDITIONS OF ACTUAL QUANTITIES OF WORK WHICH WILL BE REQUIRED.

Plotted: 10/21/2014 3:42:00 PM

DESIGNER/DRAFTER
RHL

CHECKED BY:
RSL

SCALE
1/8" = 1'-0"



SIGNATURE/BLOCK:

PROJECT TITLE
REPAIR FACILITY


TOWN
ROCKY HILL

DRAWING TITLE
PLUMBING WATER DIST. - PART PLAN A

PROJECT NO.
118-0167

DRAWING NO.
PLM-201


SHEET NO.
09.17

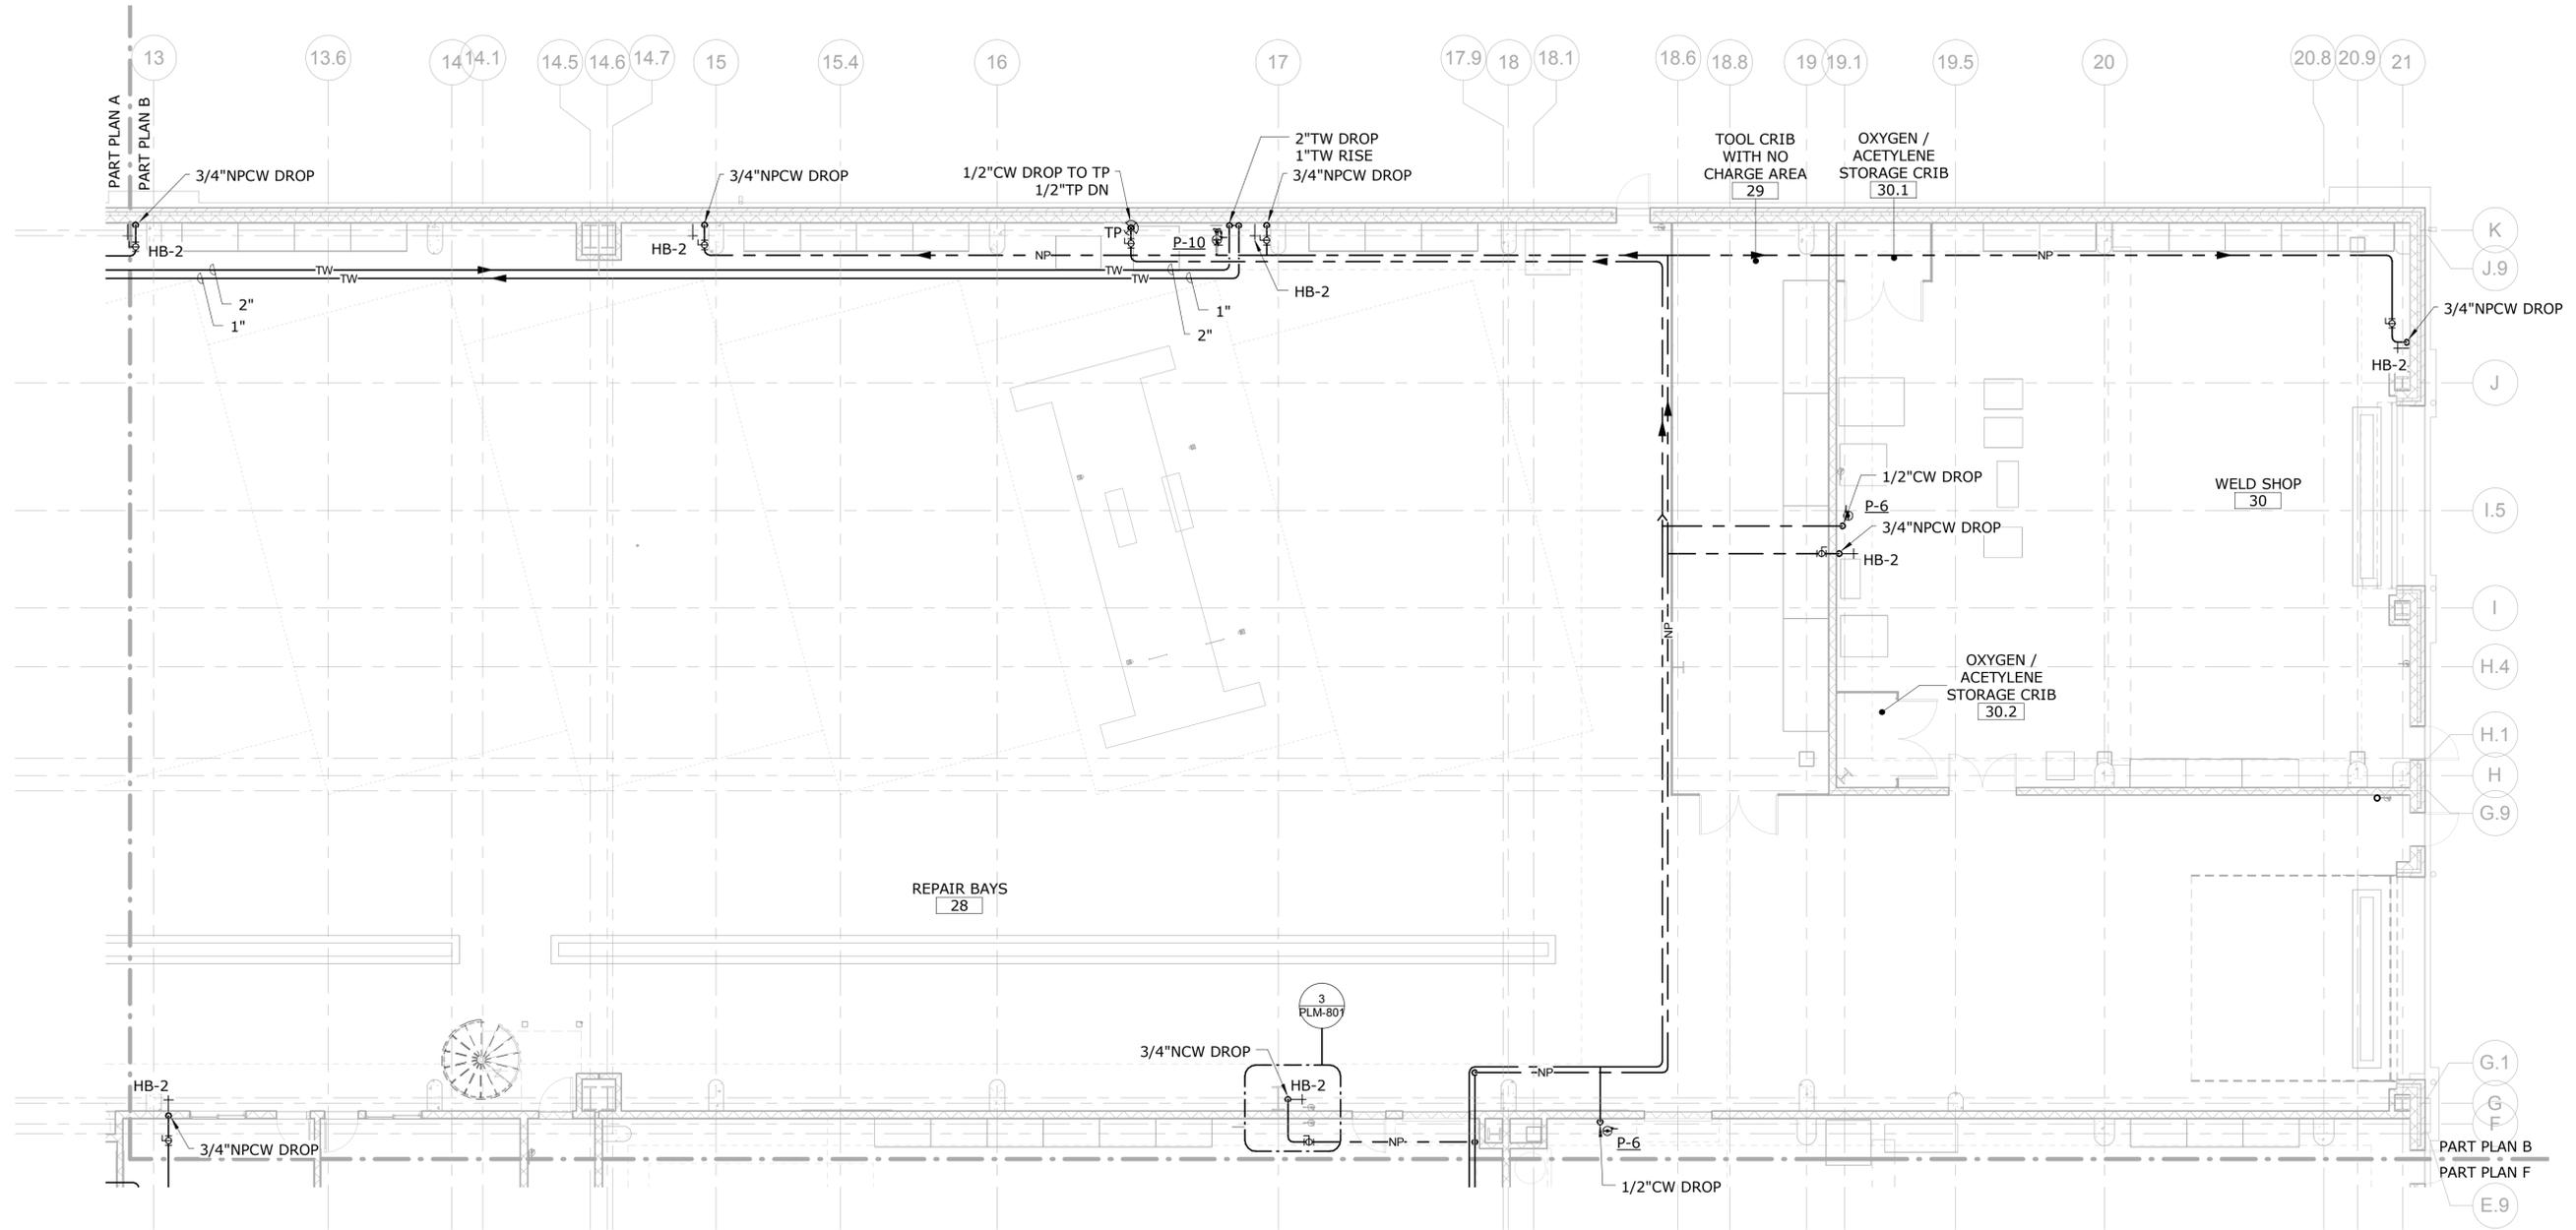

1 PLUMBING - WATER DIST. - PART PLAN B - SOUTH REPAIR BAYS
SCALE: 1/8" = 1'-0"

NOTES:
1. REFER TO PLUMBING FIXTURE SCHEDULE ON PLM-700 FOR PIPE SIZES TO FIXTURES.

- PARTIAL PLAN LEGEND:
- A - NORTH REPAIR BAYS
 - B - SOUTH REPAIR BAYS
 - C - LUBE AND WASH BAYS
 - D - STORES
 - E - OFFICE AREA
 - F - MACHINE SHOP
 - G - PAINT AREA

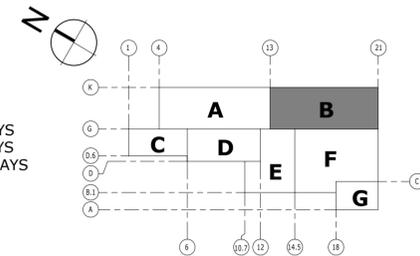

KEY PLAN

NO.	Revision Description	Date

THE INFORMATION, INCLUDING ESTIMATED QUANTITIES OF WORK, SHOWN ON THESE SHEETS IS BASED ON LIMITED INVESTIGATIONS BY THE STATE AND IS IN NO WAY WARRANTED TO INDICATE THE CONDITIONS OF ACTUAL QUANTITIES OF WORK WHICH WILL BE REQUIRED.

DESIGNER/DRAFTER
RHL
CHECKED BY:
RSL
SCALE
1/8" = 1'-0"



SIGNATURE/BLOCK:
[Signature]


PROJECT TITLE
REPAIR FACILITY

TOWN
ROCKY HILL
DRAWING TITLE
PLUMBING WATER DIST. - PART PLAN B

PROJECT NO.
118-0167
DRAWING NO.
PLM-202
SHEET NO.
09.18

Plotted: 10/21/2014 3:42:05 PM


File Name: MPPP_CTDOT_Rocky Hill Repair Facility_Central.rvt

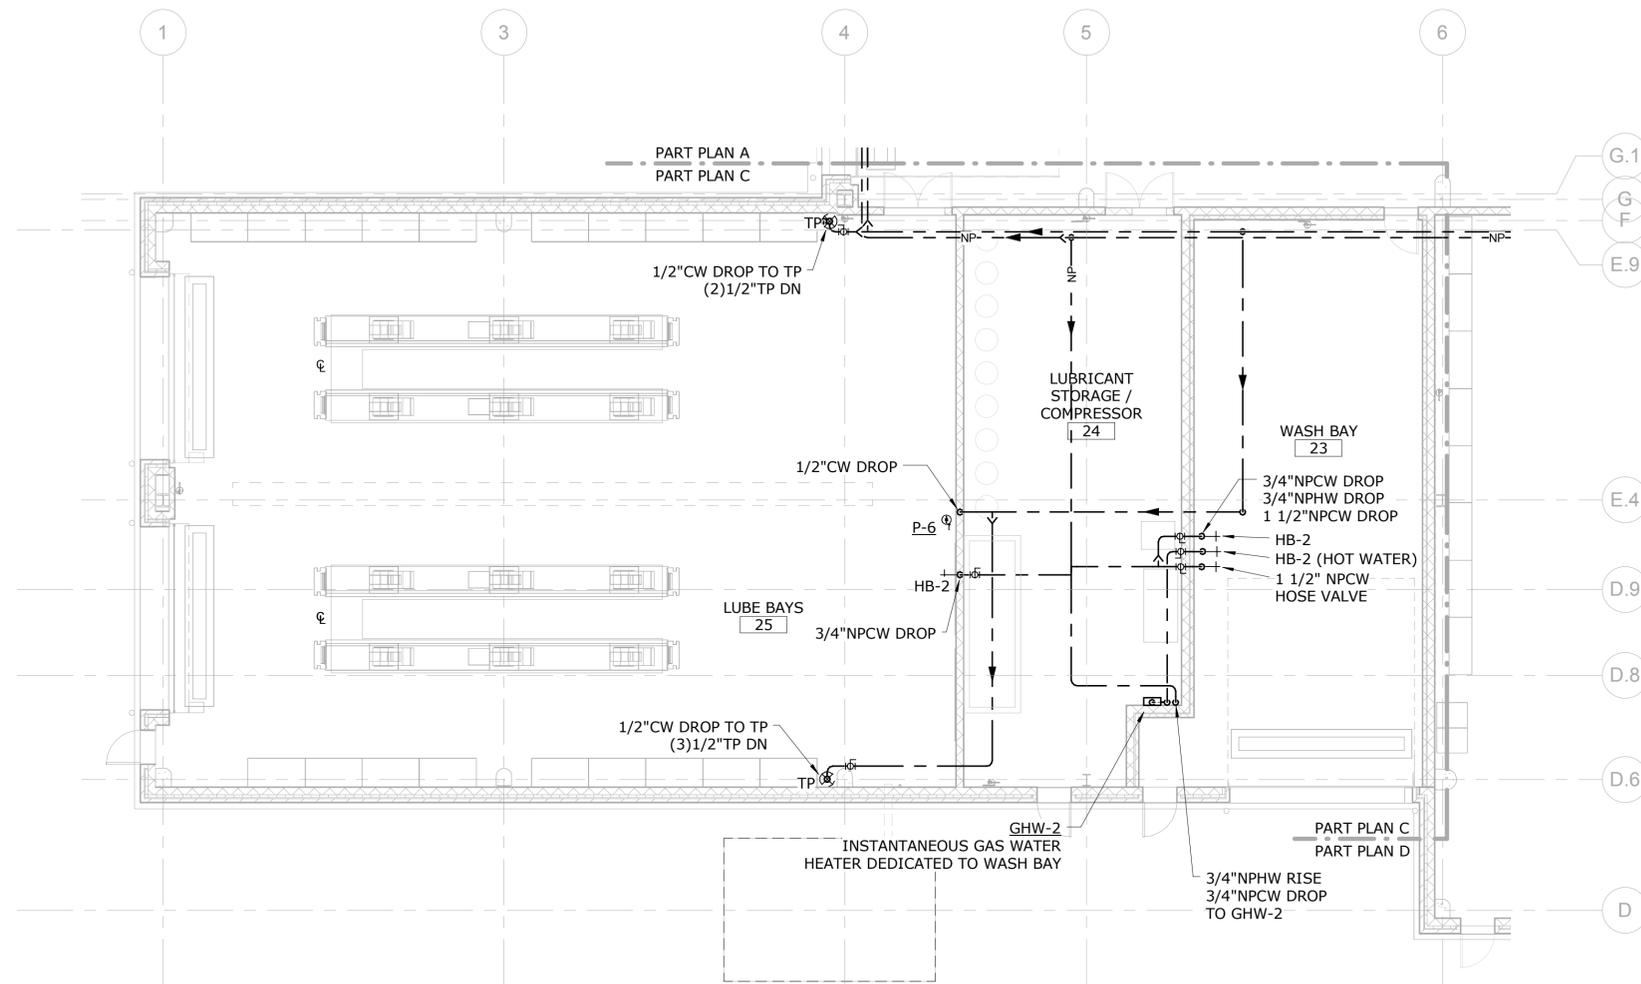

1 PLUMBING - WATER DIST. - PART PLAN C - LUBE & WASH BAYS
SCALE: 1/8" = 1'-0"

NOTES:
1. REFER TO PLUMBING FIXTURE SCHEDULE ON PLM-700 FOR PIPE SIZES TO FIXTURES.

- PARTIAL PLAN LEGEND:
- A - NORTH REPAIR BAYS
 - B - SOUTH REPAIR BAYS
 - C - LUBE AND WASH BAYS
 - D - STORES
 - E - OFFICE AREA
 - F - MACHINE SHOP
 - G - PAINT AREA

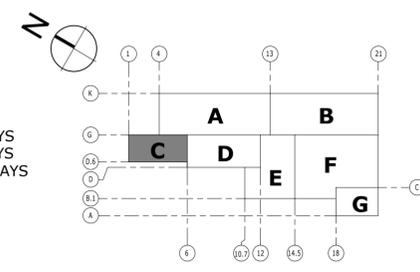

NO.	Revision Description	Date

THE INFORMATION, INCLUDING ESTIMATED QUANTITIES OF WORK, SHOWN ON THESE SHEETS IS BASED ON LIMITED INVESTIGATIONS BY THE STATE AND IS IN NO WAY WARRANTED TO INDICATE THE CONDITIONS OF ACTUAL QUANTITIES OF WORK WHICH WILL BE REQUIRED.

Plotted: 10/21/2014 3:42:08 PM

DESIGNER/DRAFTER
RHL

CHECKED BY:
RSL

SCALE
1/8" = 1'-0"



SIGNATURE/BLOCK:
[Signature]

PROJECT TITLE
REPAIR FACILITY


TOWN
ROCKY HILL

DRAWING TITLE
PLUMBING WATER DIST. - PART PLAN C

PROJECT NO.
118-0167

DRAWING NO.
PLM-203

SHEET NO.
09.19

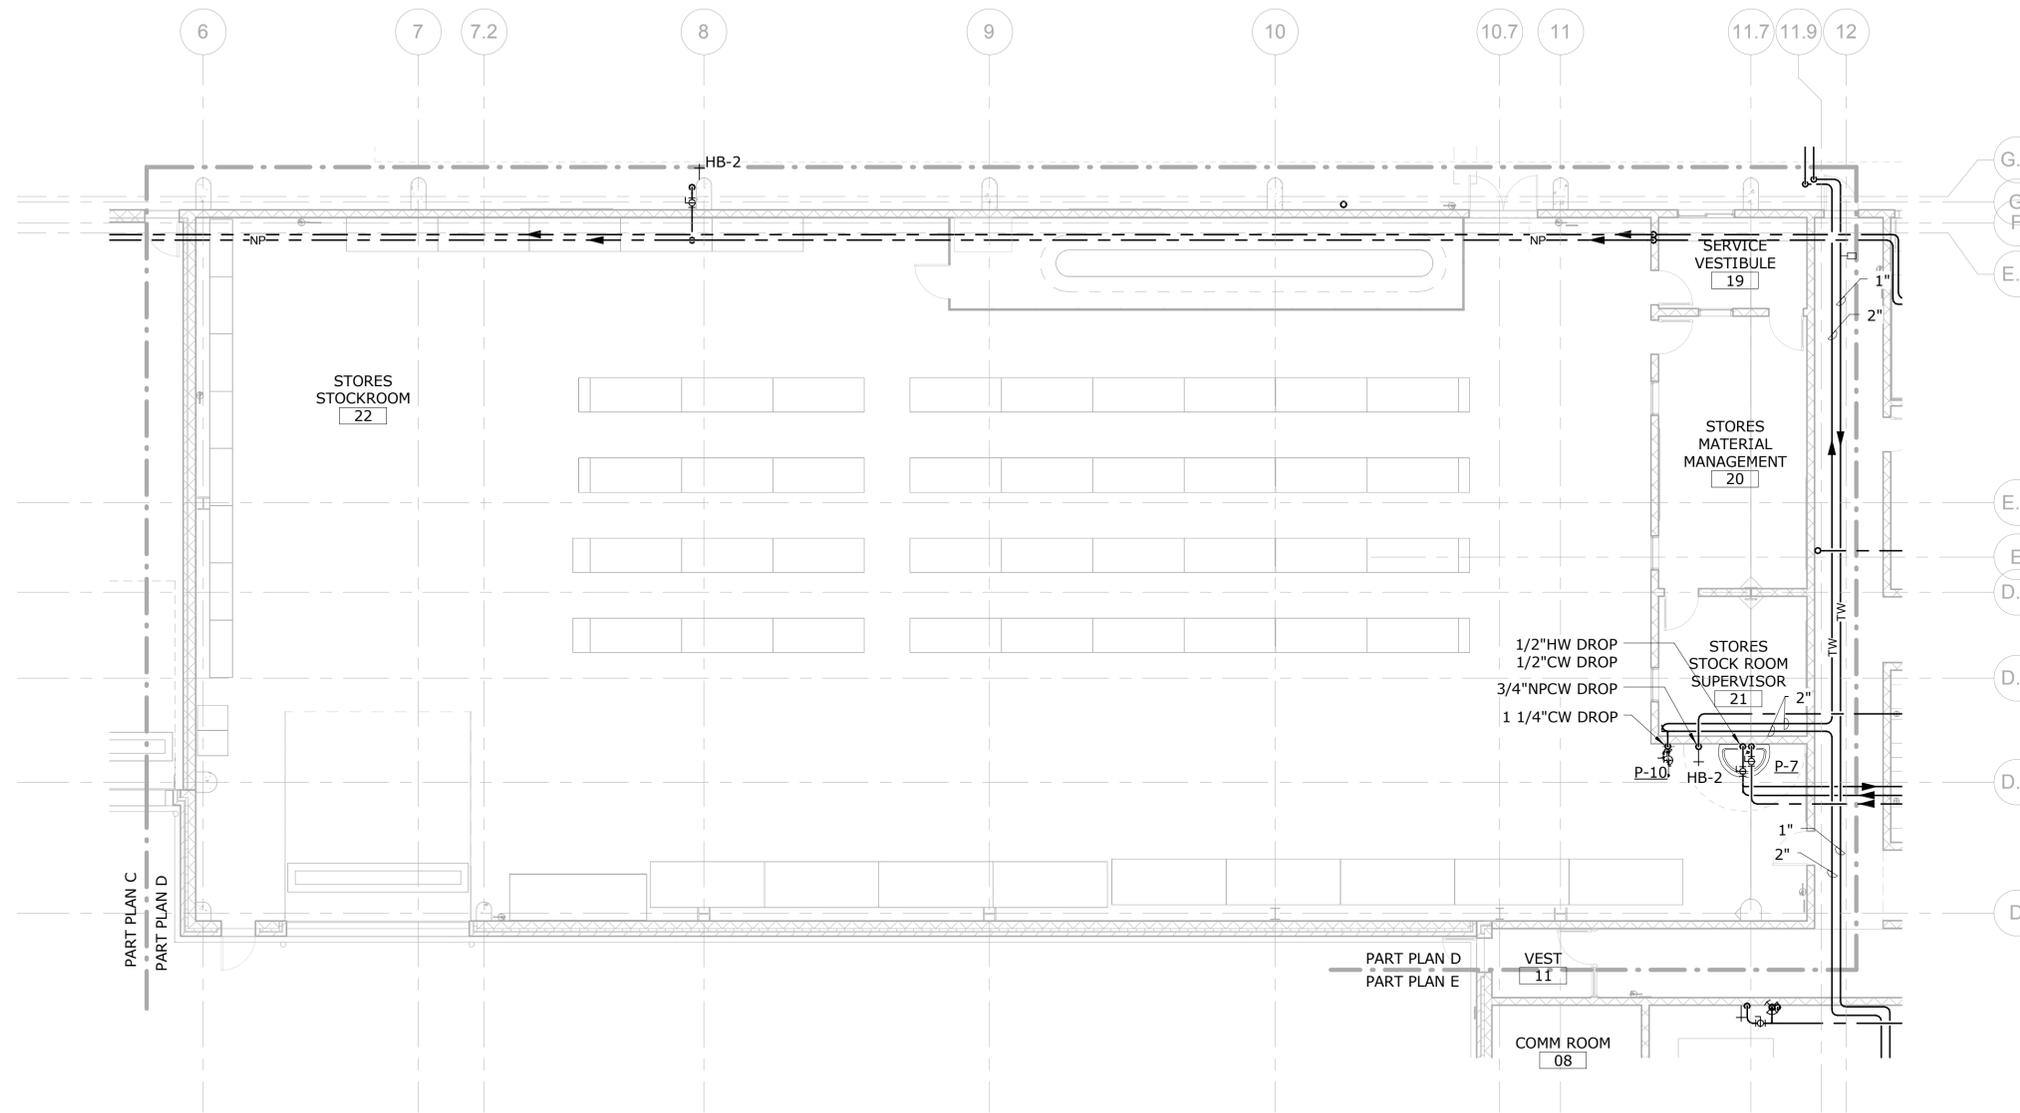


1 PLUMBING - WATER DIST. - PART PLAN D - STORES
SCALE: 1/8" = 1'-0"

NOTES:
1. REFER TO PLUMBING FIXTURE SCHEDULE ON PLM-700 FOR PIPE SIZES TO FIXTURES.

PARTIAL PLAN LEGEND:

- A - NORTH REPAIR BAYS
- B - SOUTH REPAIR BAYS
- C - LUBE AND WASH BAYS
- D - STORES
- E - OFFICE AREA
- F - MACHINE SHOP
- G - PAINT AREA

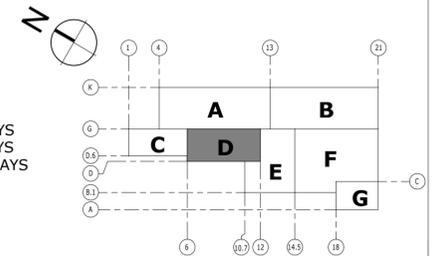

KEY PLAN

NO.	Revision Description	Date

THE INFORMATION, INCLUDING ESTIMATED QUANTITIES OF WORK, SHOWN ON THESE SHEETS IS BASED ON LIMITED INVESTIGATIONS BY THE STATE AND IS IN NO WAY WARRANTED TO INDICATE THE CONDITIONS OF ACTUAL QUANTITIES OF WORK WHICH WILL BE REQUIRED.

Plotted: 10/21/2014 3:42:12 PM

DESIGNER/DRAFTER
RHL

CHECKED BY:
RSL

SCALE
1/8" = 1'-0"



SIGNATURE/BLOCK:

PROJECT TITLE
REPAIR FACILITY


TOWN
ROCKY HILL

DRAWING TITLE
PLUMBING WATER DIST. - PART PLAN D


PROJECT NO.
118-0167

DRAWING NO.
PLM-204

SHEET NO.
09.20

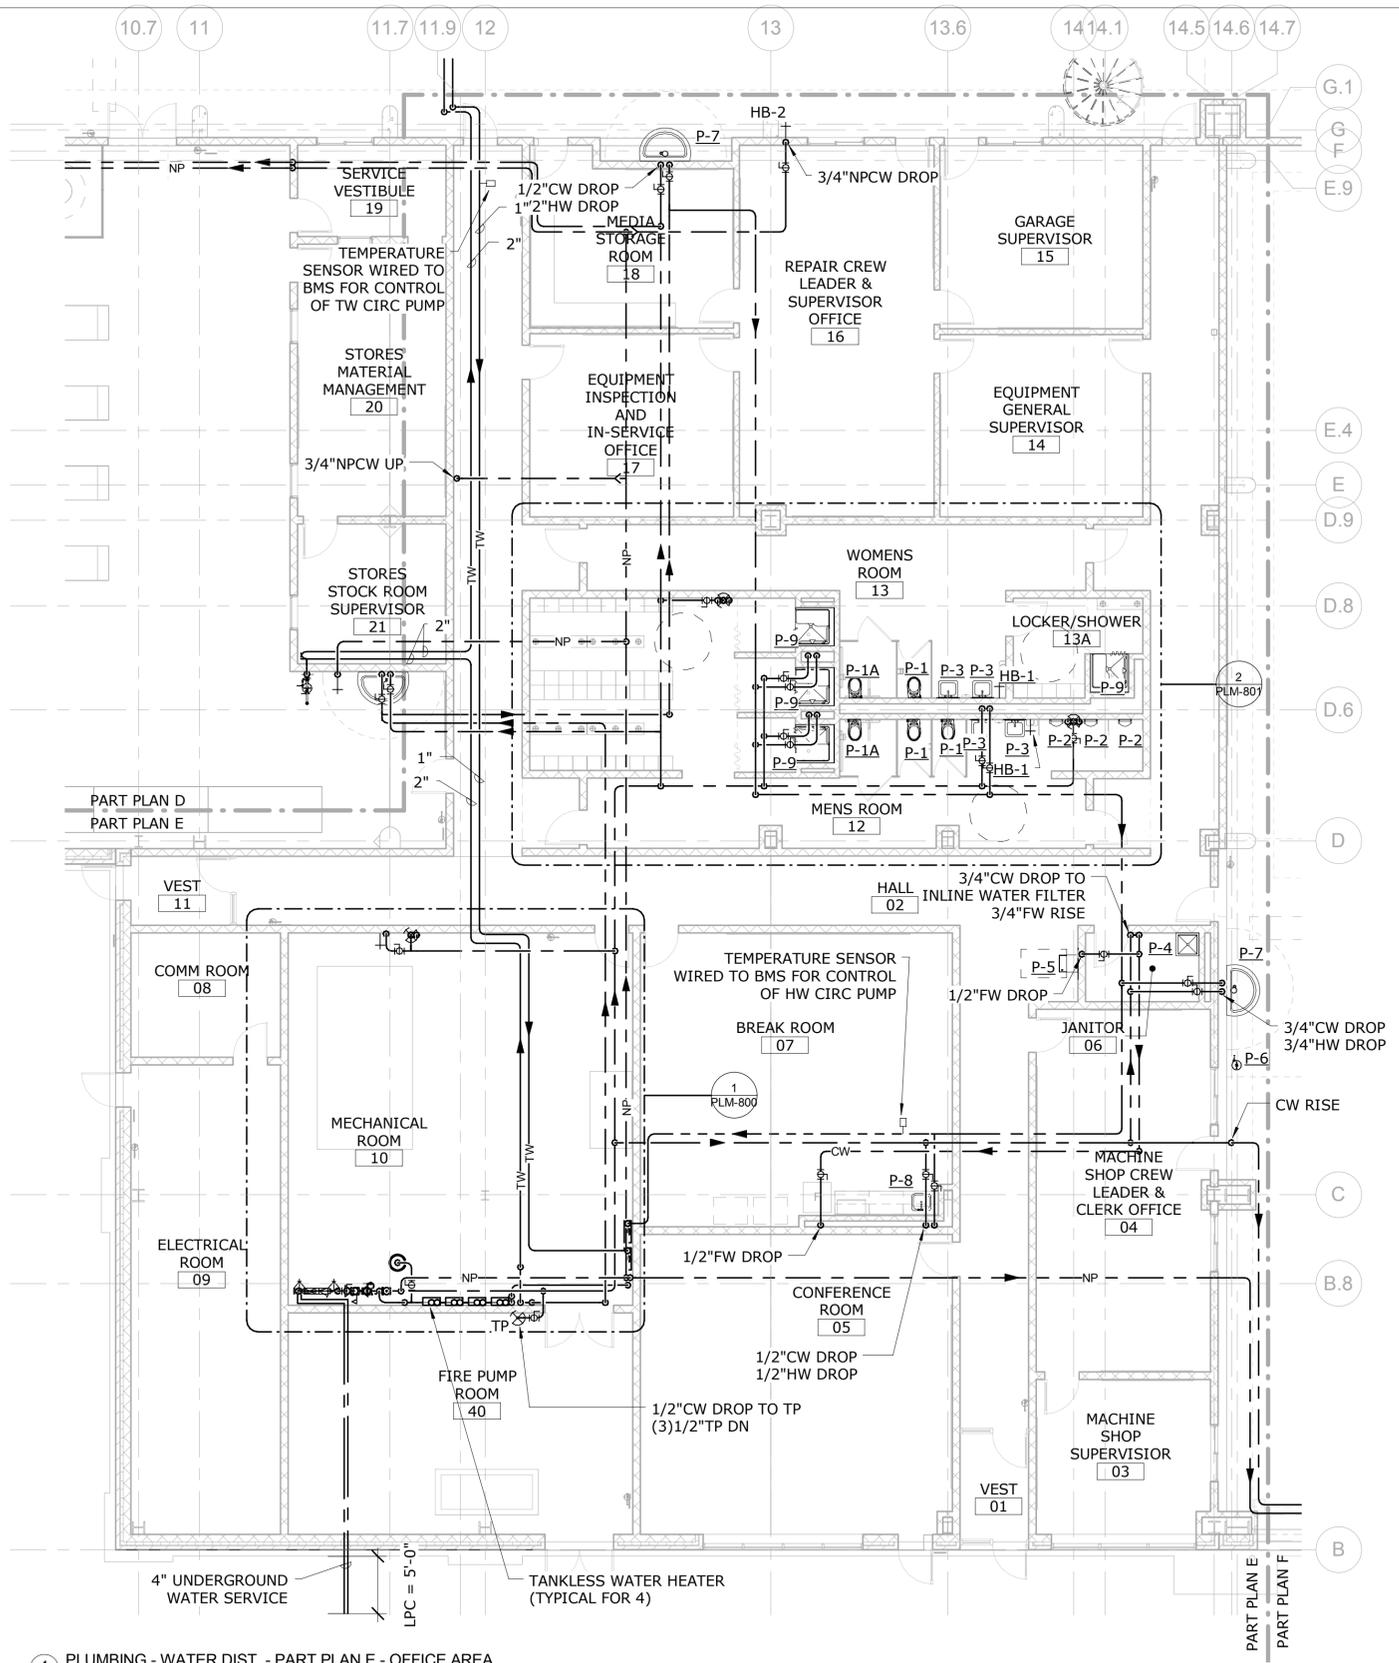

1 PLUMBING - WATER DIST. - PART PLAN E - OFFICE AREA
SCALE: 1/8" = 1'-0"

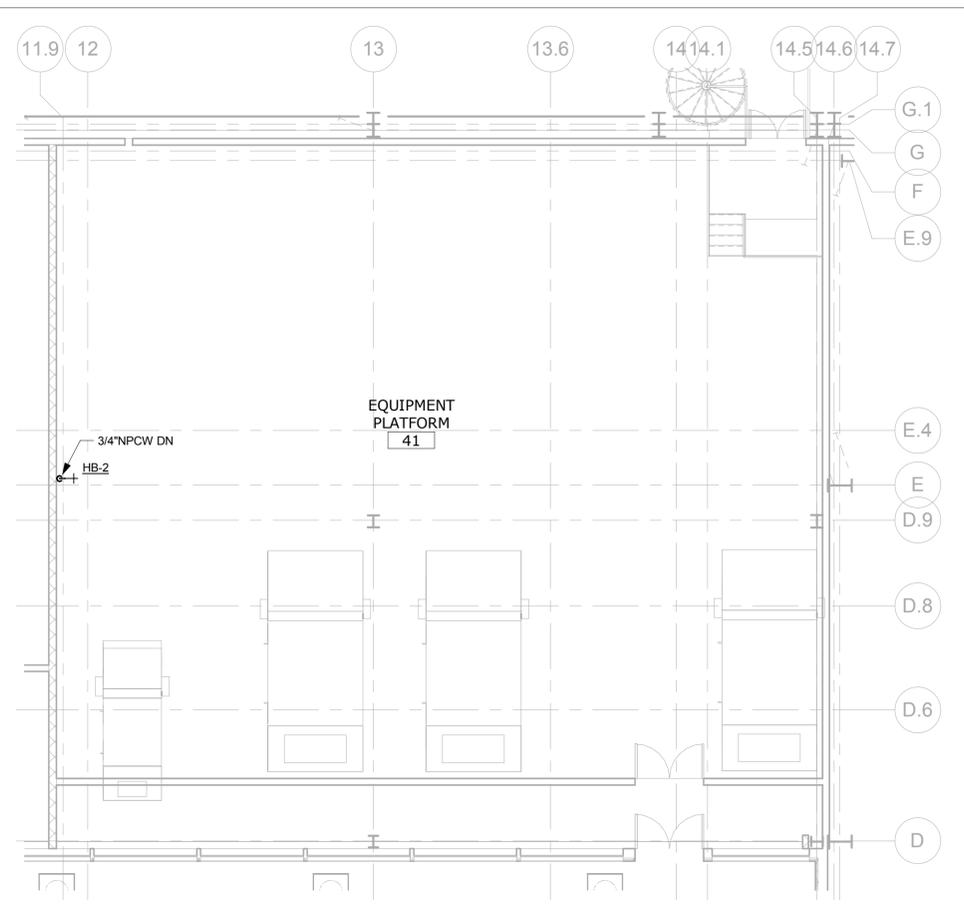


2 PLUMBING - WATER DIST. - EQUIPMENT PLATFORM
SCALE: 1/8" = 1'-0"

NOTES:
1. REFER TO PLUMBING FIXTURE SCHEDULE ON PLM-700 FOR PIPE SIZES TO FIXTURES.

PARTIAL PLAN LEGEND:

- A - NORTH REPAIR BAYS
- B - SOUTH REPAIR BAYS
- C - LUBE AND WASH BAYS
- D - STORES
- E - OFFICE AREA
- F - MACHINE SHOP
- G - PAINT AREA

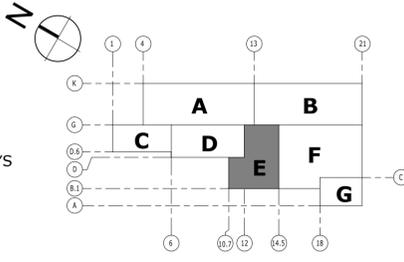

KEY PLAN

NO.	Revision Description	Date

THE INFORMATION, INCLUDING ESTIMATED QUANTITIES OF WORK, SHOWN ON THESE SHEETS IS BASED ON LIMITED INVESTIGATIONS BY THE STATE AND IS IN NO WAY WARRANTED TO INDICATE THE CONDITIONS OF ACTUAL QUANTITIES OF WORK WHICH WILL BE REQUIRED.

DESIGNER/DRAFTER
RHL
CHECKED BY:
RSL
SCALE
1/8" = 1'-0"




SIGNATURE/BLOCK:
[Signature]


PROJECT TITLE
REPAIR FACILITY

TOWN
ROCKY HILL
DRAWING TITLE
PLUMBING WATER DIST. - PART PLAN E & PLATFORM

PROJECT NO.
118-0167
DRAWING NO.
PLM-205
SHEET NO.
09.21

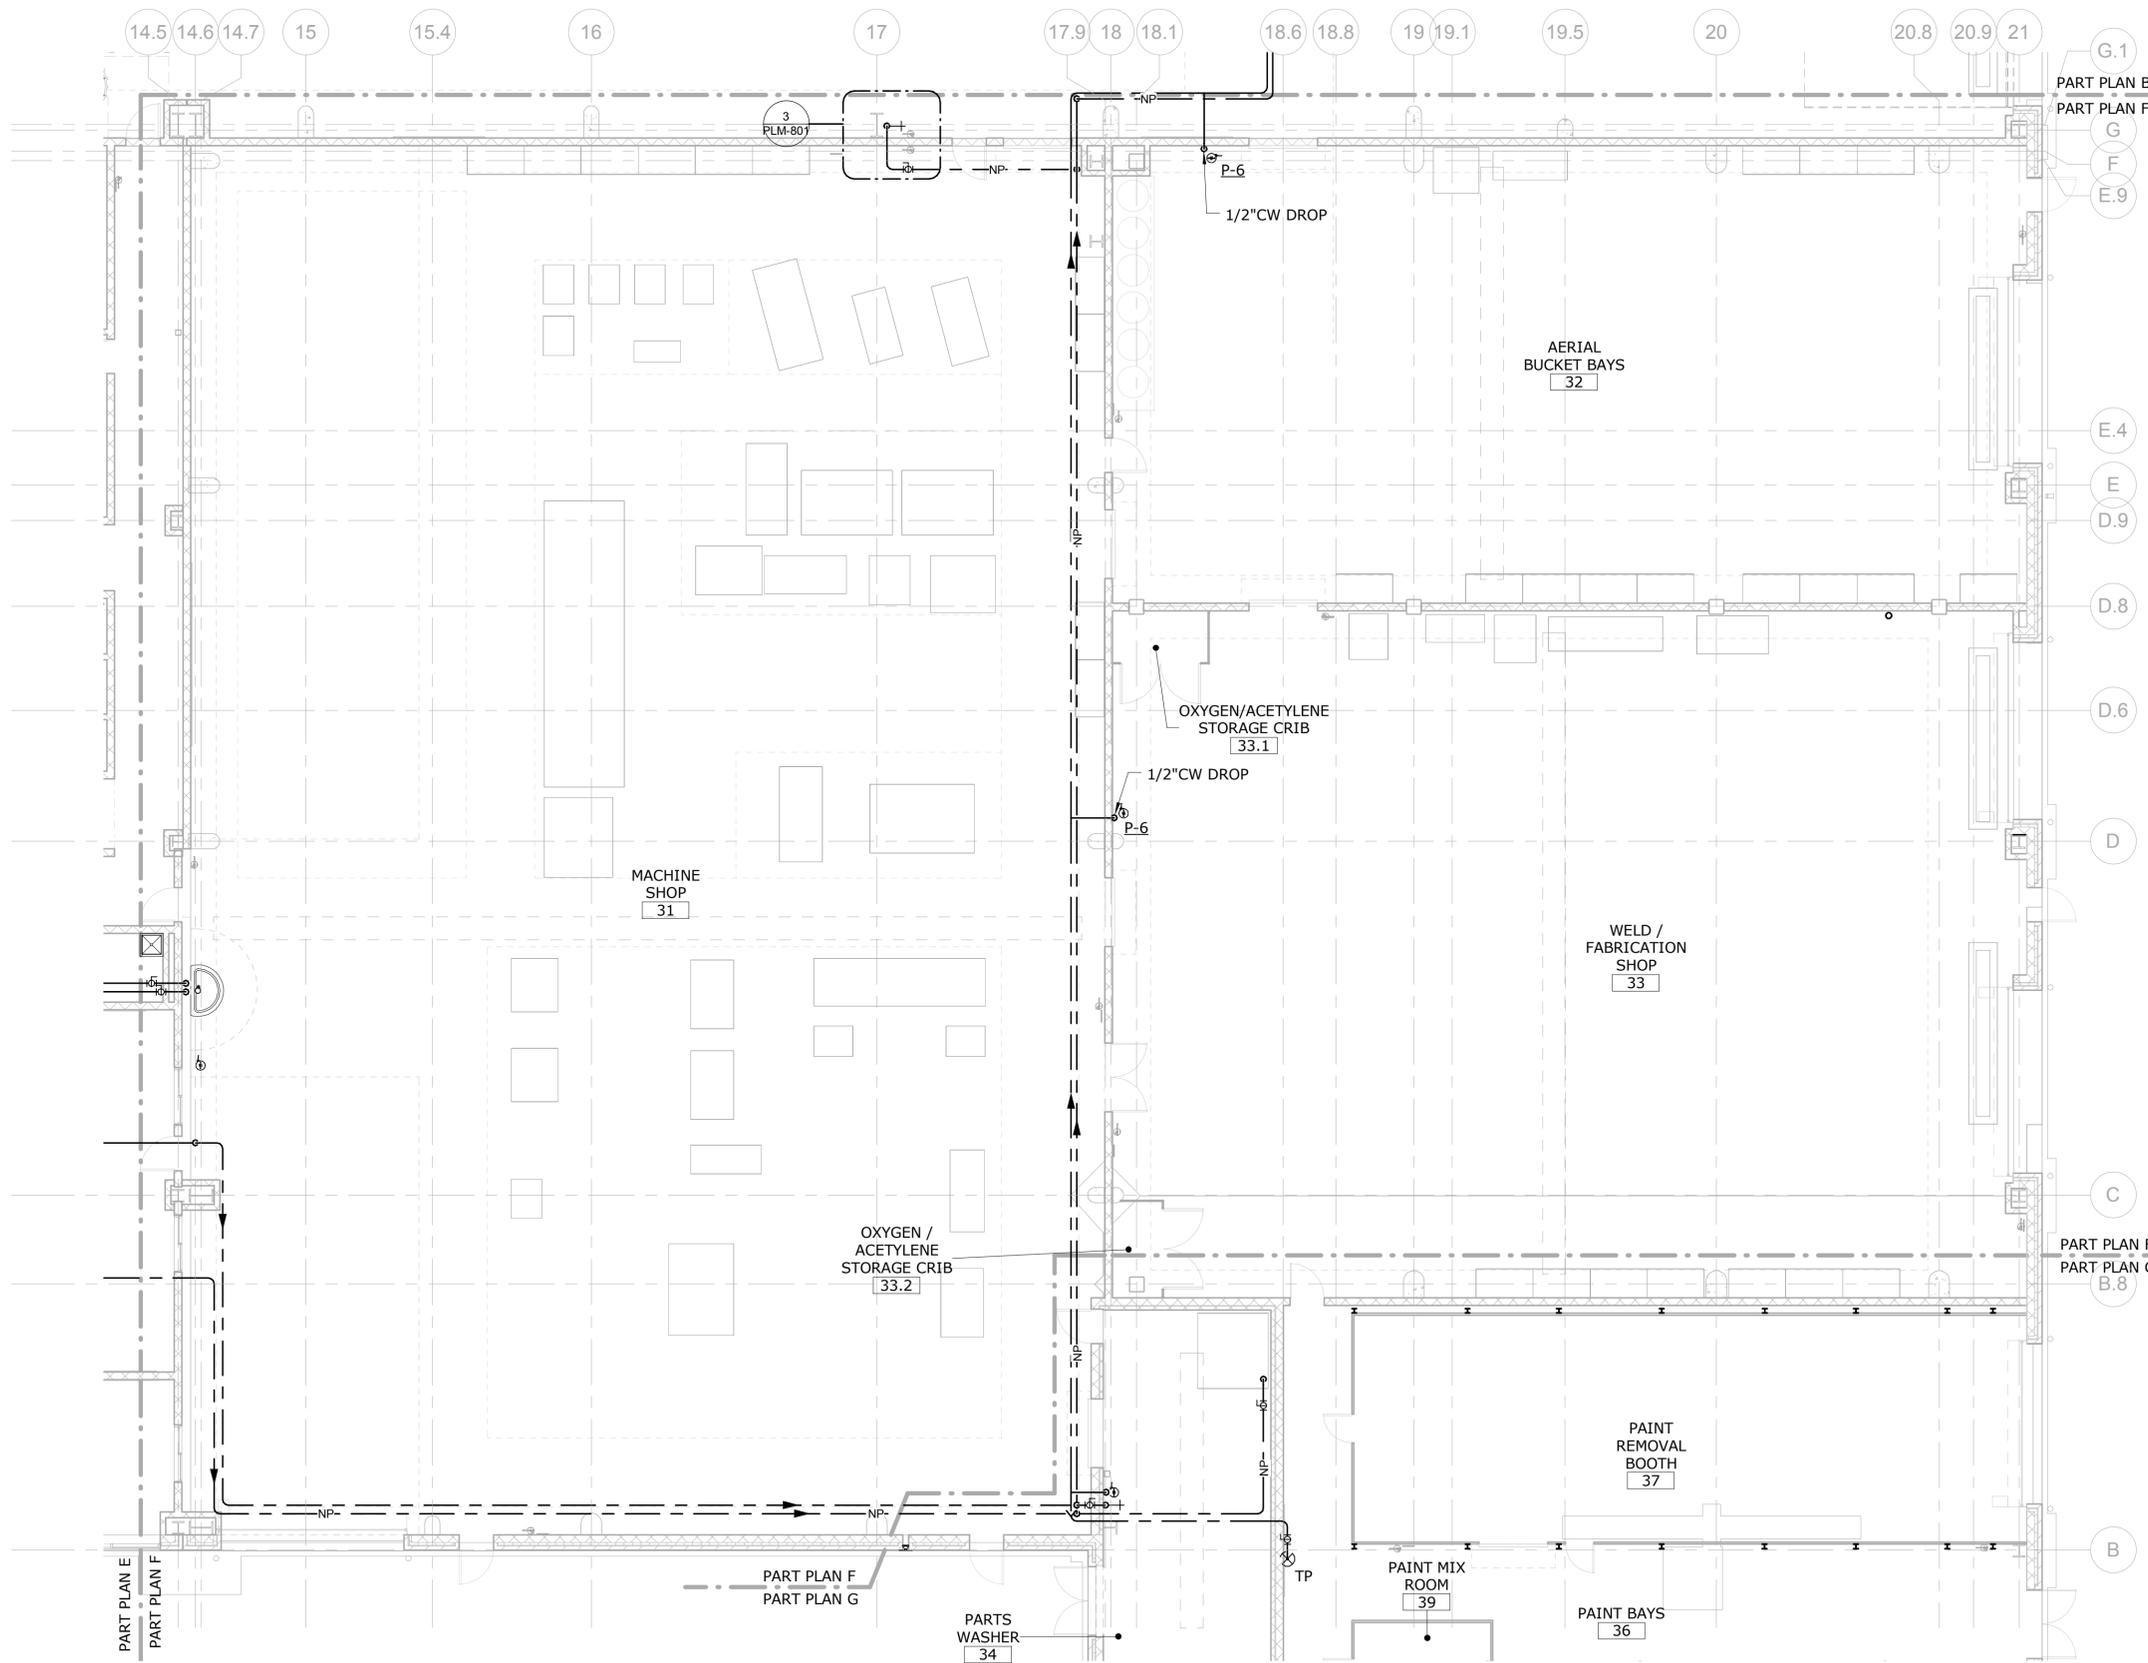

NOTES:
 1. REFER TO PLUMBING FIXTURE SCHEDULE ON PLM-700 FOR PIPE SIZES TO FIXTURES.

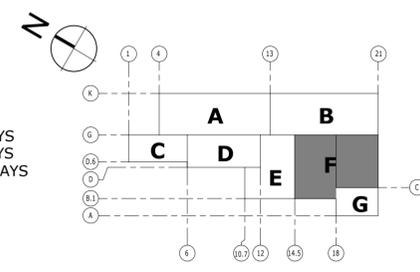

- PARTIAL PLAN LEGEND:**
- A - NORTH REPAIR BAYS
 - B - SOUTH REPAIR BAYS
 - C - LUBE AND WASH BAYS
 - D - STORES
 - E - OFFICE AREA
 - F - MACHINE SHOP
 - G - PAINT AREA

1 PLUMBING - WATER DIST. - PART PLAN F - MACHINE SHOP
 SCALE: 1/8" = 1'-0"

NO.	Revision Description	Date

THE INFORMATION, INCLUDING ESTIMATED QUANTITIES OF WORK, SHOWN ON THESE SHEETS IS BASED ON LIMITED INVESTIGATIONS BY THE STATE AND IS IN NO WAY WARRANTED TO INDICATE THE CONDITIONS OF ACTUAL QUANTITIES OF WORK WHICH WILL BE REQUIRED.

DESIGNER/DRAFTER
RHL
 CHECKED BY:
RSL
 SCALE
 1/8" = 1'-0"




SIGNATURE/BLOCK:


PROJECT TITLE
REPAIR FACILITY

TOWN
ROCKY HILL
 DRAWING TITLE
PLUMBING WATER DIST. - PART PLAN F

PROJECT NO.
118-0167
 DRAWING NO.
PLM-206
 SHEET NO.
09.22

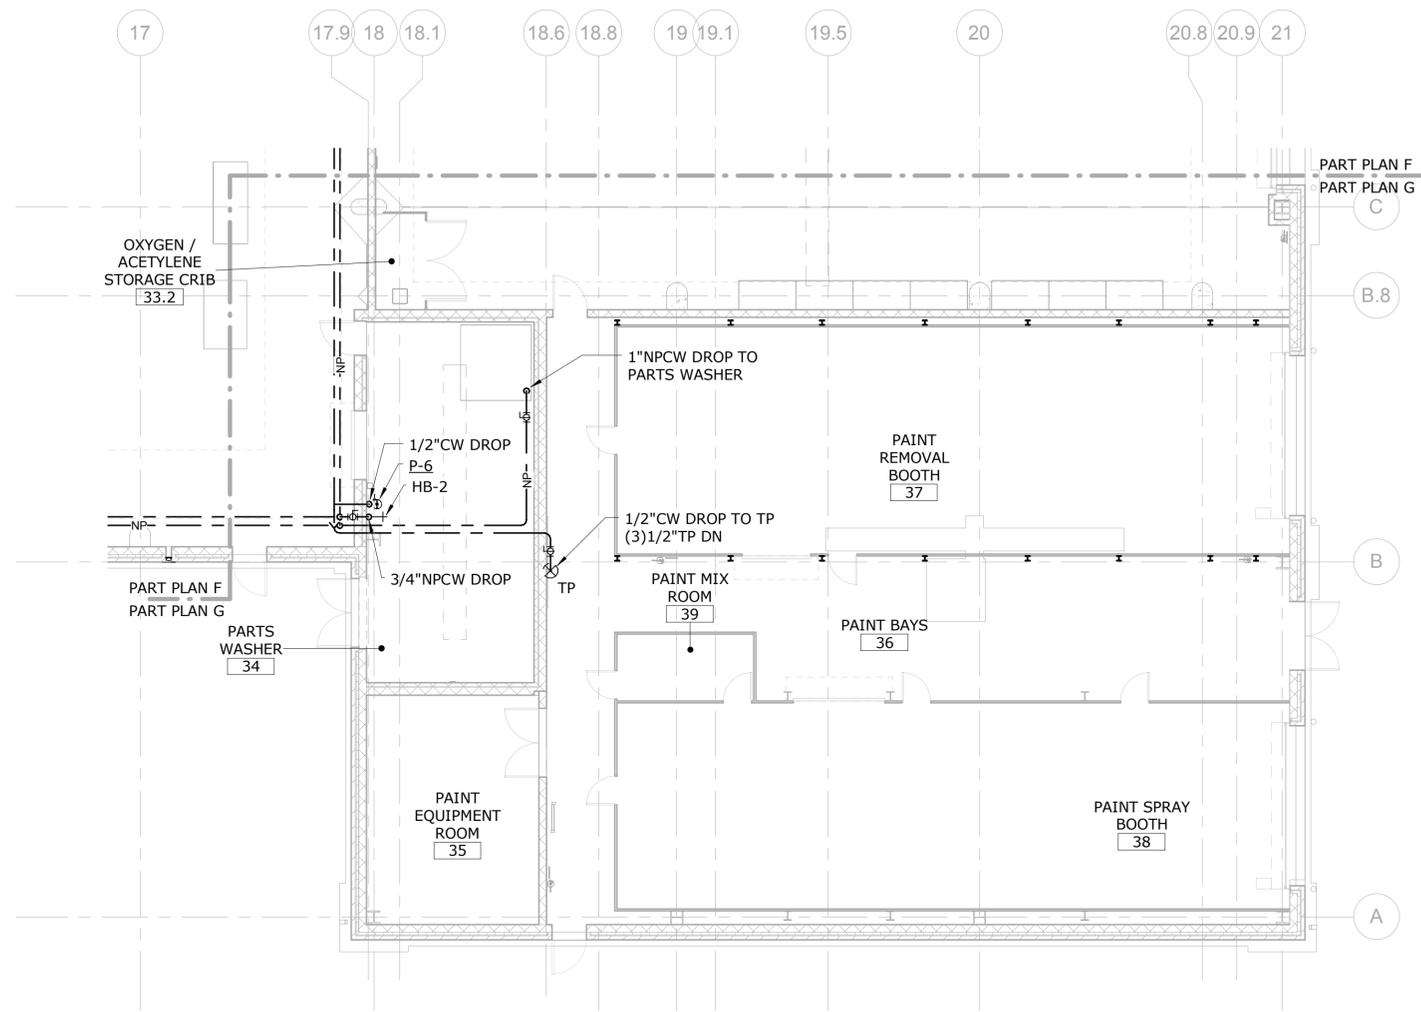


1 PLUMBING - WATER DIST. - PART PLAN G - PAINT AREA
SCALE: 1/8" = 1'-0"

NOTES:
1. REFER TO PLUMBING FIXTURE SCHEDULE ON PLM-700 FOR PIPE SIZES TO FIXTURES.

PARTIAL PLAN LEGEND:

- A - NORTH REPAIR BAYS
- B - SOUTH REPAIR BAYS
- C - LUBE AND WASH BAYS
- D - STORES
- E - OFFICE AREA
- F - MACHINE SHOP
- G - PAINT AREA

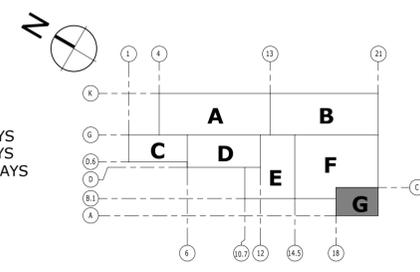

KEY PLAN

NO.	Revision Description	Date

THE INFORMATION, INCLUDING ESTIMATED QUANTITIES OF WORK, SHOWN ON THESE SHEETS IS BASED ON LIMITED INVESTIGATIONS BY THE STATE AND IS IN NO WAY WARRANTED TO INDICATE THE CONDITIONS OF ACTUAL QUANTITIES OF WORK WHICH WILL BE REQUIRED.

Plotted: 10/21/2014 3:42:27 PM

DESIGNER/DRAFTER
RHL

CHECKED BY:
RSL

SCALE
1/8" = 1'-0"



SIGNATURE/BLOCK:

PROJECT TITLE
REPAIR FACILITY


TOWN
ROCKY HILL

DRAWING TITLE
PLUMBING WATER DIST. - PART PLAN G

PROJECT NO.
118-0167

DRAWING NO.
PLM-207


SHEET NO.
09.23

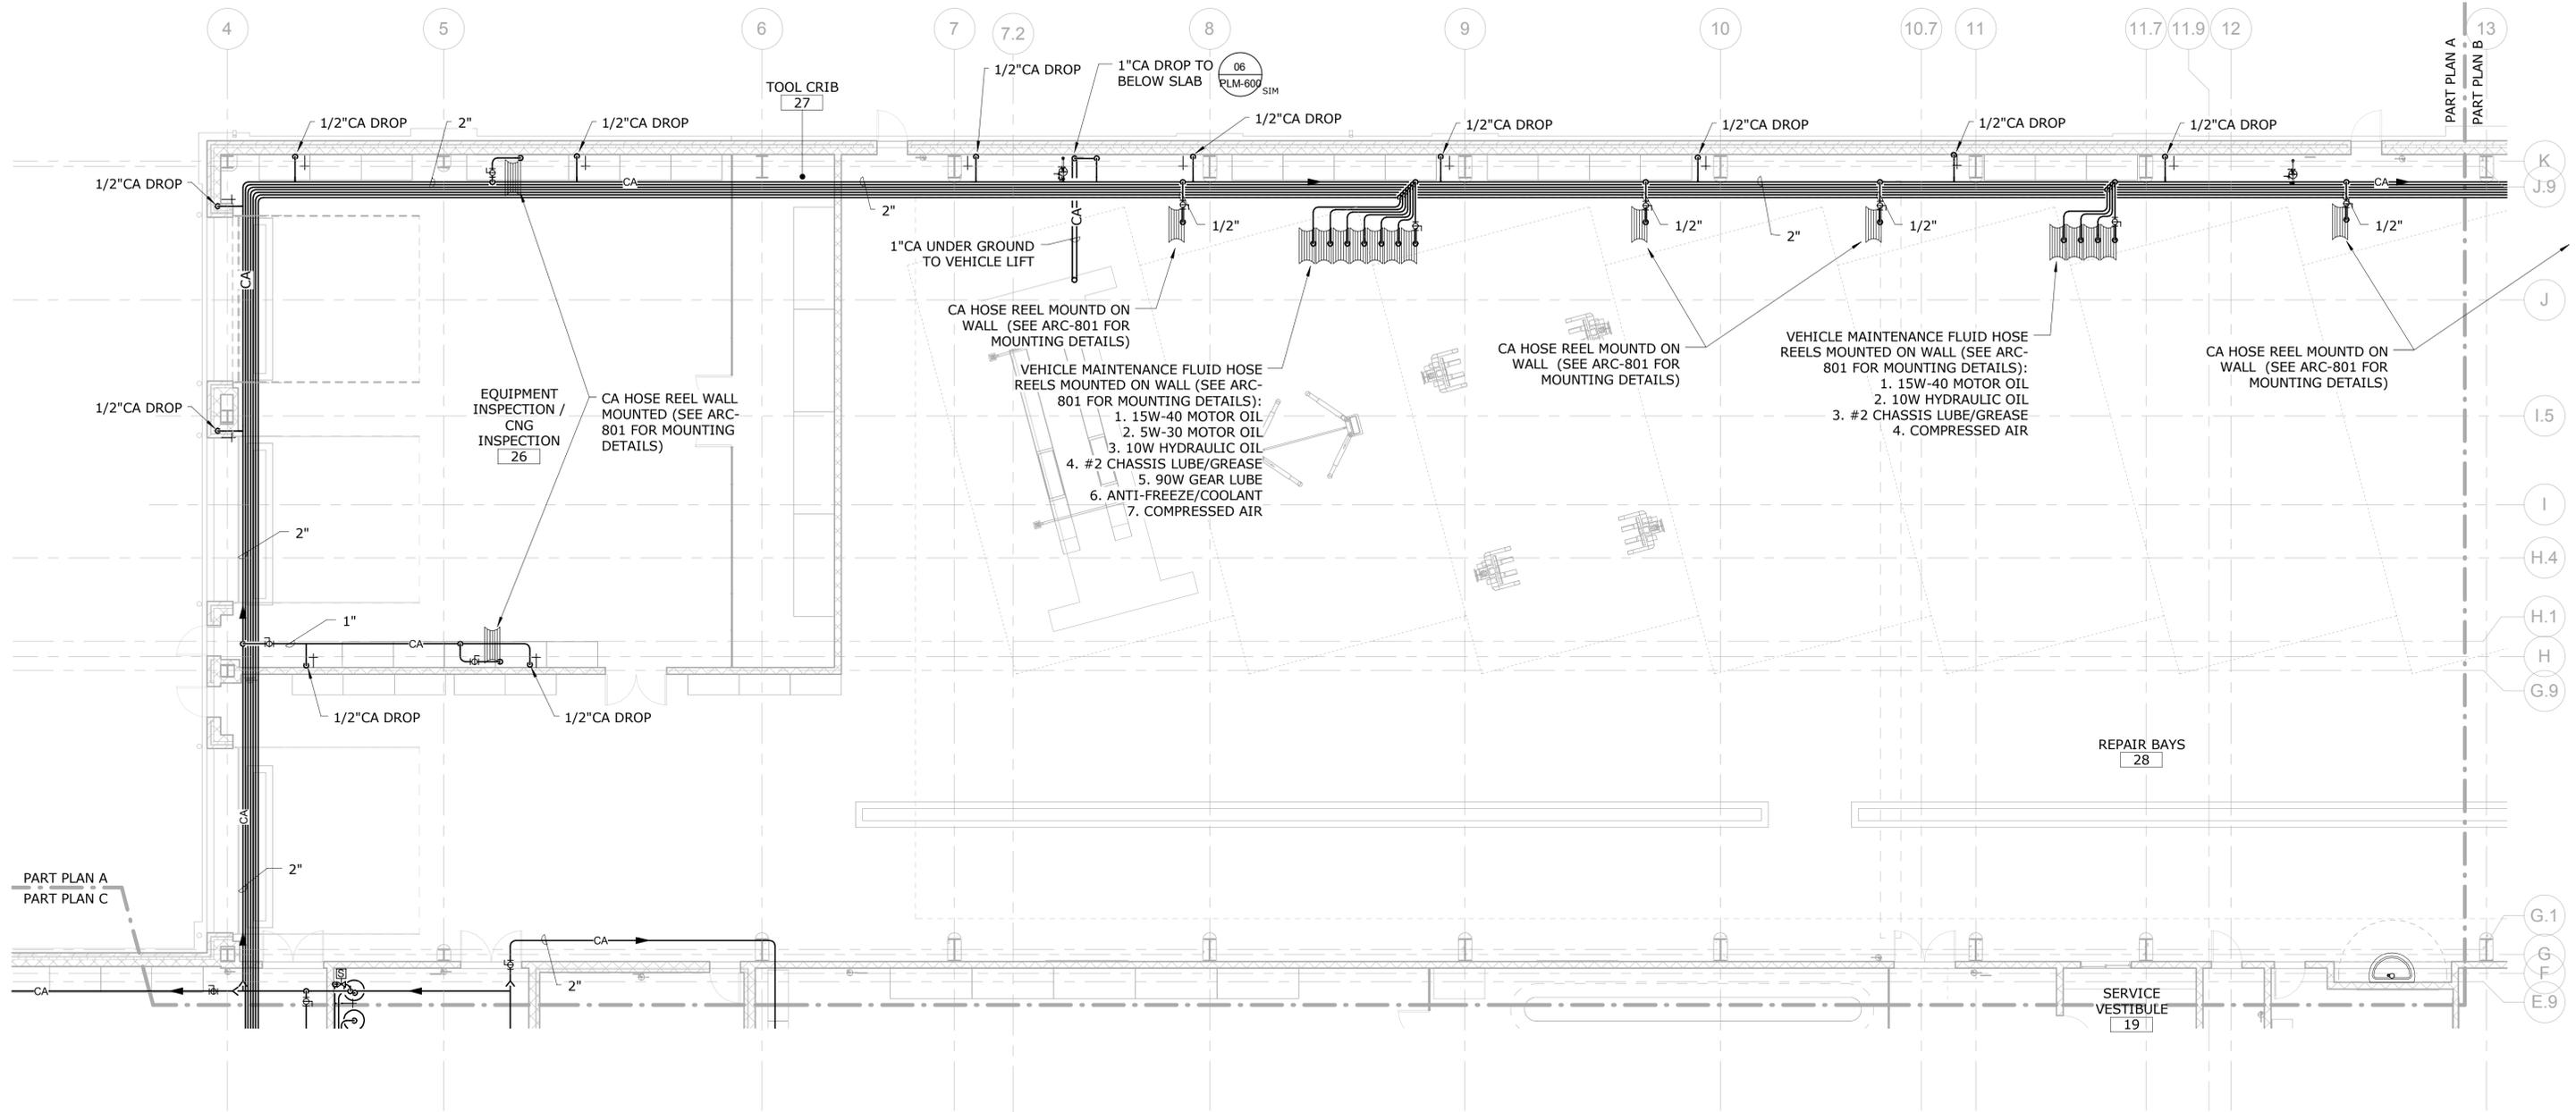

1 PLUMBING - FLUID & AIR - PART PLAN A - NORTH REPAIR BAYS
SCALE: 1/8" = 1'-0"

PARTIAL PLAN LEGEND:

- A - NORTH REPAIR BAYS
- B - SOUTH REPAIR BAYS
- C - LUBE AND WASH BAYS
- D - STORES
- E - OFFICE AREA
- F - MACHINE SHOP
- G - PAINT AREA

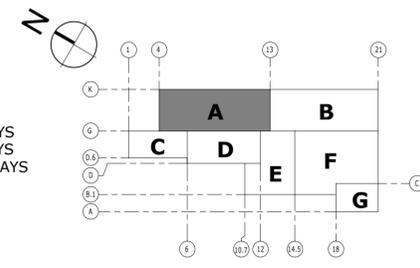

NO.	Revision Description	Date

THE INFORMATION, INCLUDING ESTIMATED QUANTITIES OF WORK, SHOWN ON THESE SHEETS IS BASED ON LIMITED INVESTIGATIONS BY THE STATE AND IS IN NO WAY WARRANTED TO INDICATE THE CONDITIONS OF ACTUAL QUANTITIES OF WORK WHICH WILL BE REQUIRED.

Plotted: 10/21/2014 3:42:33 PM

DESIGNER/DRAFTER
RHL

CHECKED BY:
RSL

SCALE
1/8" = 1'-0"



SIGNATURE/BLOCK:
[Signature]

PROJECT TITLE
REPAIR FACILITY


TOWN
ROCKY HILL

DRAWING TITLE
PLUMBING FLUID & AIR - PART PLAN A

PROJECT NO.
118-0167

DRAWING NO.
PLM-301


SHEET NO.
09.24

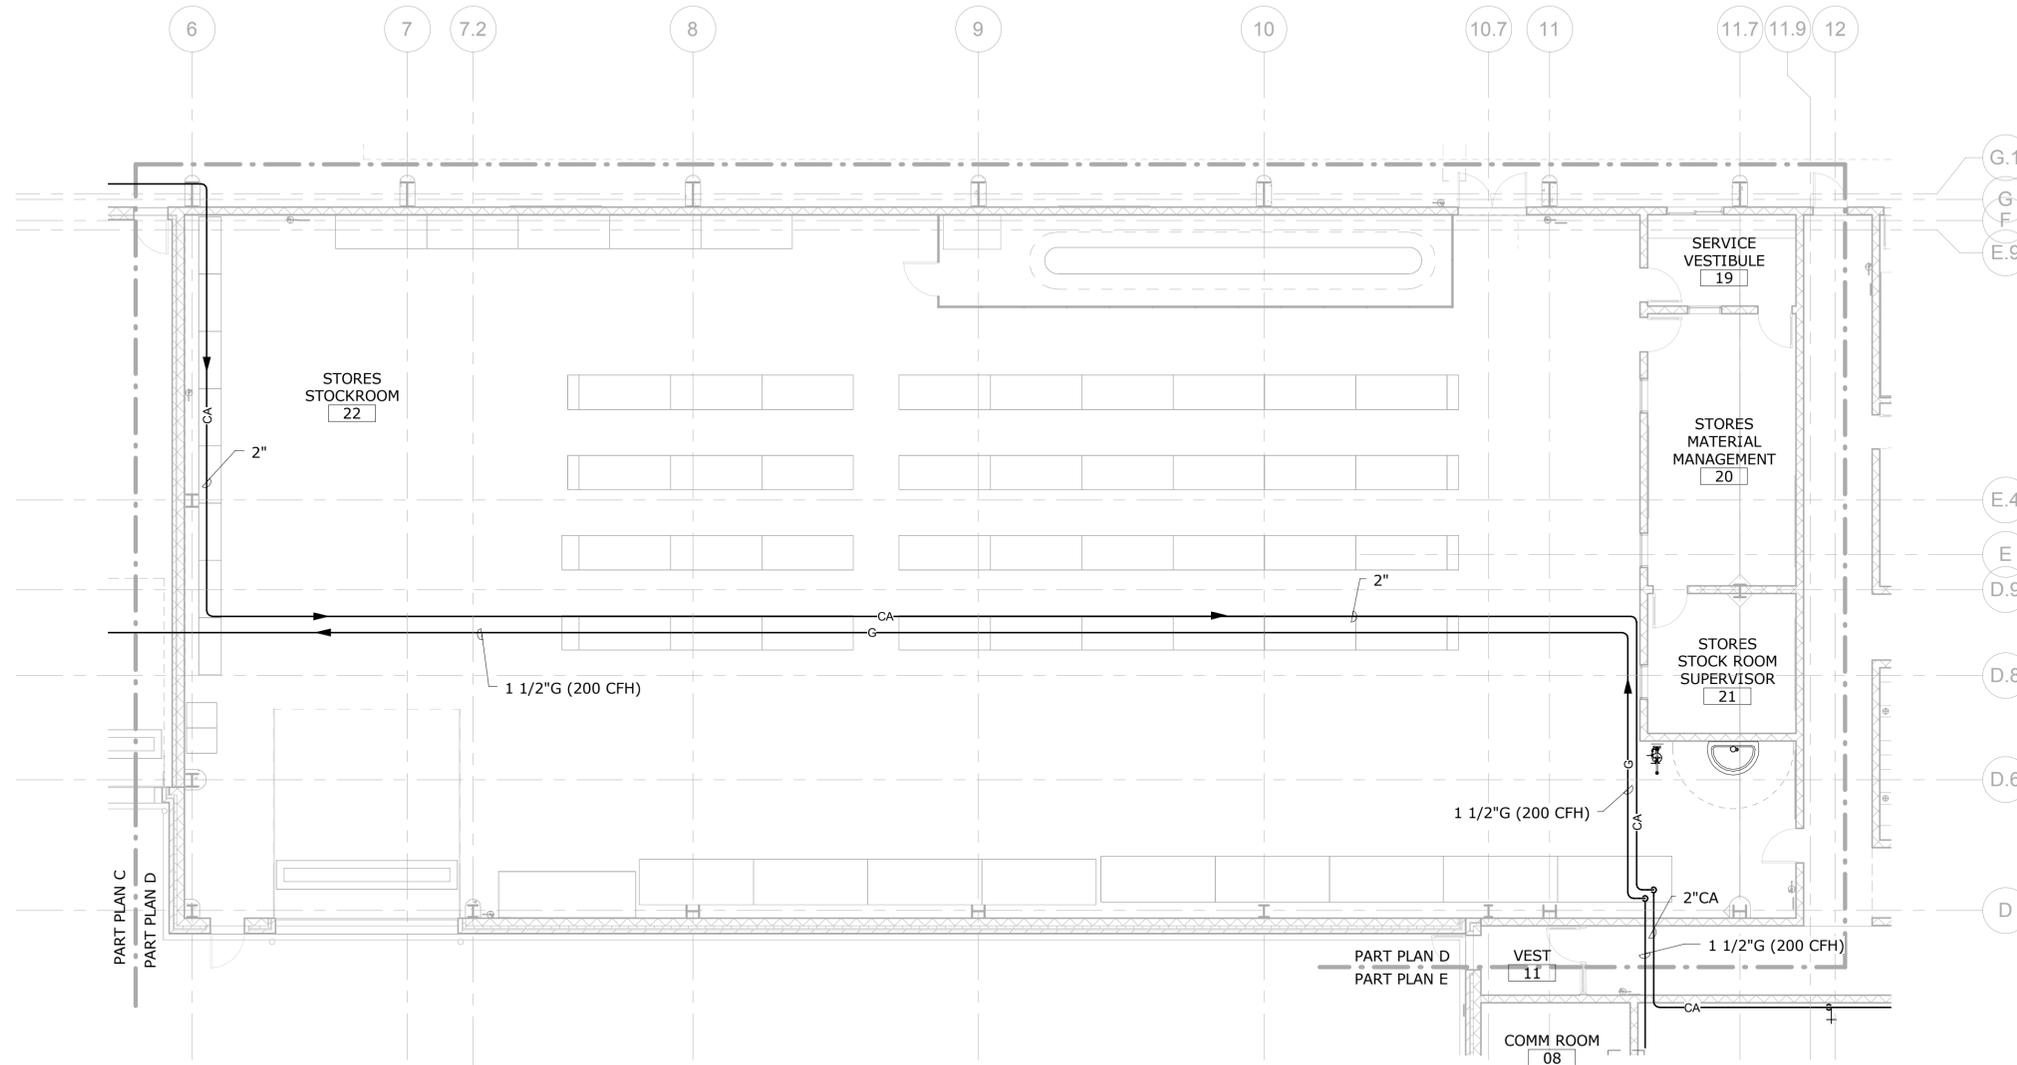

1 PLUMBING - FLUID & AIR - PART PLAN D - STORES
SCALE: 1/8" = 1'-0"

PARTIAL PLAN LEGEND:

- A - NORTH REPAIR BAYS
- B - SOUTH REPAIR BAYS
- C - LUBE AND WASH BAYS
- D - STORES
- E - OFFICE AREA
- F - MACHINE SHOP
- G - PAINT AREA

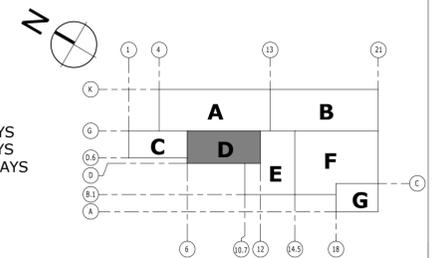

KEY PLAN

NO.	Revision Description	Date

THE INFORMATION, INCLUDING ESTIMATED QUANTITIES OF WORK, SHOWN ON THESE SHEETS IS BASED ON LIMITED INVESTIGATIONS BY THE STATE AND IS IN NO WAY WARRANTED TO INDICATE THE CONDITIONS OF ACTUAL QUANTITIES OF WORK WHICH WILL BE REQUIRED.

DESIGNER/DRAFTER
RHL
CHECKED BY:
RSL
SCALE
1/8" = 1'-0"




File Name: MPPP_CTDOT_Rocky Hill Repair Facility_Central.rvt

SIGNATURE/BLOCK:

PROJECT TITLE
REPAIR FACILITY

TOWN
ROCKY HILL
DRAWING TITLE
PLUMBING FLUID & AIR - PART PLAN D


PROJECT NO.
118-0167
DRAWING NO.
PLM-304
SHEET NO.
09.27

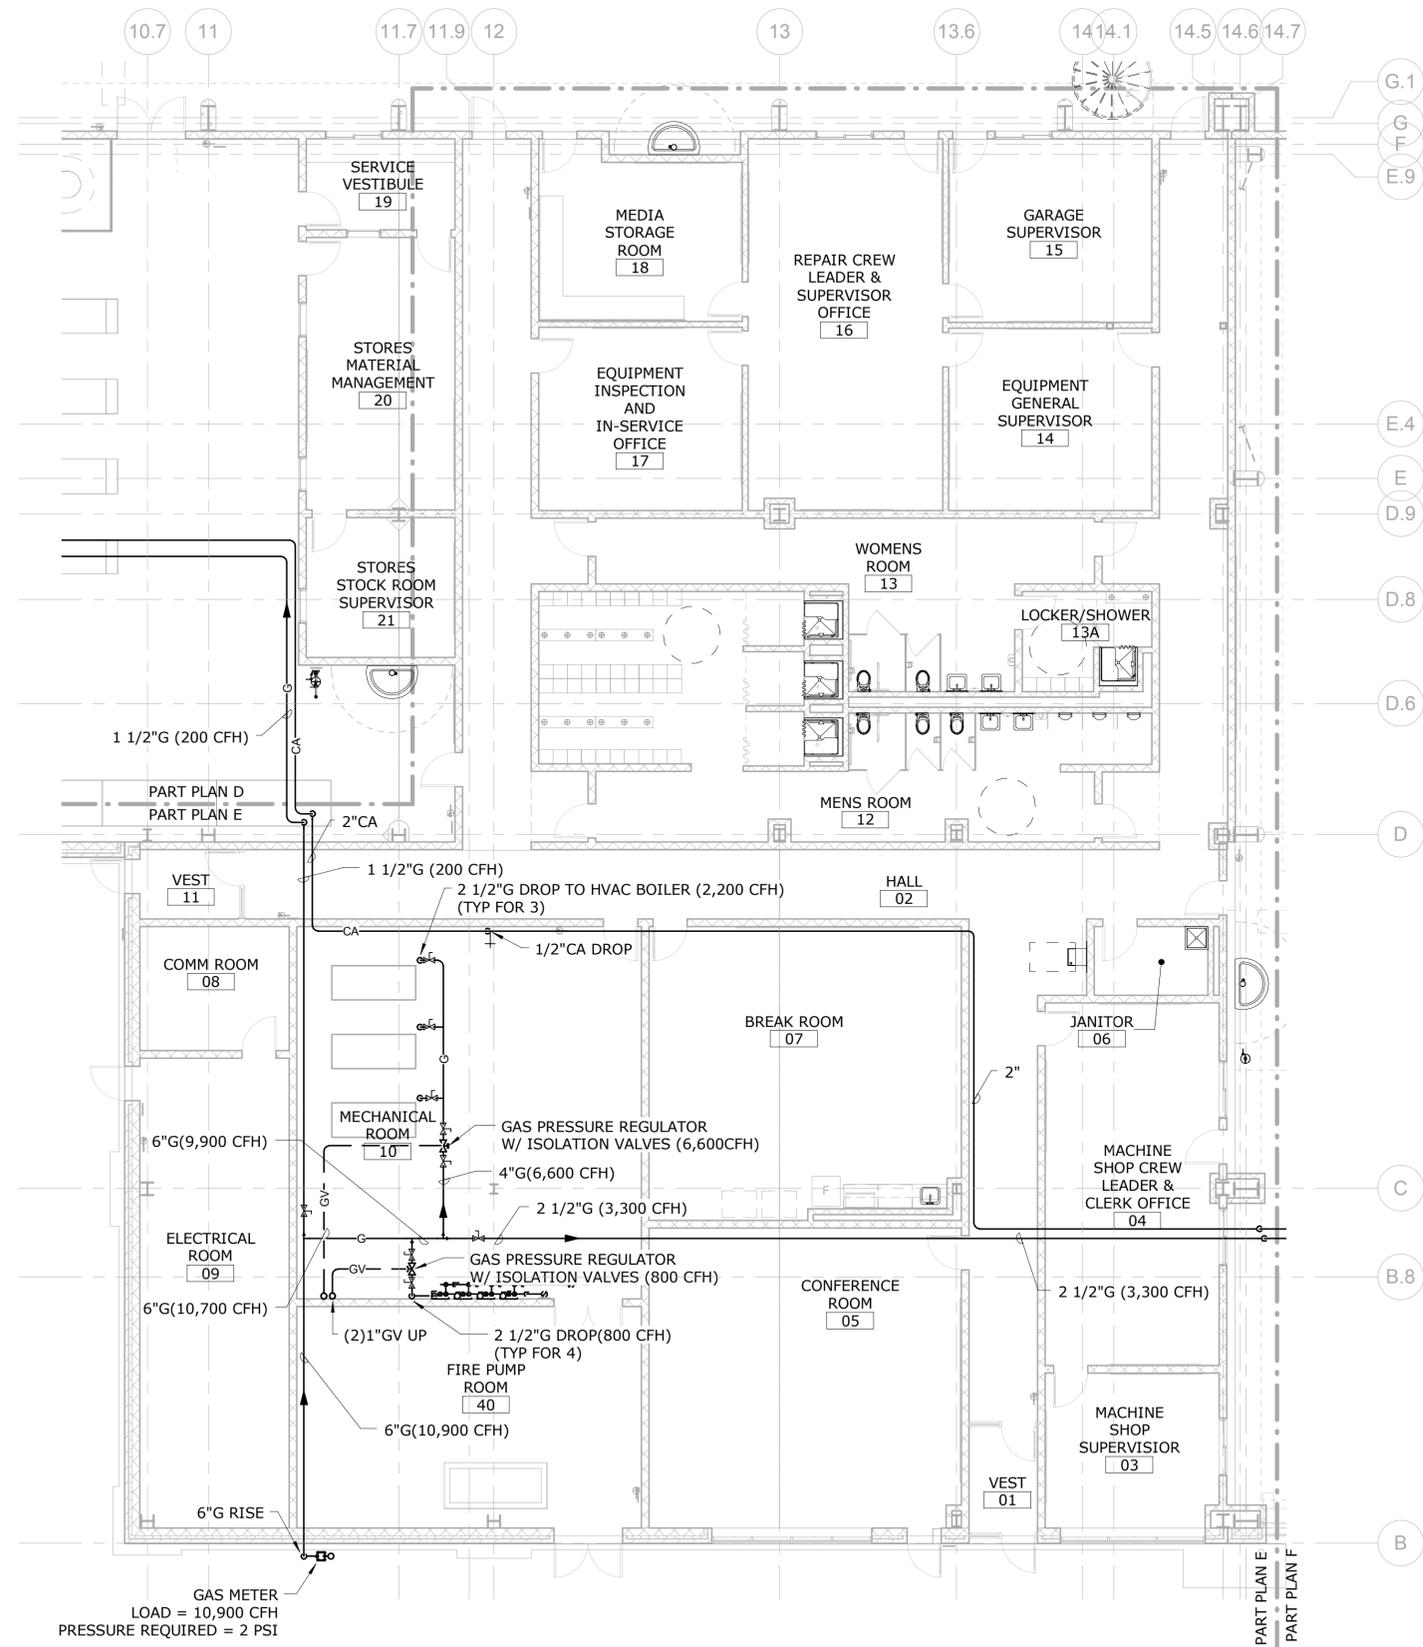

1 PLUMBING - FLUID & AIR - PART PLAN E - OFFICE AREA
SCALE: 1/8" = 1'-0"

PARTIAL PLAN LEGEND:

- A - NORTH REPAIR BAYS
- B - SOUTH REPAIR BAYS
- C - LUBE AND WASH BAYS
- D - STORES
- E - OFFICE AREA
- F - MACHINE SHOP
- G - PAINT AREA

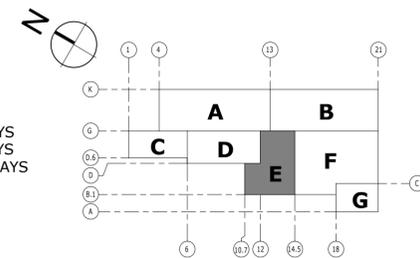

KEY PLAN

NO.	Revision Description	Date

THE INFORMATION, INCLUDING ESTIMATED QUANTITIES OF WORK, SHOWN ON THESE SHEETS IS BASED ON LIMITED INVESTIGATIONS BY THE STATE AND IS IN NO WAY WARRANTED TO INDICATE THE CONDITIONS OF ACTUAL QUANTITIES OF WORK WHICH WILL BE REQUIRED.

DESIGNER/DRAFTER
RHL
CHECKED BY:
RSL
SCALE
1/8" = 1'-0"




SIGNATURE/BLOCK:
[Signature]

PROJECT TITLE
REPAIR FACILITY


TOWN
ROCKY HILL
DRAWING TITLE
PLUMBING FLUID & AIR - PART PLAN E

PROJECT NO.
118-0167
DRAWING NO.
PLM-305
SHEET NO.
09.28

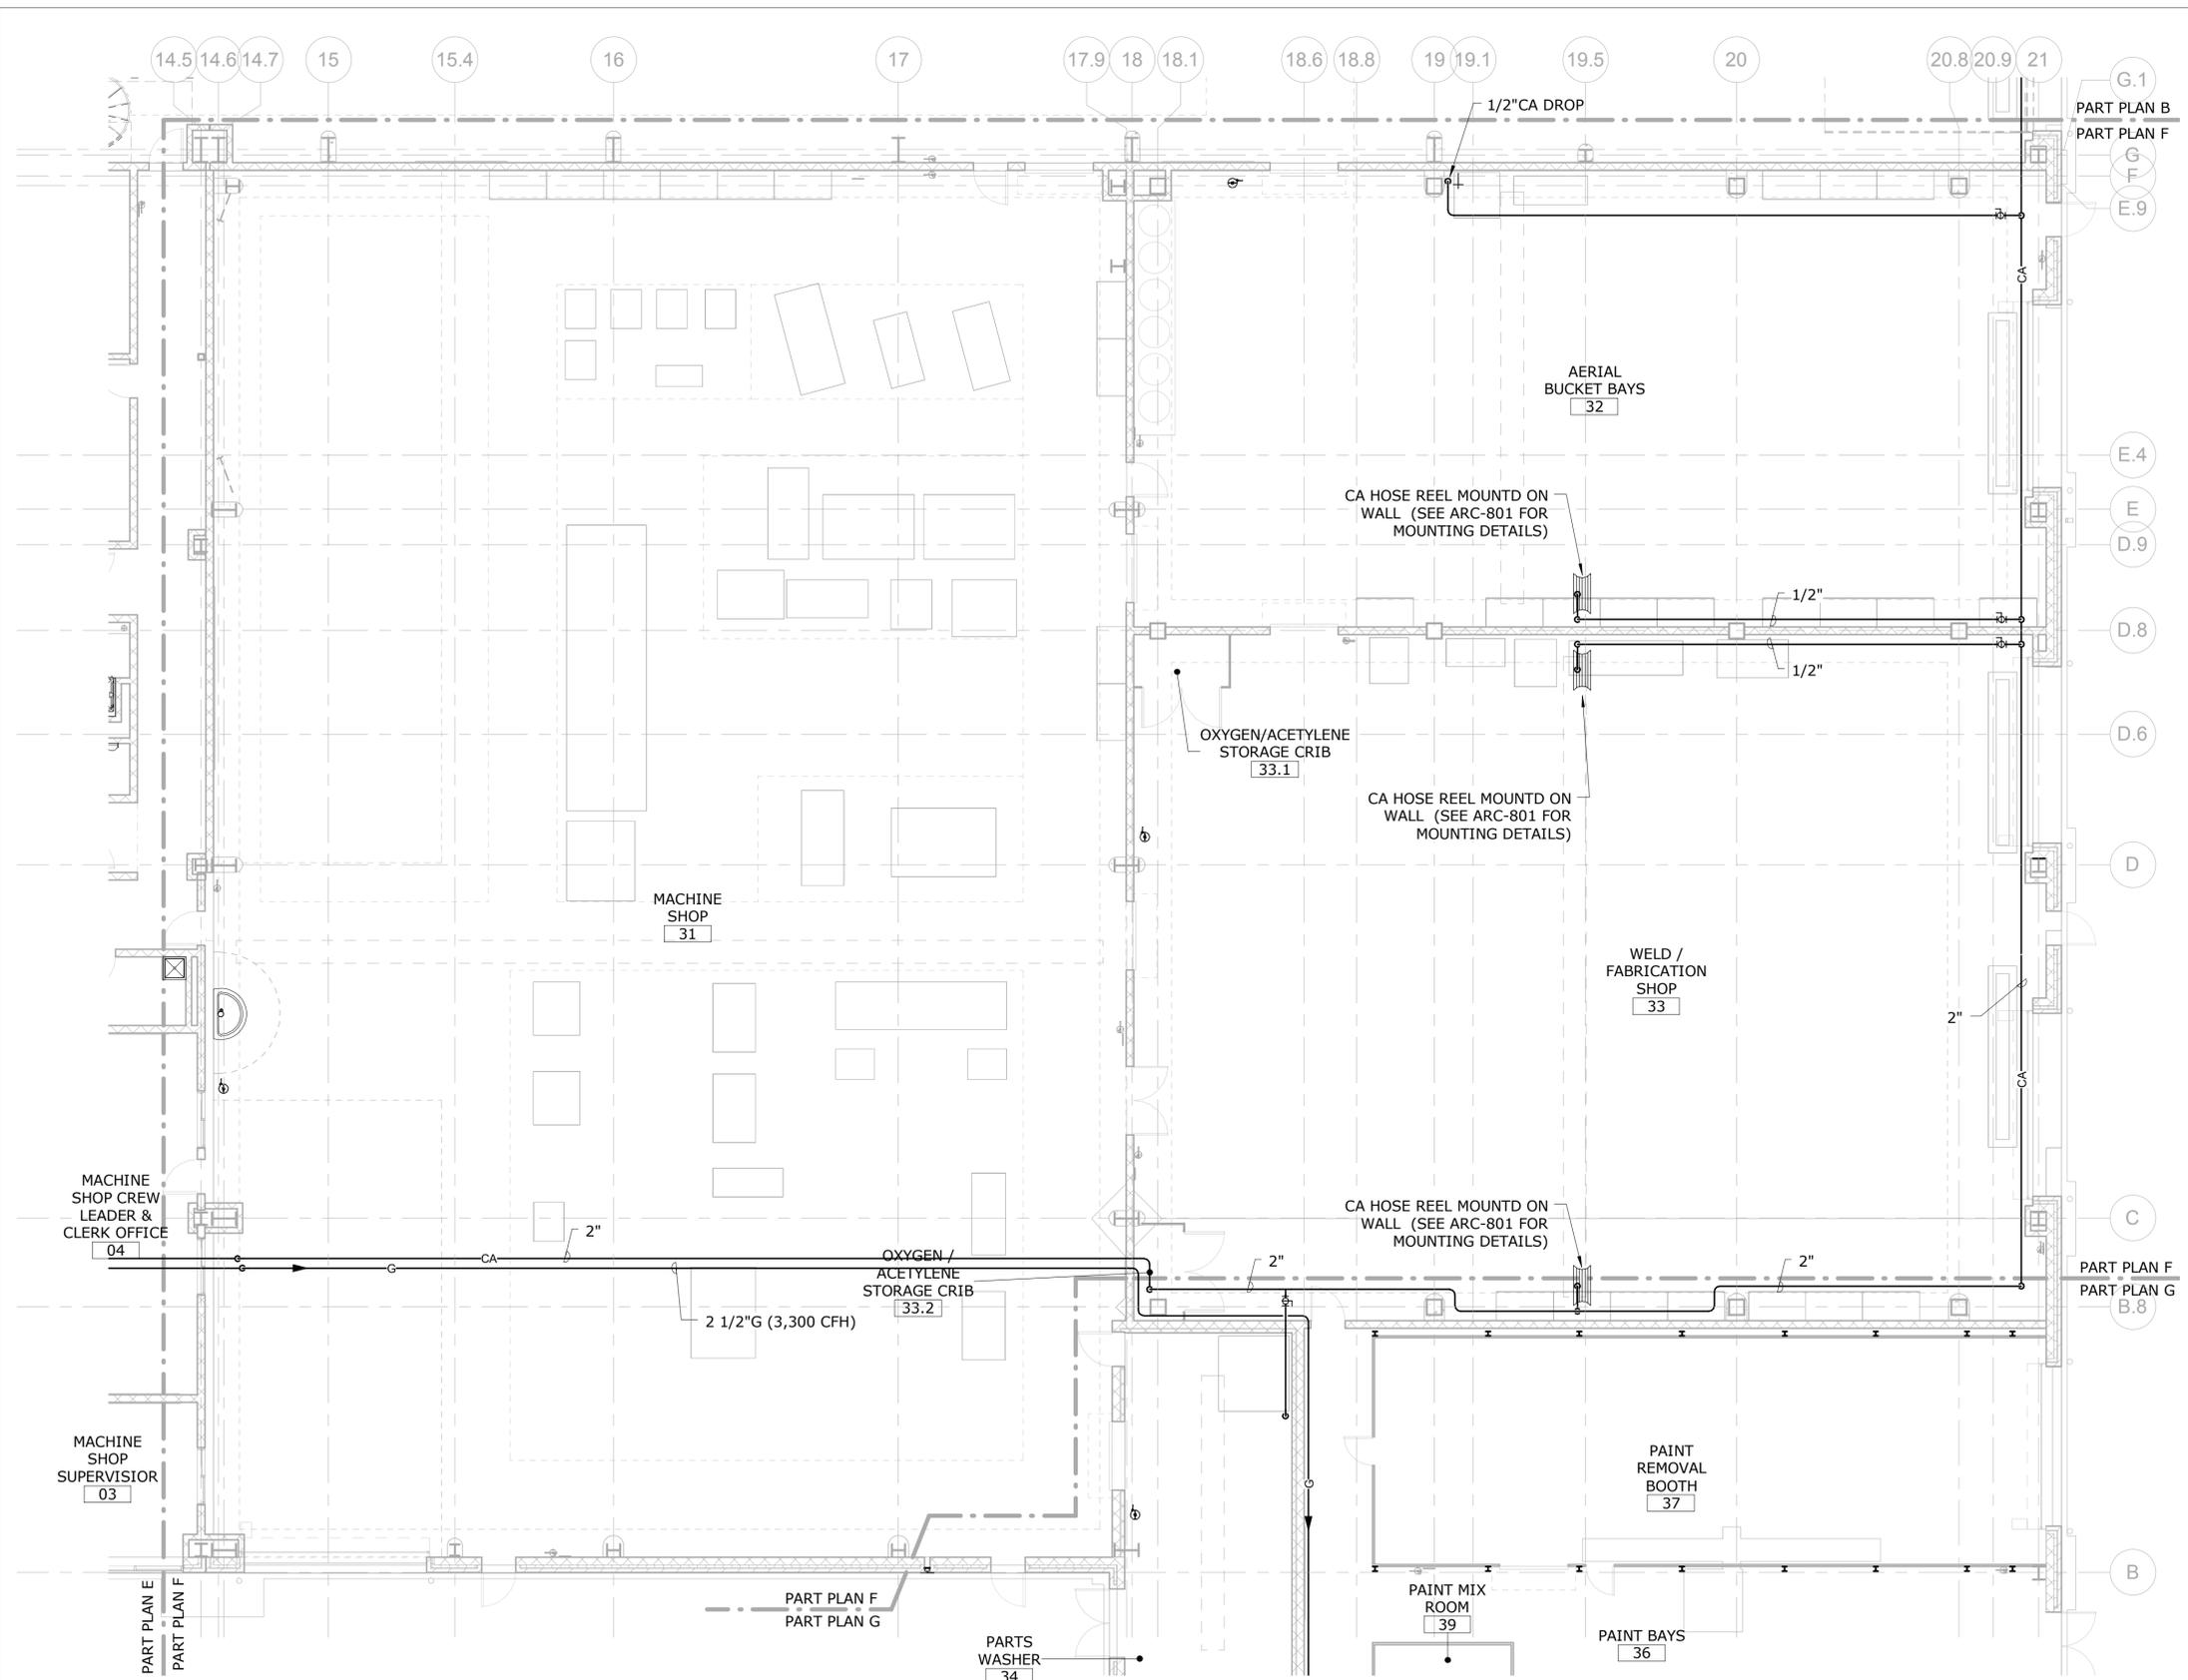

1 PLUMBING - FLUID & AIR - PART PLAN F - MACHINE SHOP
SCALE: 1/8" = 1'-0"

- PARTIAL PLAN LEGEND:**
- A - NORTH REPAIR BAYS
 - B - SOUTH REPAIR BAYS
 - C - LUBE AND WASH BAYS
 - D - STORES
 - E - OFFICE AREA
 - F - MACHINE SHOP
 - G - PAINT AREA

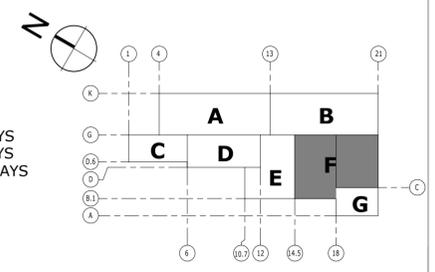

KEY PLAN

NO.	Revision Description	Date

THE INFORMATION, INCLUDING ESTIMATED QUANTITIES OF WORK, SHOWN ON THESE SHEETS IS BASED ON LIMITED INVESTIGATIONS BY THE STATE AND IS IN NO WAY WARRANTED TO INDICATE THE CONDITIONS OF ACTUAL QUANTITIES OF WORK WHICH WILL BE REQUIRED.

DESIGNER/DRAFTER
RHL
CHECKED BY:
RSL
SCALE
1/8" = 1'-0"



SIGNATURE/BLOCK:
[Signature]


PROJECT TITLE
REPAIR FACILITY

TOWN
ROCKY HILL
DRAWING TITLE
PLUMBING FLUID & AIR - PART PLAN F

PROJECT NO.
118-0167
DRAWING NO.
PLM-306
SHEET NO.
09.29


Plotted: 10/21/2014 3:42:55 PM

File Name: MPPP_CTDOT_Rocky Hill Repair Facility_Central.rvt

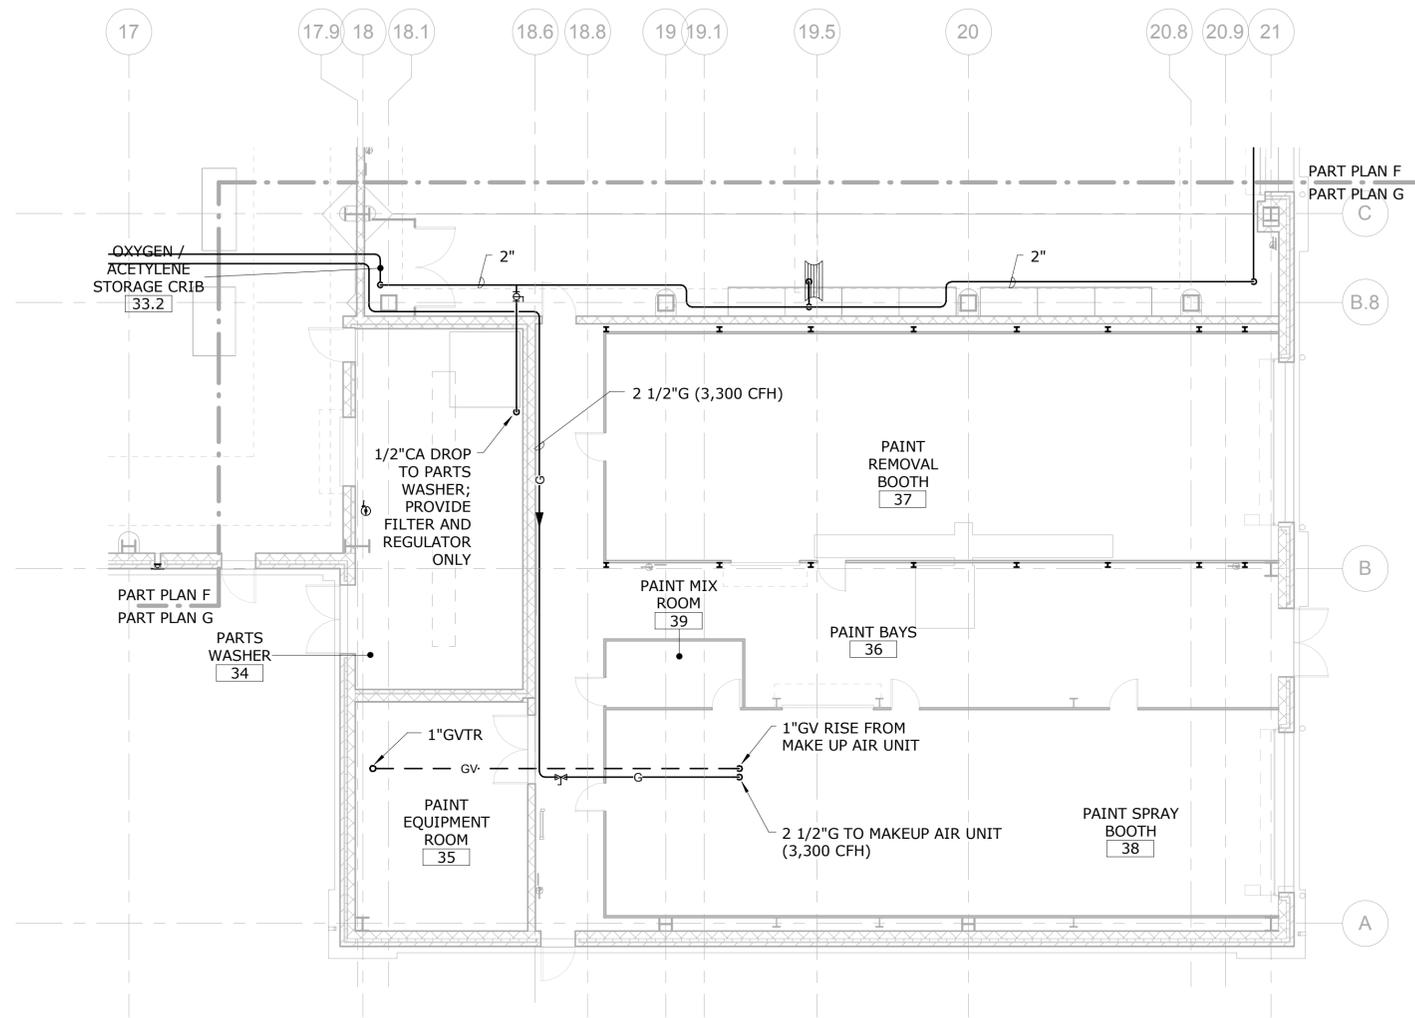

1 PLUMBING - FLUID & AIR - PART PLAN G - PAINT AREA
SCALE: 1/8" = 1'-0"

- PARTIAL PLAN LEGEND:**
- A - NORTH REPAIR BAYS
 - B - SOUTH REPAIR BAYS
 - C - LUBE AND WASH BAYS
 - D - STORES
 - E - OFFICE AREA
 - F - MACHINE SHOP
 - G - PAINT AREA

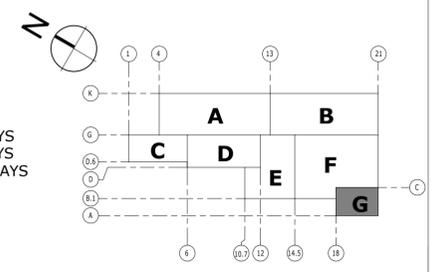

KEY PLAN

NO.	Revision Description	Date

THE INFORMATION, INCLUDING ESTIMATED QUANTITIES OF WORK, SHOWN ON THESE SHEETS IS BASED ON LIMITED INVESTIGATIONS BY THE STATE AND IS IN NO WAY WARRANTED TO INDICATE THE CONDITIONS OF ACTUAL QUANTITIES OF WORK WHICH WILL BE REQUIRED.

Plotted: 10/21/2014 3:42:58 PM

DESIGNER/DRAFTER
RHL

CHECKED BY:
RSL

SCALE
1/8" = 1'-0"



SIGNATURE/BLOCK:

PROJECT TITLE
REPAIR FACILITY


TOWN
ROCKY HILL

DRAWING TITLE
PLUMBING FLUID & AIR - PART PLAN G

PROJECT NO.
118-0167


DRAWING NO.
PLM-307

SHEET NO.
09.30

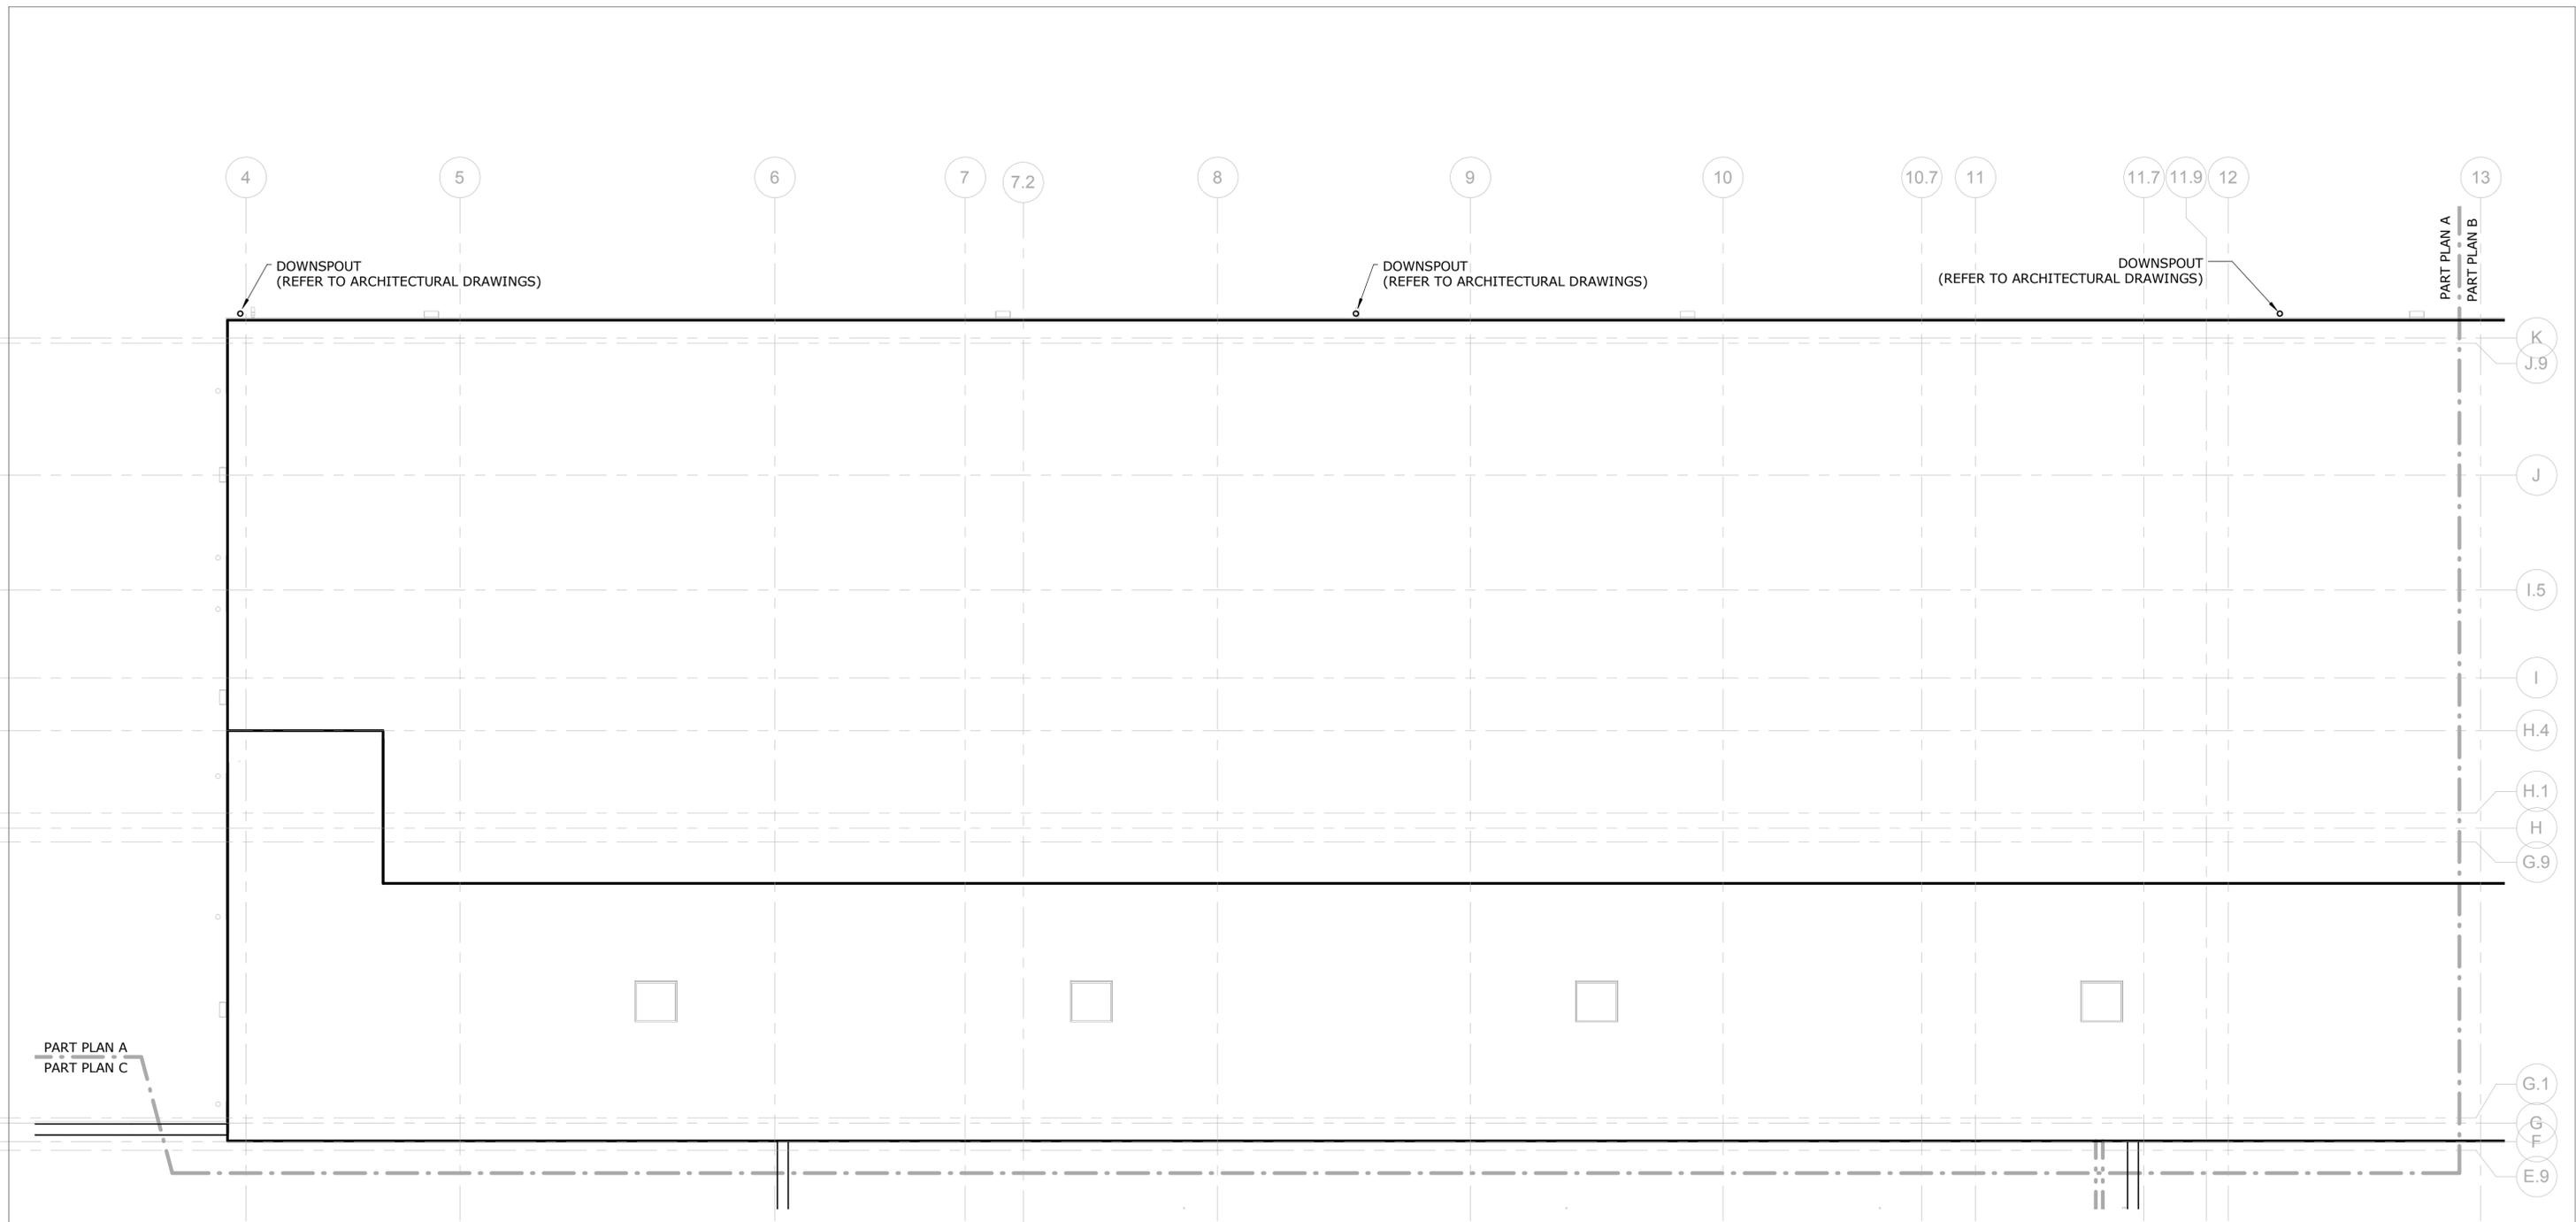

1 PLUMBING - ROOF LEVEL - PART PLAN A
SCALE: 1/8" = 1'-0"

- PARTIAL PLAN LEGEND:**
- A - NORTH REPAIR BAYS
 - B - SOUTH REPAIR BAYS
 - C - LUBE AND WASH BAYS
 - D - STORES
 - E - OFFICE AREA
 - F - MACHINE SHOP
 - G - PAINT AREA

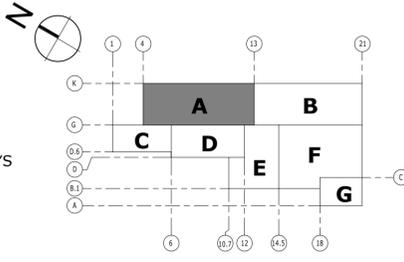

NO.	Revision Description	Date

THE INFORMATION, INCLUDING ESTIMATED QUANTITIES OF WORK, SHOWN ON THESE SHEETS IS BASED ON LIMITED INVESTIGATIONS BY THE STATE AND IS IN NO WAY WARRANTED TO INDICATE THE CONDITIONS OF ACTUAL QUANTITIES OF WORK WHICH WILL BE REQUIRED.

DESIGNER/DRAFTER
RHL
CHECKED BY:
RSL
SCALE
1/8" = 1'-0"




SIGNATURE/BLOCK:
[Signature]

PROJECT TITLE
REPAIR FACILITY

TOWN
ROCKY HILL
DRAWING TITLE
PLUMBING ROOF - PART PLAN A


PROJECT NO.
118-0167
DRAWING NO.
PLM-401
SHEET NO.
09.31

File Name: MPPP_CTDOT_Rocky Hill Repair Facility_Central.rvt

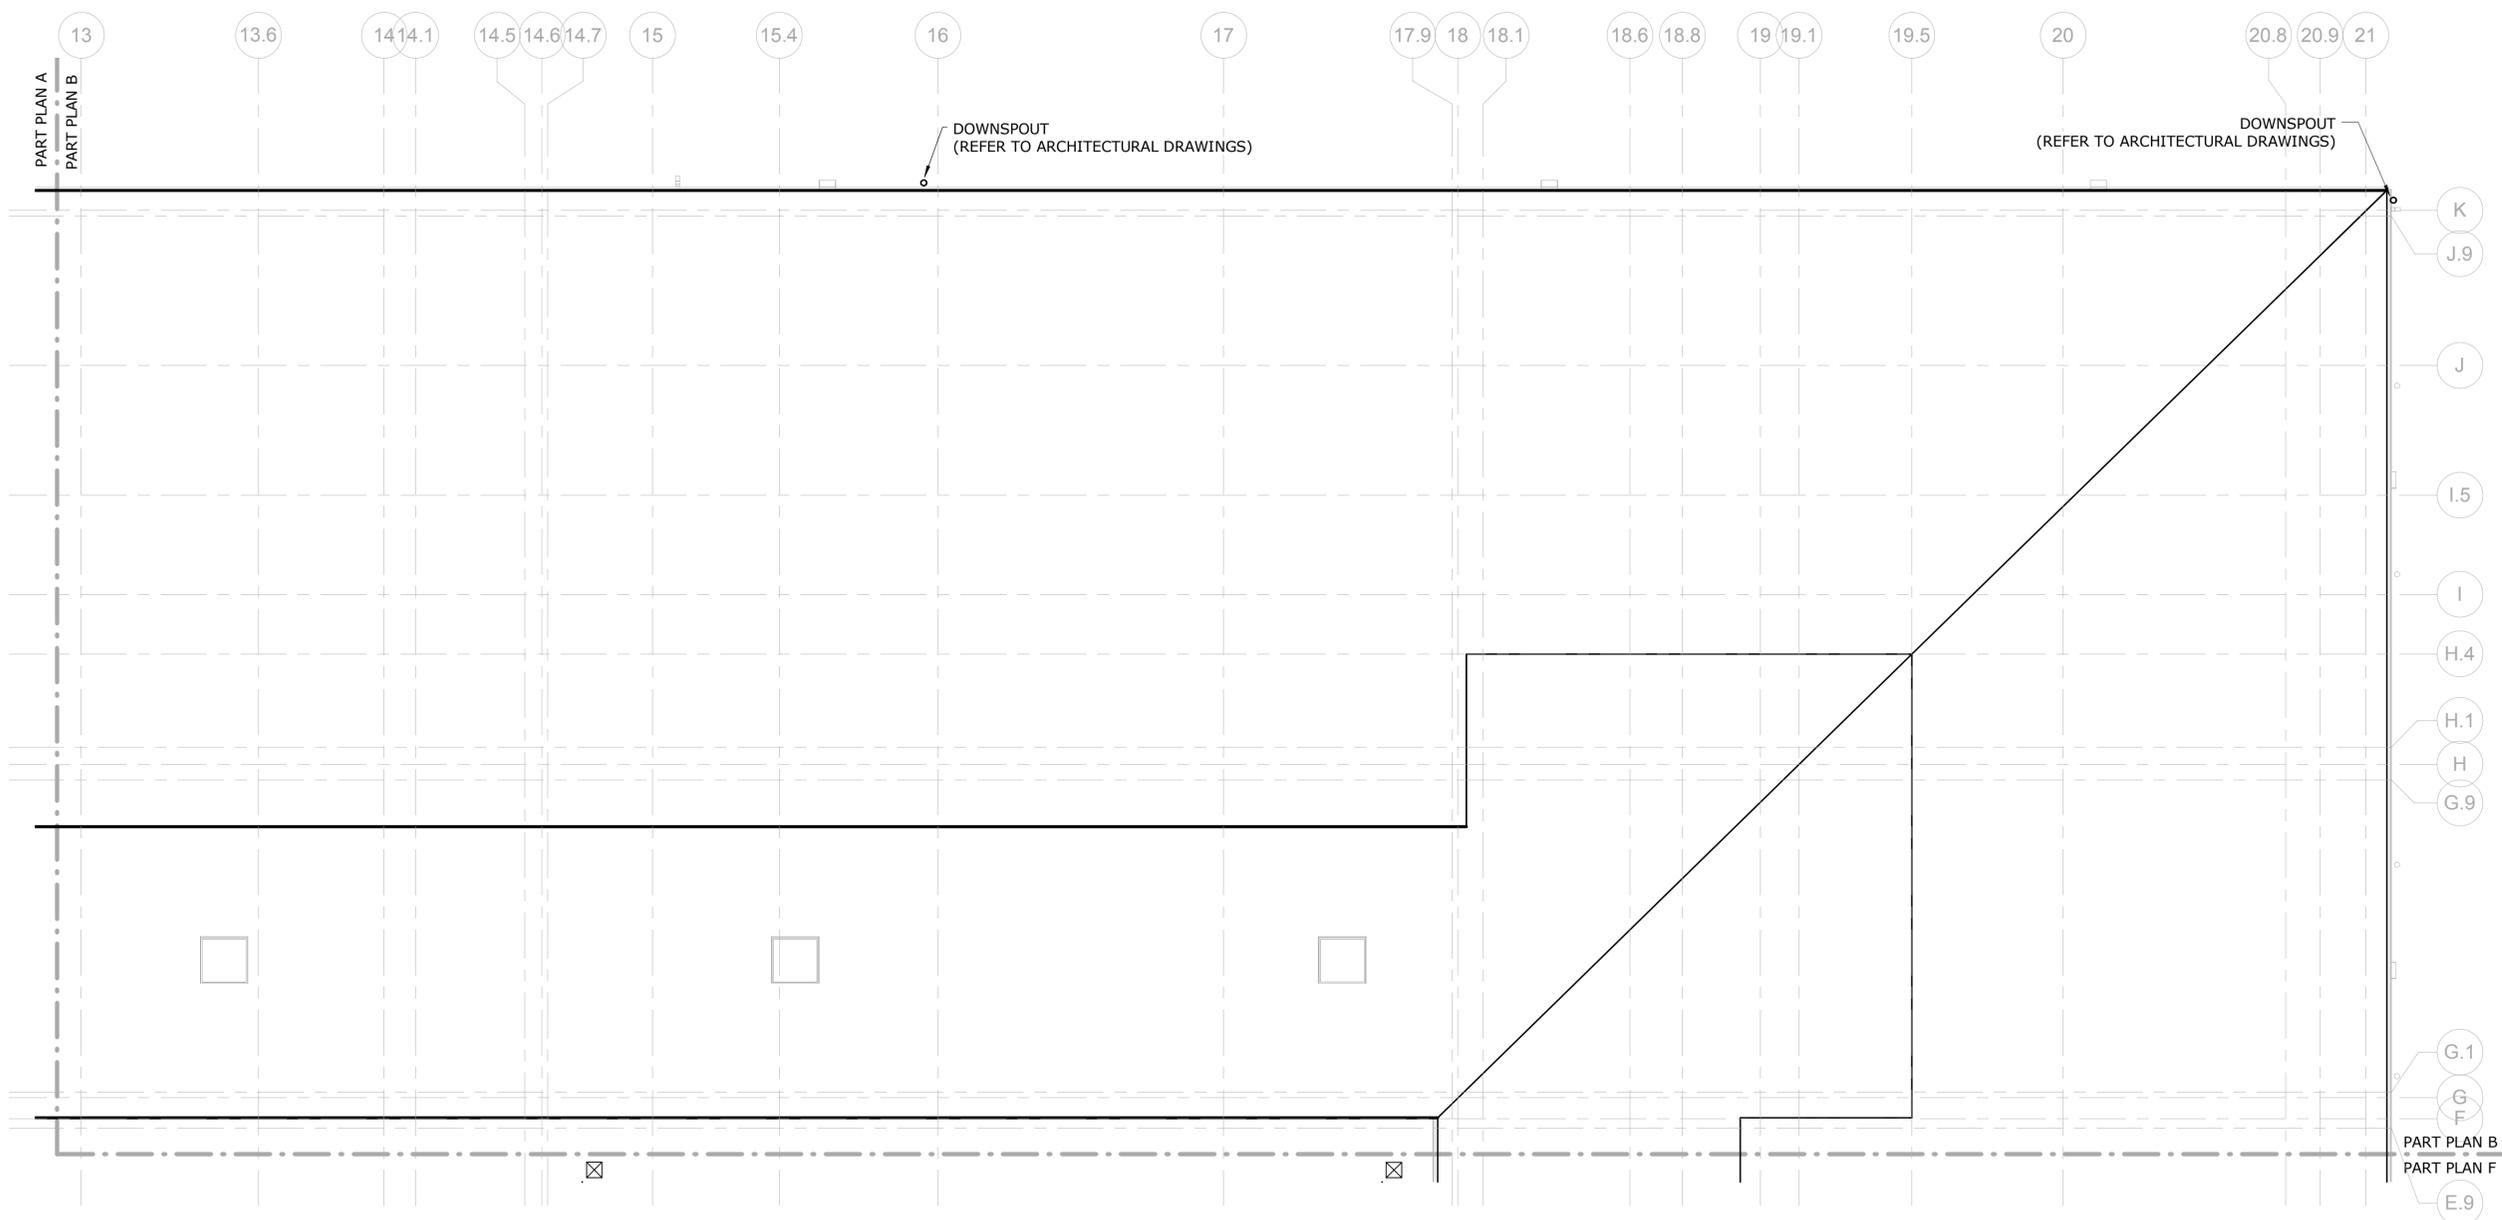

1 PLUMBING - ROOF LEVEL - PART PLAN B
SCALE: 1/8" = 1'-0"

- PARTIAL PLAN LEGEND:**
- A - NORTH REPAIR BAYS
 - B - SOUTH REPAIR BAYS
 - C - LUBE AND WASH BAYS
 - D - STORES
 - E - OFFICE AREA
 - F - MACHINE SHOP
 - G - PAINT AREA

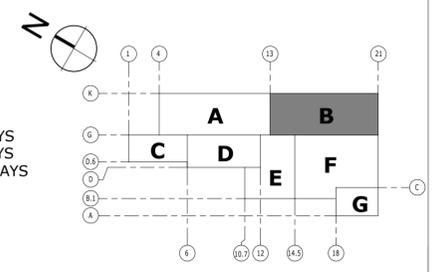

NO.	Revision Description	Date

THE INFORMATION, INCLUDING ESTIMATED QUANTITIES OF WORK, SHOWN ON THESE SHEETS IS BASED ON LIMITED INVESTIGATIONS BY THE STATE AND IS IN NO WAY WARRANTED TO INDICATE THE CONDITIONS OF ACTUAL QUANTITIES OF WORK WHICH WILL BE REQUIRED.

Plotted: 10/21/2014 3:43:02 PM

DESIGNER/DRAFTER
RHL

CHECKED BY:
RSL

SCALE
1/8" = 1'-0"



SIGNATURE/BLOCK:

PROJECT TITLE
REPAIR FACILITY


TOWN
ROCKY HILL

DRAWING TITLE
PLUMBING ROOF - PART PLAN B

PROJECT NO.
118-0167


DRAWING NO.
PLM-402

SHEET NO.
09.32

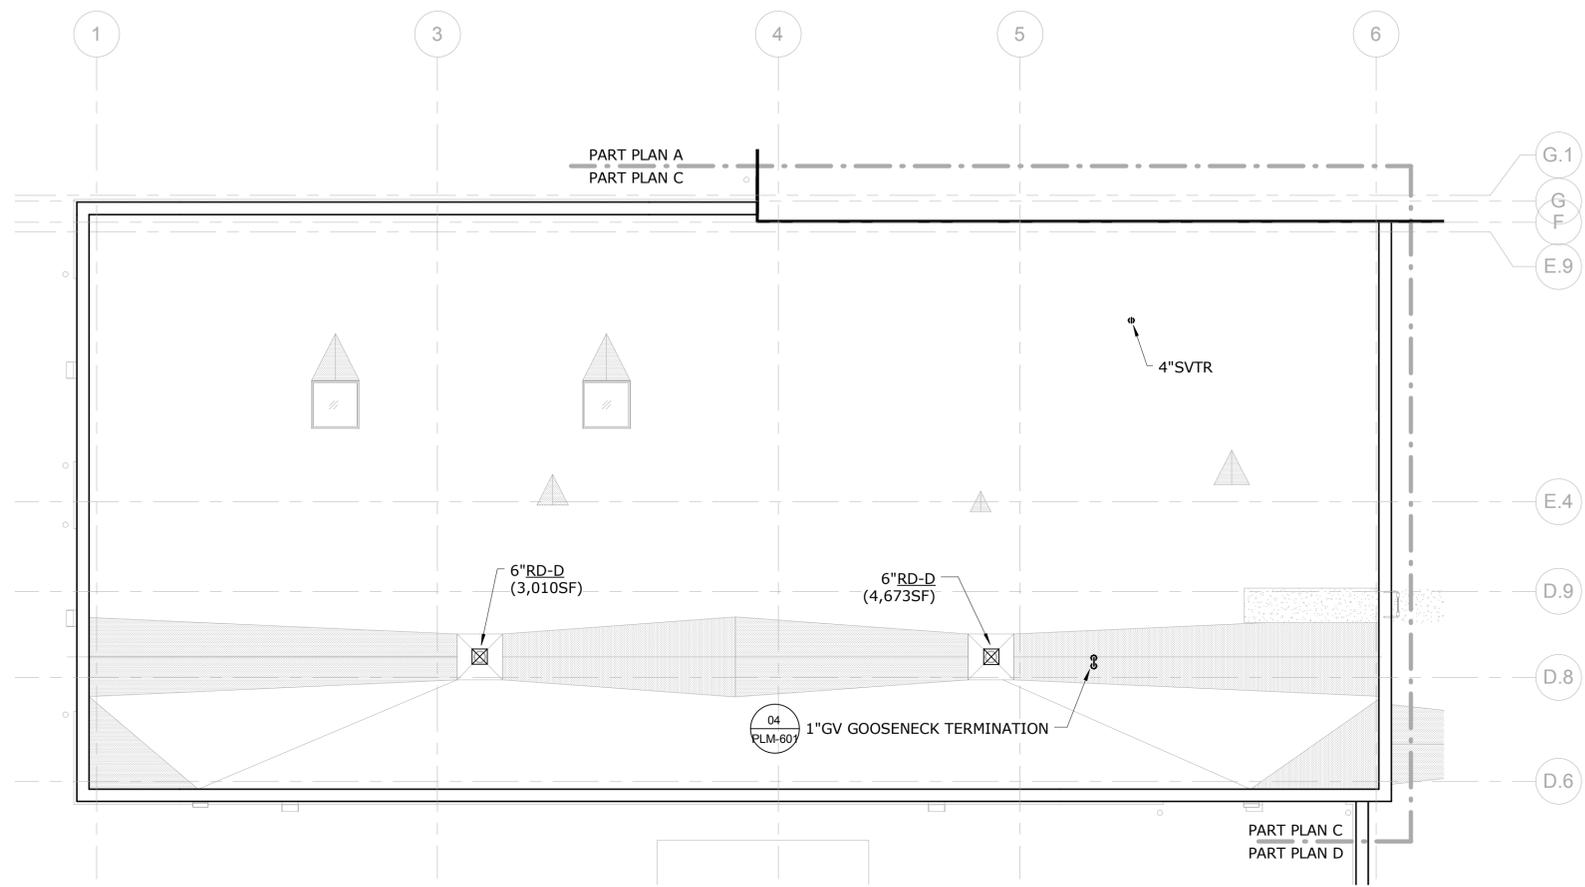

1 PLUMBING - ROOF LEVEL - PART PLAN C
SCALE: 1/8" = 1'-0"

- PARTIAL PLAN LEGEND:**
- A - NORTH REPAIR BAYS
 - B - SOUTH REPAIR BAYS
 - C - LUBE AND WASH BAYS
 - D - STORES
 - E - OFFICE AREA
 - F - MACHINE SHOP
 - G - PAINT AREA

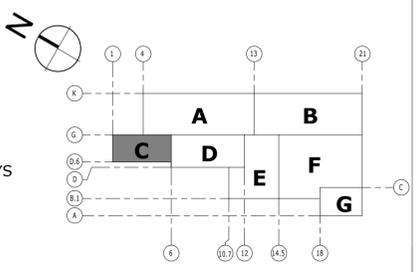

KEY PLAN

NO.	Revision Description	Date

THE INFORMATION, INCLUDING ESTIMATED QUANTITIES OF WORK, SHOWN ON THESE SHEETS IS BASED ON LIMITED INVESTIGATIONS BY THE STATE AND IS IN NO WAY WARRANTED TO INDICATE THE CONDITIONS OF ACTUAL QUANTITIES OF WORK WHICH WILL BE REQUIRED.

Plotted: 10/21/2014 3:43:06 PM

DESIGNER/DRAFTER
RHL

CHECKED BY:
RSL

SCALE
1/8" = 1'-0"



SIGNATURE/BLOCK:

PROJECT TITLE
REPAIR FACILITY


TOWN
ROCKY HILL

DRAWING TITLE
**PLUMBING ROOF - PART
PLAN C**

PROJECT NO.
118-0167

DRAWING NO.
PLM-403


SHEET NO.
09.33

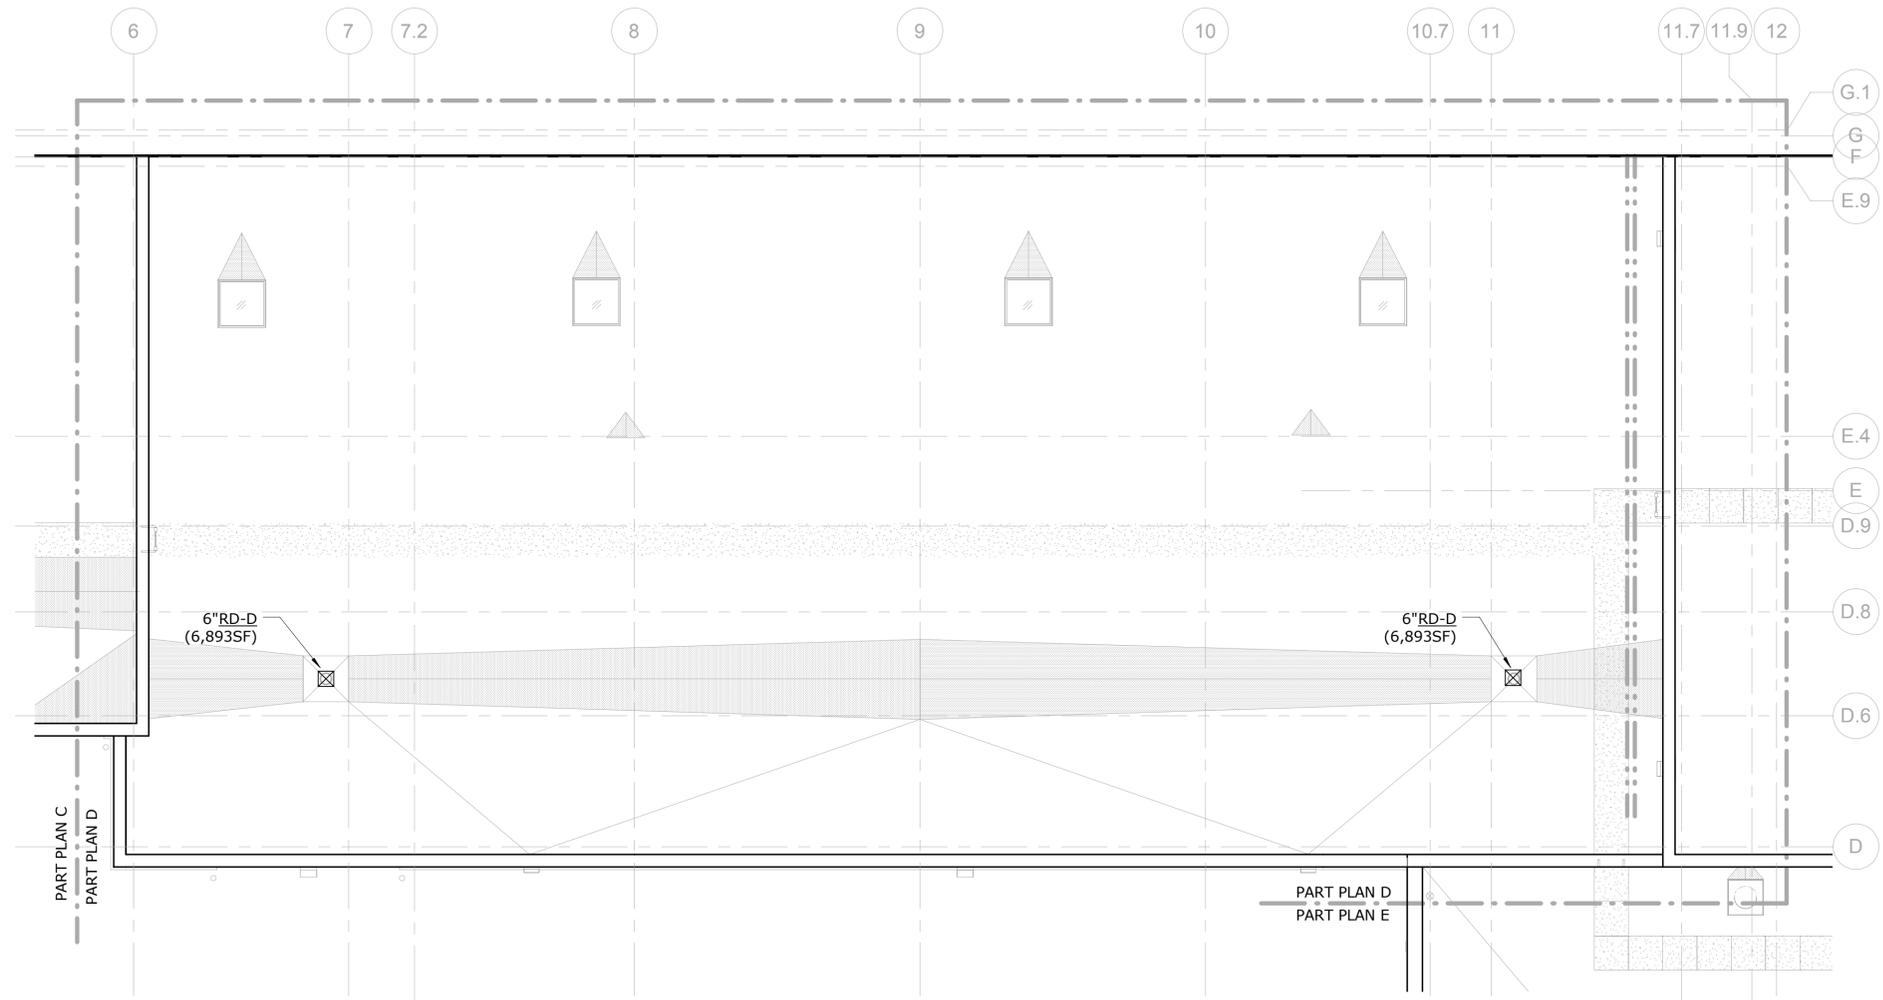

1 PLUMBING - ROOF LEVEL - PART PLAN D
SCALE: 1/8" = 1'-0"

PARTIAL PLAN LEGEND:

- A - NORTH REPAIR BAYS
- B - SOUTH REPAIR BAYS
- C - LUBE AND WASH BAYS
- D - STORES
- E - OFFICE AREA
- F - MACHINE SHOP
- G - PAINT AREA

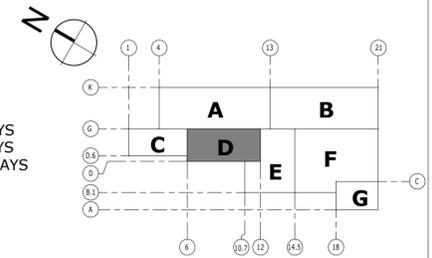

KEY PLAN

NO.	Revision Description	Date

THE INFORMATION, INCLUDING ESTIMATED QUANTITIES OF WORK, SHOWN ON THESE SHEETS IS BASED ON LIMITED INVESTIGATIONS BY THE STATE AND IS IN NO WAY WARRANTED TO INDICATE THE CONDITIONS OF ACTUAL QUANTITIES OF WORK WHICH WILL BE REQUIRED.

DESIGNER/DRAFTER
RHL
CHECKED BY:
RSL
SCALE
1/8" = 1'-0"




SIGNATURE/BLOCK:

PROJECT TITLE
REPAIR FACILITY

TOWN
ROCKY HILL
DRAWING TITLE
PLUMBING ROOF - PART PLAN D


PROJECT NO.
118-0167
DRAWING NO.
PLM-404
SHEET NO.
09.34

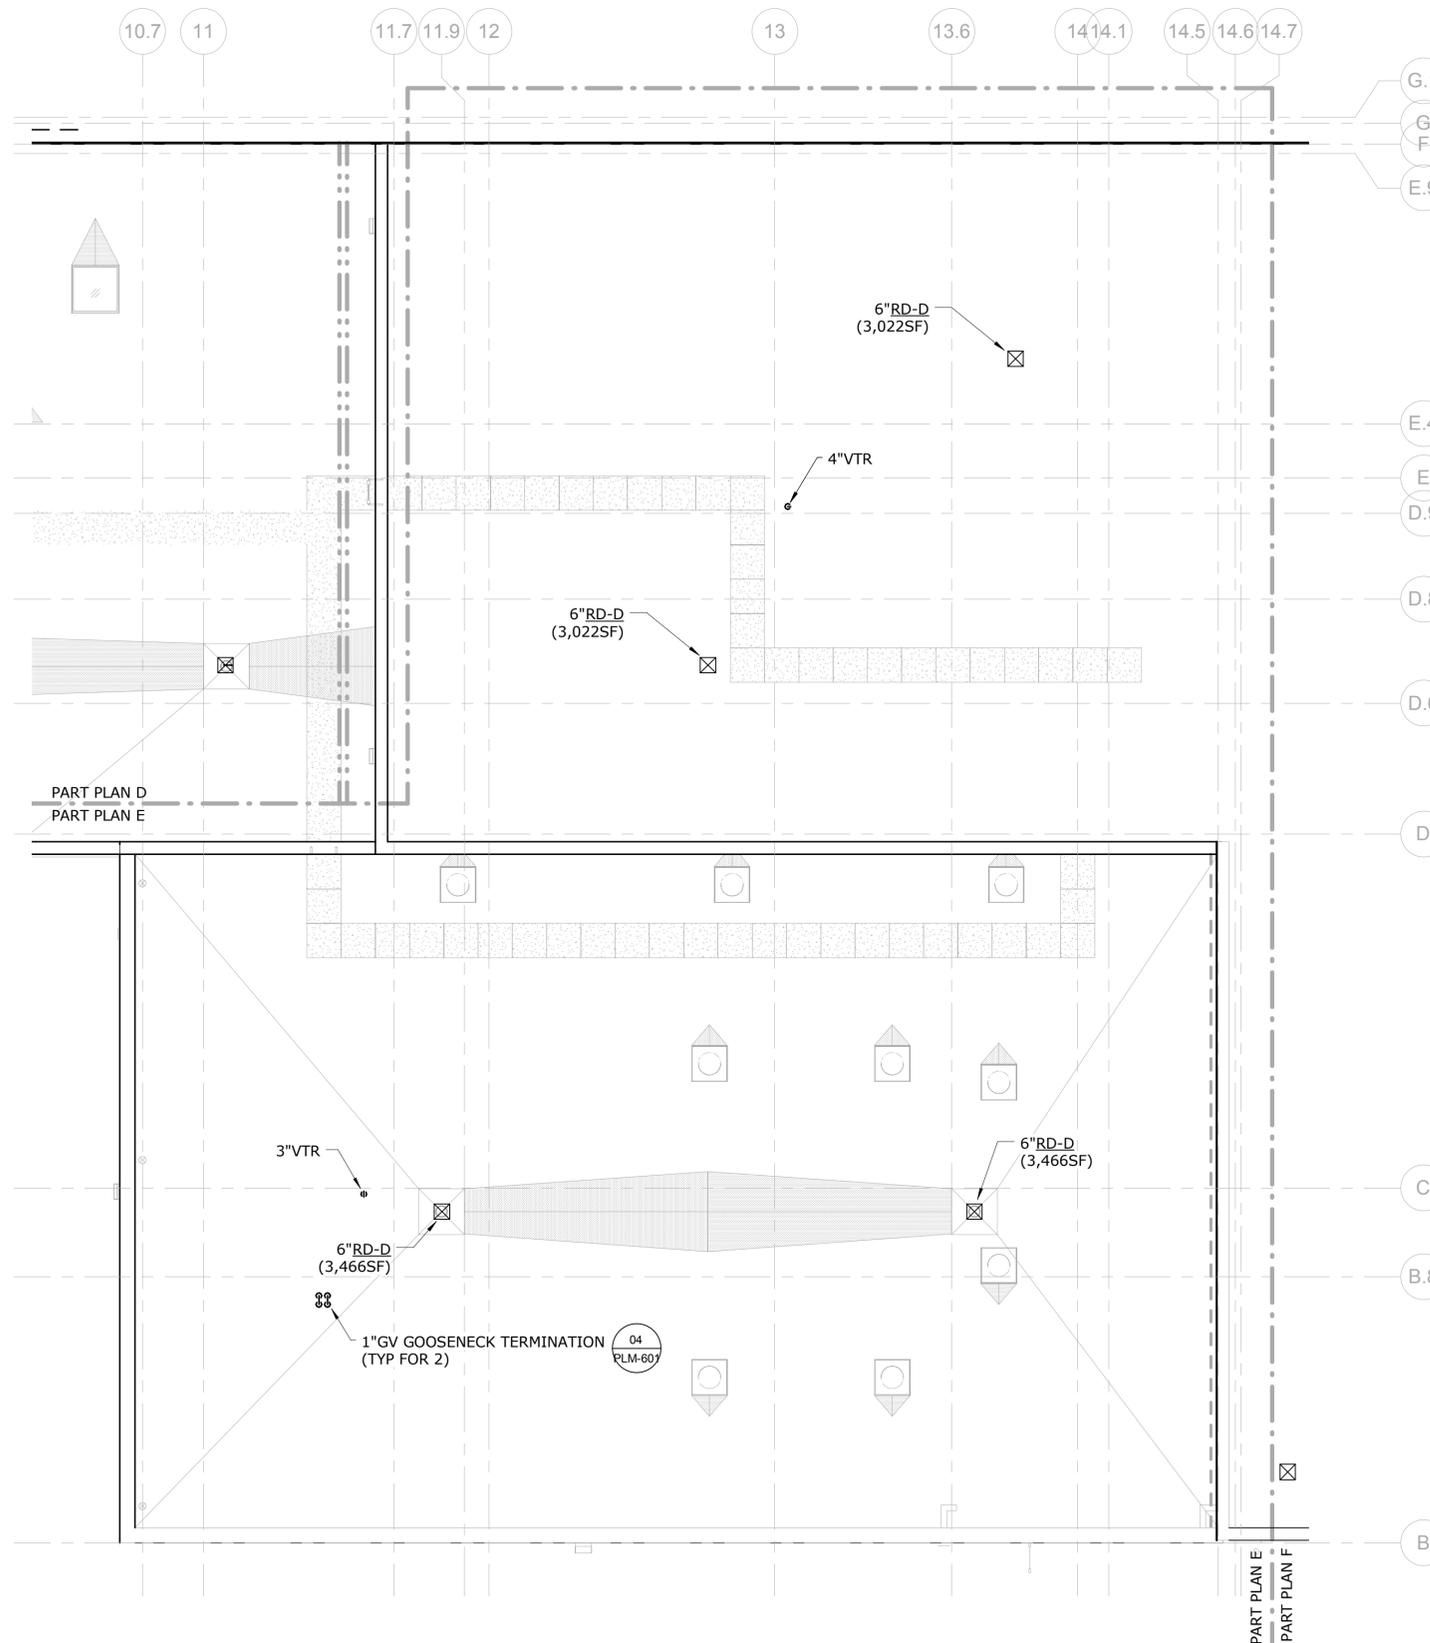

1 PLUMBING - ROOF LEVEL - PART PLAN E
SCALE: 1/8" = 1'-0"

PARTIAL PLAN LEGEND:

- A - NORTH REPAIR BAYS
- B - SOUTH REPAIR BAYS
- C - LUBE AND WASH BAYS
- D - STORES
- E - OFFICE AREA
- F - MACHINE SHOP
- G - PAINT AREA

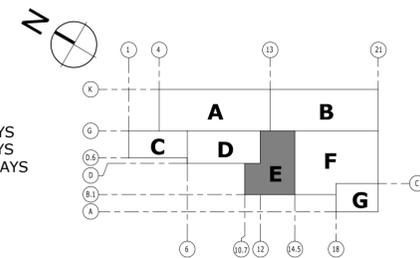

KEY PLAN

NO.	Revision Description	Date

THE INFORMATION, INCLUDING ESTIMATED QUANTITIES OF WORK, SHOWN ON THESE SHEETS IS BASED ON LIMITED INVESTIGATIONS BY THE STATE AND IS IN NO WAY WARRANTED TO INDICATE THE CONDITIONS OF ACTUAL QUANTITIES OF WORK WHICH WILL BE REQUIRED.

DESIGNER/DRAFTER
RHL
CHECKED BY:
RSL
SCALE
1/8" = 1'-0"



SIGNATURE/BLOCK:
[Signature]


PROJECT TITLE
REPAIR FACILITY

TOWN
ROCKY HILL
DRAWING TITLE
PLUMBING ROOF - PART PLAN E

PROJECT NO.
118-0167
DRAWING NO.
PLM-405
SHEET NO.
09.35


Plotted: 10/21/2014 3:43:17 PM

File Name: MPPP_CTDOT_Rocky Hill Repair Facility_Central.rvt

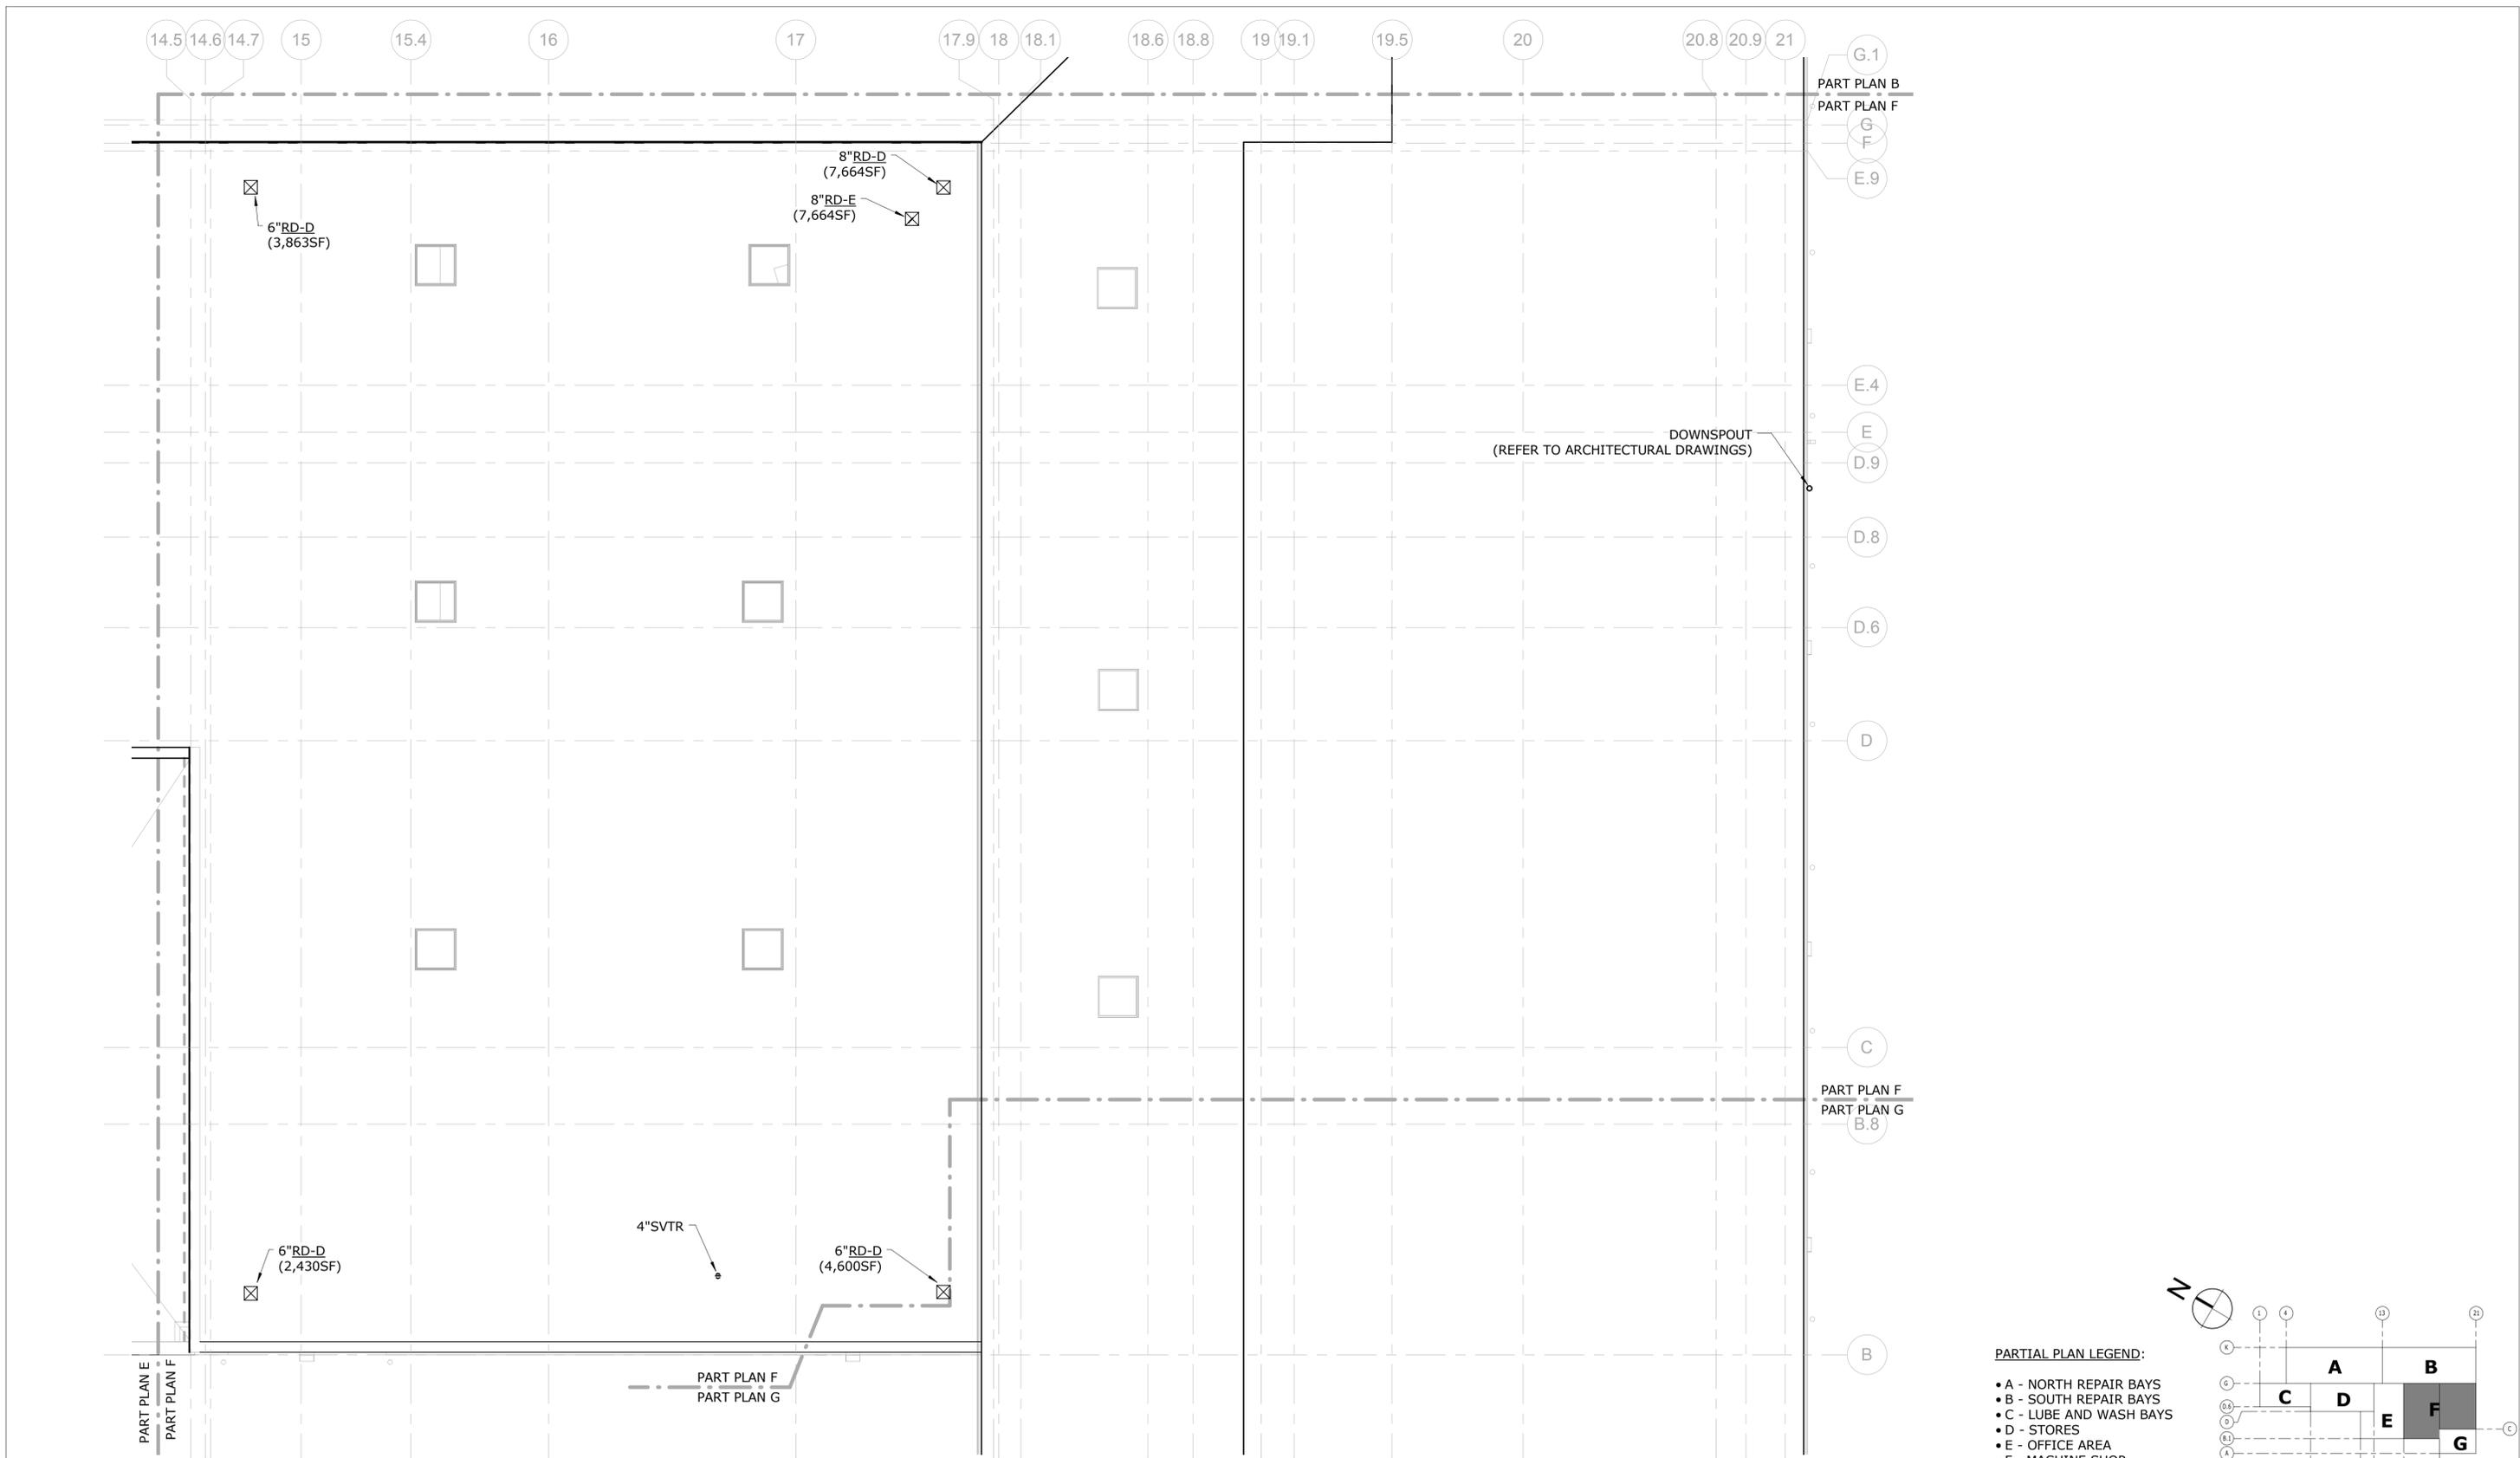

1 PLUMBING - ROOF LEVEL - PART PLAN F
SCALE: 1/8" = 1'-0"

- PARTIAL PLAN LEGEND:**
- A - NORTH REPAIR BAYS
 - B - SOUTH REPAIR BAYS
 - C - LUBE AND WASH BAYS
 - D - STORES
 - E - OFFICE AREA
 - F - MACHINE SHOP
 - G - PAINT AREA

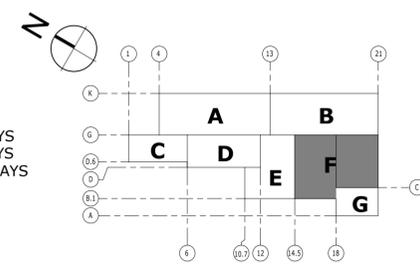

NO.	Revision Description	Date

THE INFORMATION, INCLUDING ESTIMATED QUANTITIES OF WORK, SHOWN ON THESE SHEETS IS BASED ON LIMITED INVESTIGATIONS BY THE STATE AND IS IN NO WAY WARRANTED TO INDICATE THE CONDITIONS OF ACTUAL QUANTITIES OF WORK WHICH WILL BE REQUIRED.

DESIGNER/DRAFTER
RHL
CHECKED BY:
RSL
SCALE
1/8" = 1'-0"



SIGNATURE/BLOCK:
[Signature]


PROJECT TITLE
REPAIR FACILITY

TOWN
ROCKY HILL
DRAWING TITLE
PLUMBING ROOF - PART PLAN F

PROJECT NO.
118-0167
DRAWING NO.
PLM-406
SHEET NO.
09.36

Plotted: 10/21/2014 3:43:20 PM


File Name: MPPP_CTDOT_Rocky Hill Repair Facility_Central.rvt

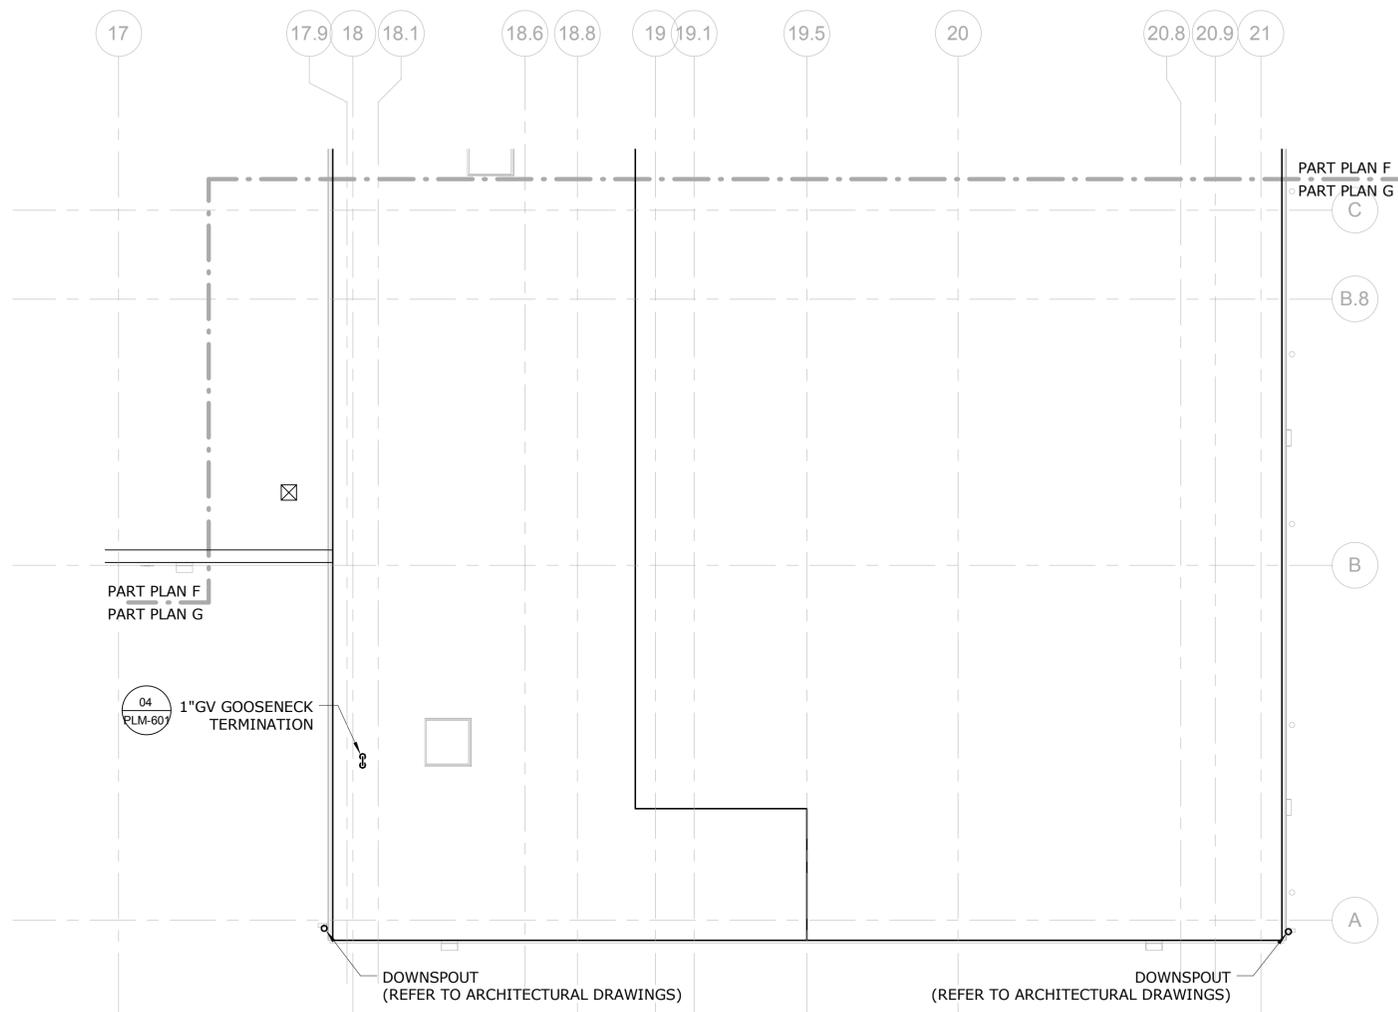

1 PLUMBING - ROOF LEVEL - PART PLAN G
SCALE: 1/8" = 1'-0"

PARTIAL PLAN LEGEND:

- A - NORTH REPAIR BAYS
- B - SOUTH REPAIR BAYS
- C - LUBE AND WASH BAYS
- D - STORES
- E - OFFICE AREA
- F - MACHINE SHOP
- G - PAINT AREA

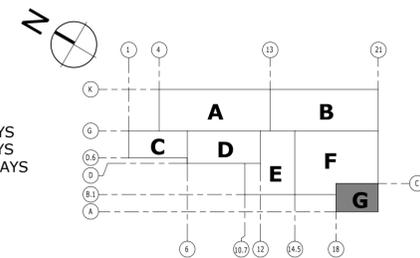

KEY PLAN

NO.	Revision Description	Date

THE INFORMATION, INCLUDING ESTIMATED QUANTITIES OF WORK, SHOWN ON THESE SHEETS IS BASED ON LIMITED INVESTIGATIONS BY THE STATE AND IS IN NO WAY WARRANTED TO INDICATE THE CONDITIONS OF ACTUAL QUANTITIES OF WORK WHICH WILL BE REQUIRED.

Plotted: 10/21/2014 3:43:22 PM

DESIGNER/DRAFTER
RHL

CHECKED BY:
RSL

SCALE
1/8" = 1'-0"



File Name: MPPP_CTDOT_Rocky Hill Repair Facility_Central.rvt

SIGNATURE/BLOCK:

PROJECT TITLE
REPAIR FACILITY


TOWN
ROCKY HILL

DRAWING TITLE
PLUMBING ROOF - PART PLAN G

PROJECT NO.
118-0167

DRAWING NO.
PLM-407

SHEET NO.
09.37

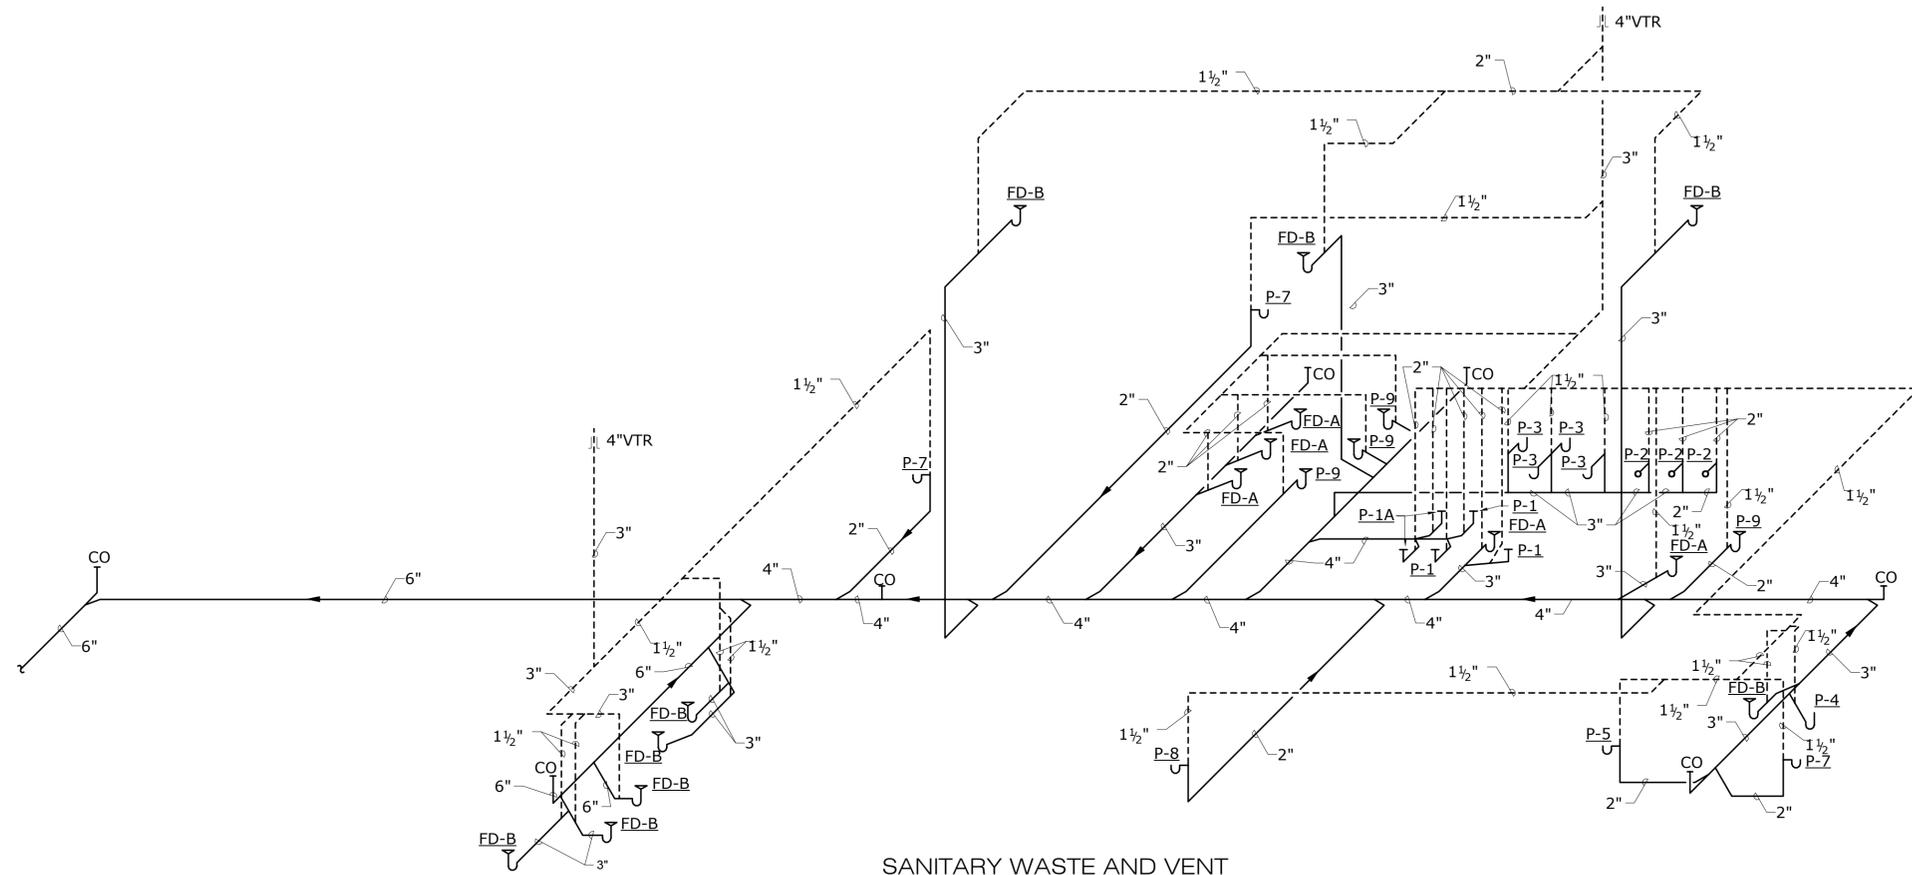

**SANITARY WASTE AND VENT
RISER DIAGRAM**
NO SCALE

NO.	Revision Description	Date

THE INFORMATION, INCLUDING ESTIMATED QUANTITIES OF WORK, SHOWN ON THESE SHEETS IS BASED ON LIMITED INVESTIGATIONS BY THE STATE AND IS IN NO WAY WARRANTED TO INDICATE THE CONDITIONS OF ACTUAL QUANTITIES OF WORK WHICH WILL BE REQUIRED.

Plotted: 10/21/2014 3:43:24 PM

DESIGNER/DRAFTER
RSL

CHECKED BY:
RSL

SCALE
N.T.S.



SIGNATURE/BLOCK:

PROJECT TITLE
REPAIR FACILITY


TOWN
ROCKY HILL

DRAWING TITLE
**PLUMBING RISER DIAGRAM
- SANITARY**

PROJECT NO.
118-0167

DRAWING NO.
PLM-500

SHEET NO.
09.38

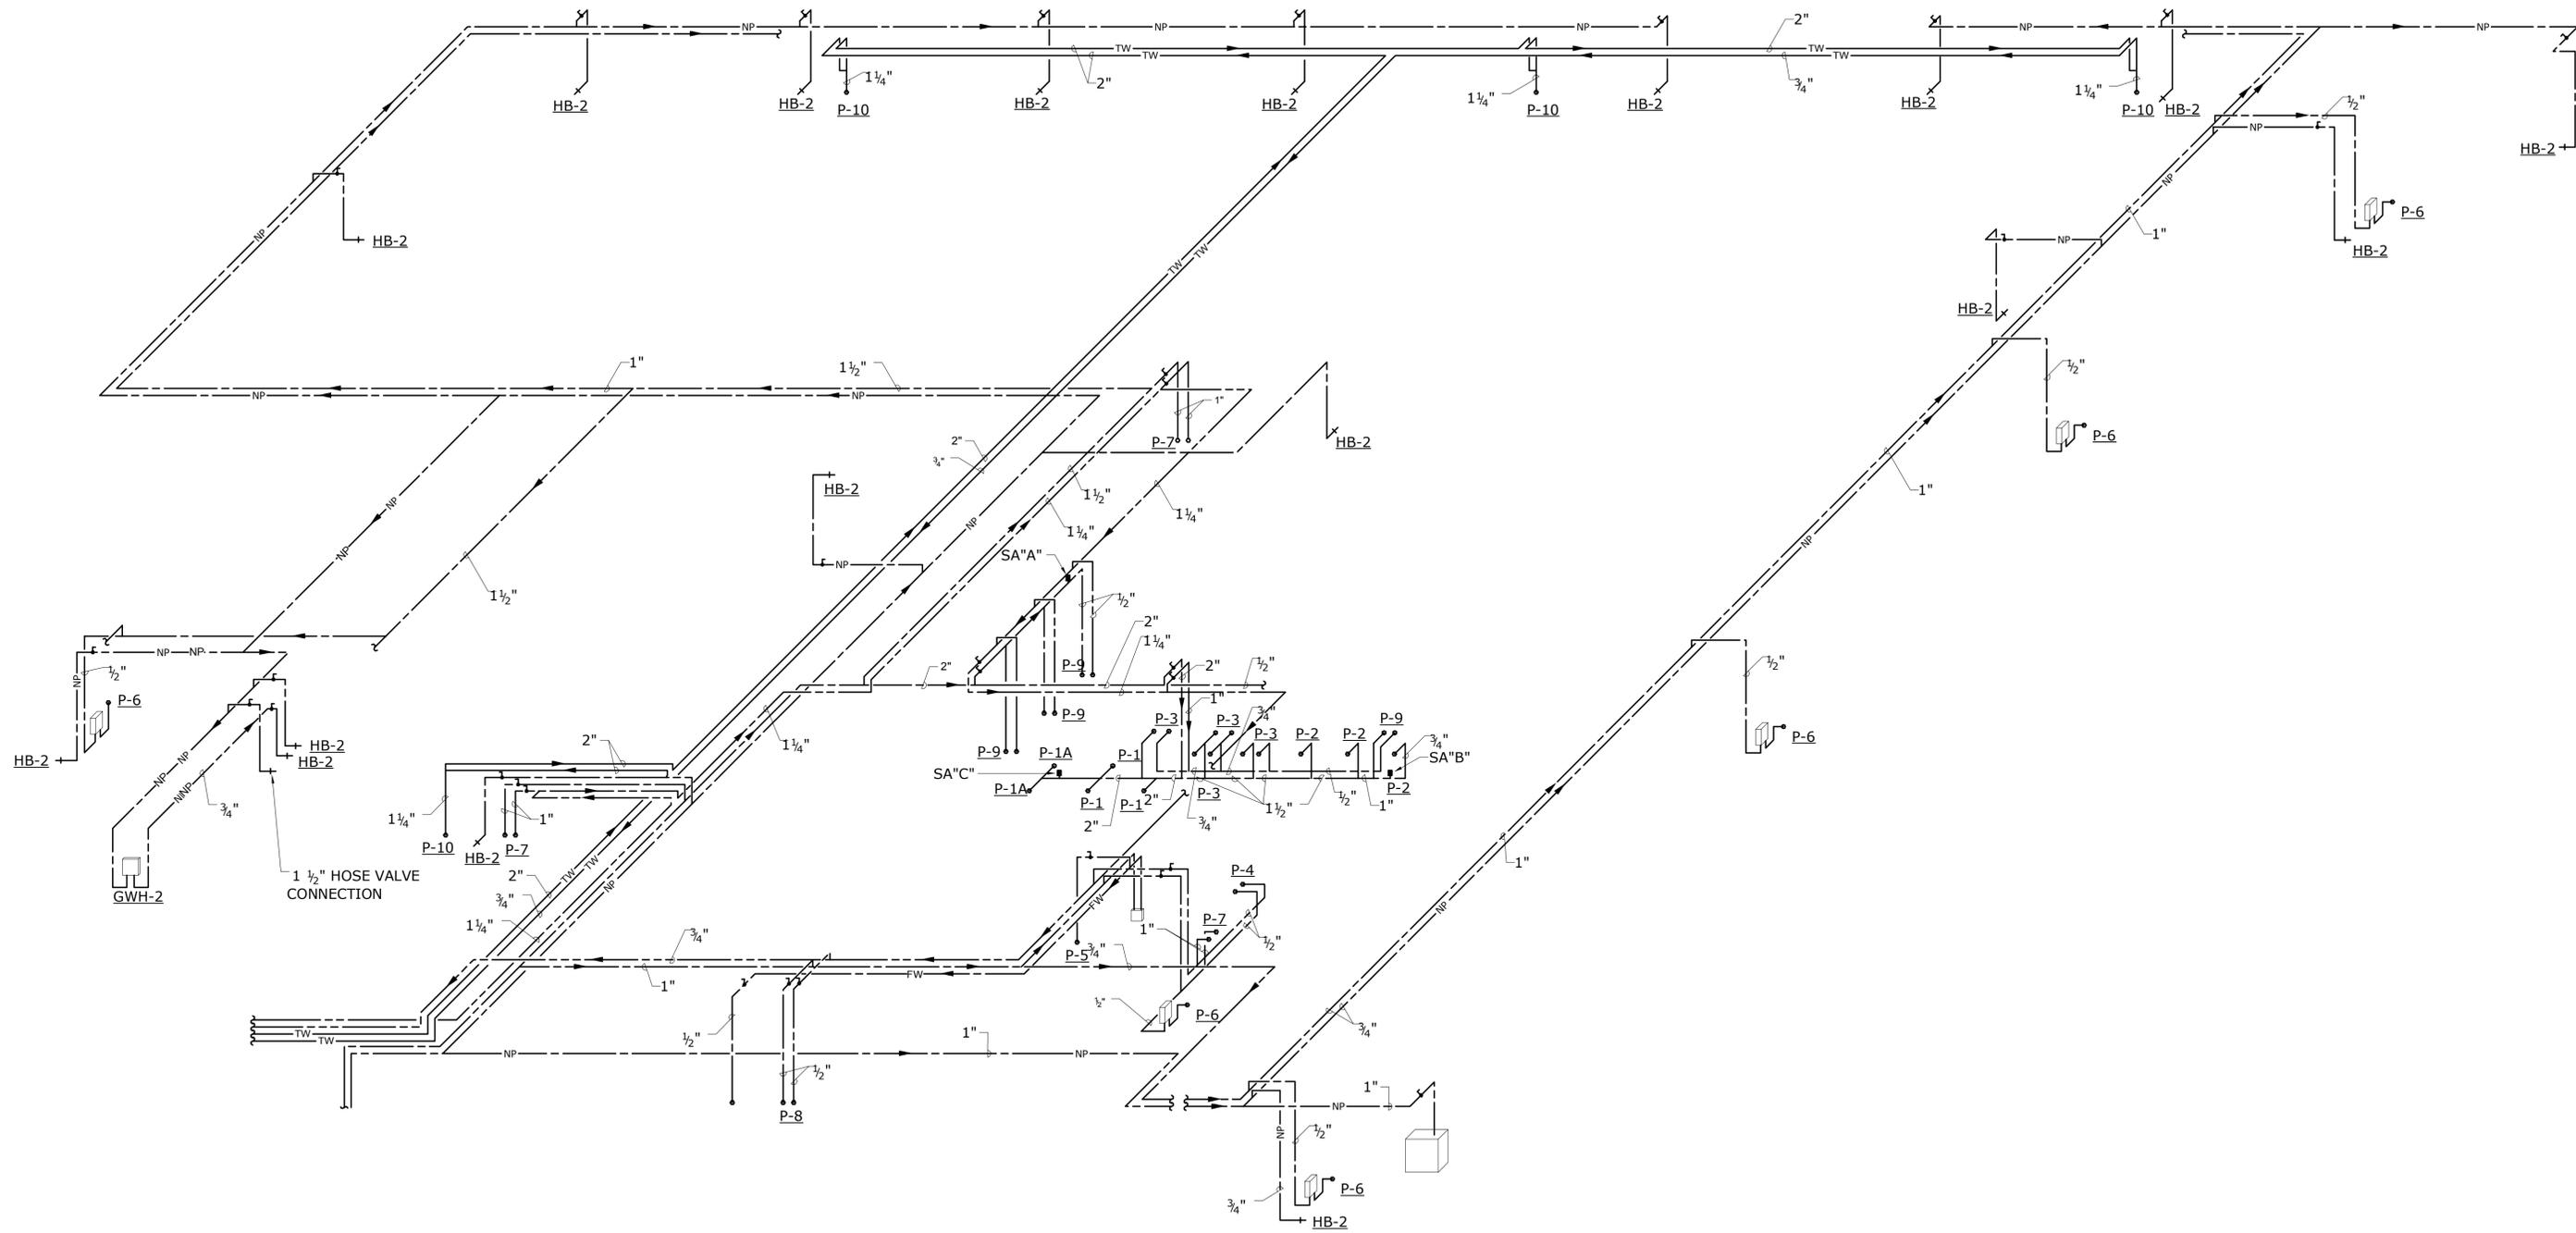

POTABLE WATER SUPPLY
 RISER DIAGRAM
 NO SCALE

NO.	Revision Description	Date

THE INFORMATION, INCLUDING ESTIMATED QUANTITIES OF WORK, SHOWN ON THESE SHEETS IS BASED ON LIMITED INVESTIGATIONS BY THE STATE AND IS IN NO WAY WARRANTED TO INDICATE THE CONDITIONS OF ACTUAL QUANTITIES OF WORK WHICH WILL BE REQUIRED.

Plotted: 10/21/2014 3:43:25 PM

DESIGNER/DRAFTER
RSL

CHECKED BY:
RSL

SCALE
 N.T.S.



SIGNATURE/BLOCK:


PROJECT TITLE
REPAIR FACILITY


TOWN
ROCKY HILL

DRAWING TITLE
PLUMBING RISER DIAGRAM - WATER

PROJECT NO.
118-0167

DRAWING NO.
PLM-501

SHEET NO.
09.39

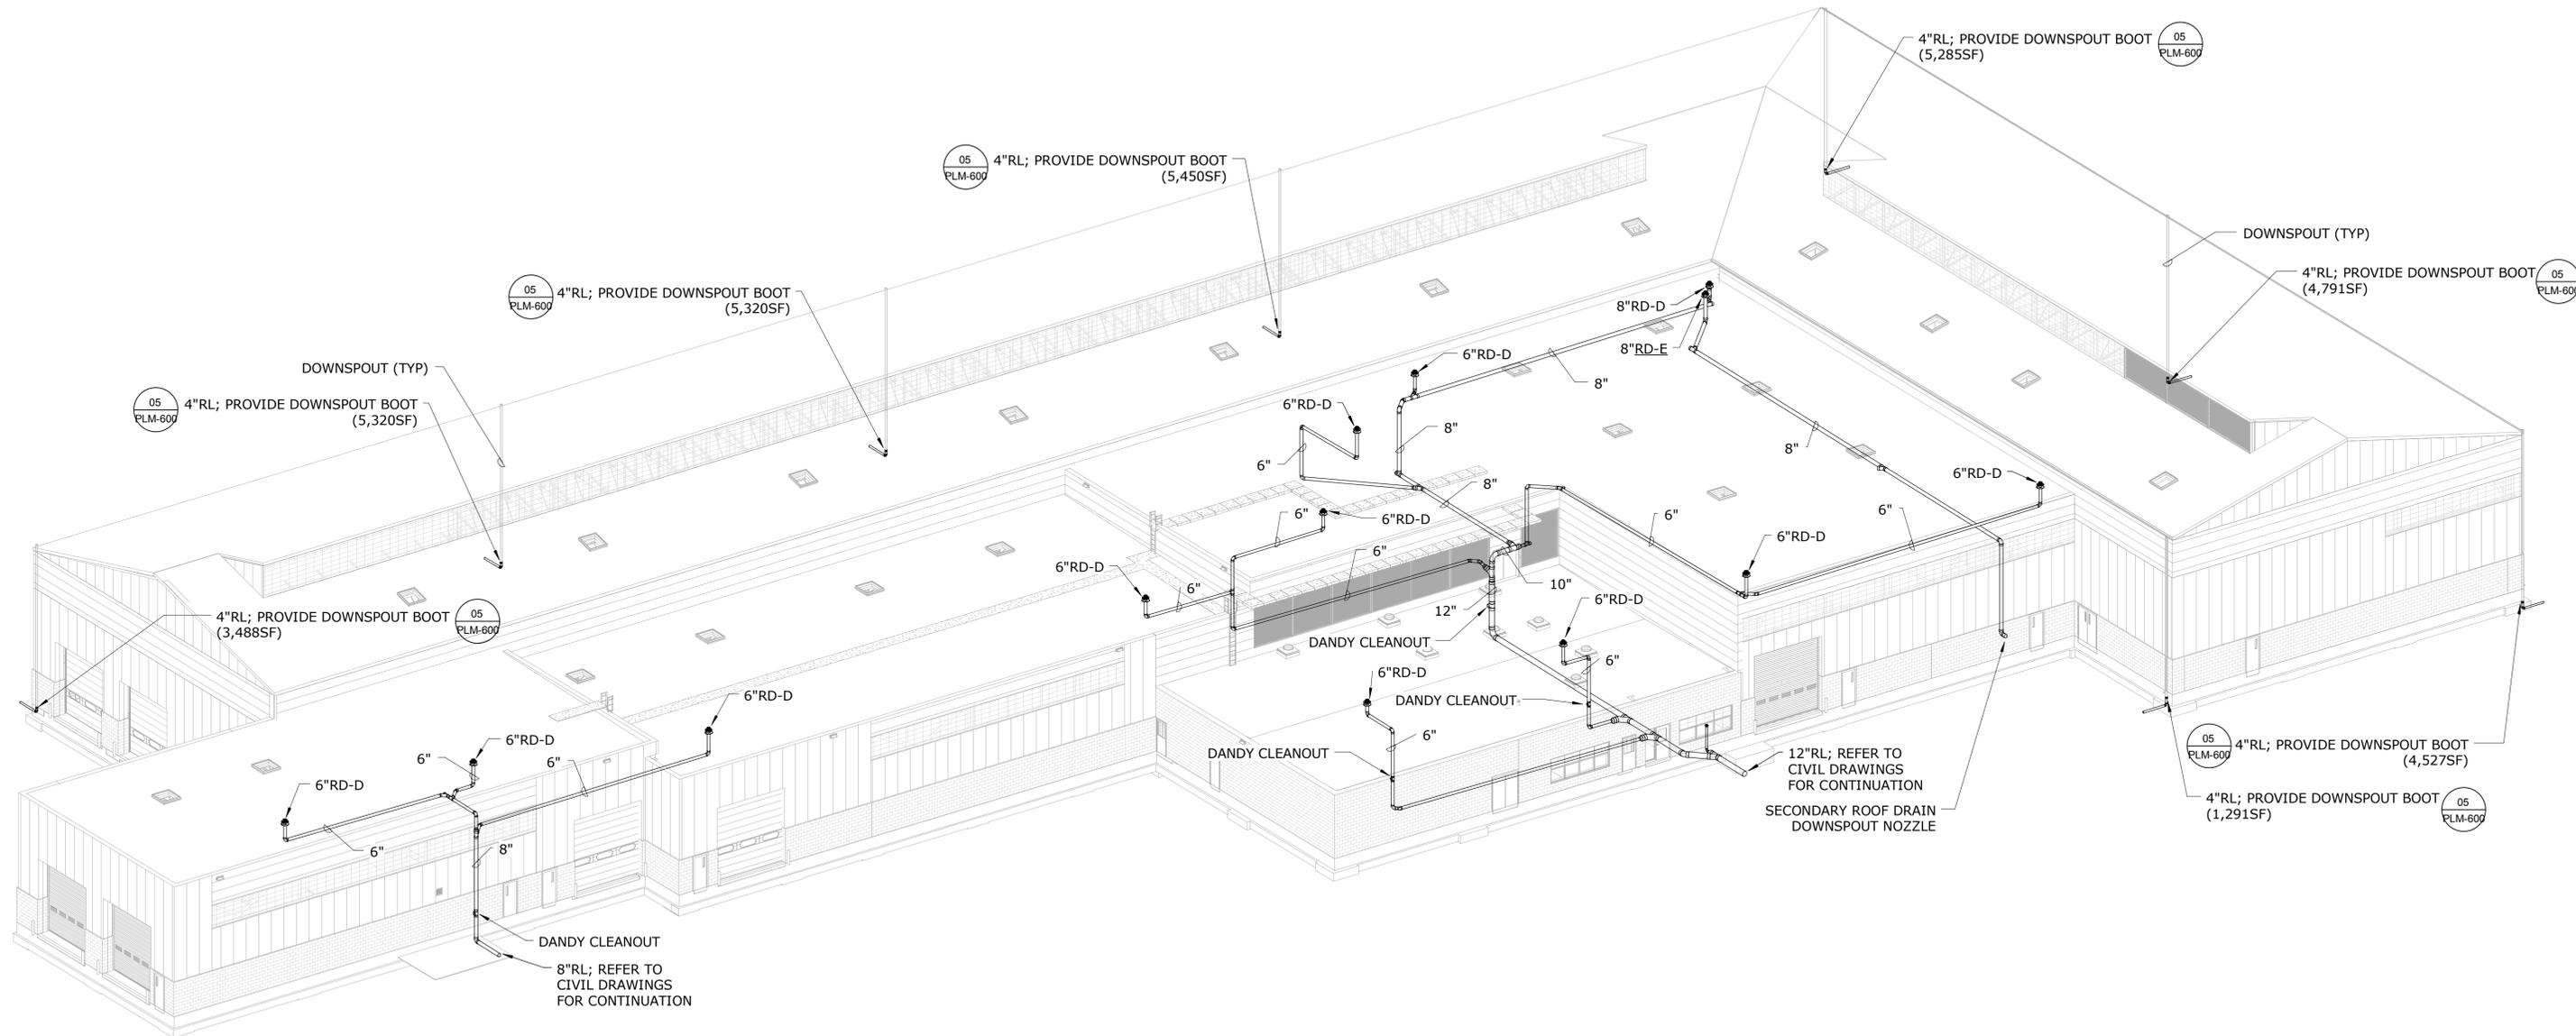

NO.	Revision Description	Date

THE INFORMATION, INCLUDING ESTIMATED QUANTITIES OF WORK, SHOWN ON THESE SHEETS IS BASED ON LIMITED INVESTIGATIONS BY THE STATE AND IS IN NO WAY WARRANTED TO INDICATE THE CONDITIONS OF ACTUAL QUANTITIES OF WORK WHICH WILL BE REQUIRED.

Plotted: 10/21/2014 3:43:38 PM

DESIGNER/DRAFTER
RHL

CHECKED BY:
RSL

SCALE



SIGNATURE/BLOCK:

PROJECT TITLE
REPAIR FACILITY


TOWN
ROCKY HILL

DRAWING TITLE
**PLUMBING RISER DIAGRAM
- RAIN LEADER**

PROJECT NO.
118-0167


DRAWING NO.
PLM-502

SHEET NO.
09.40

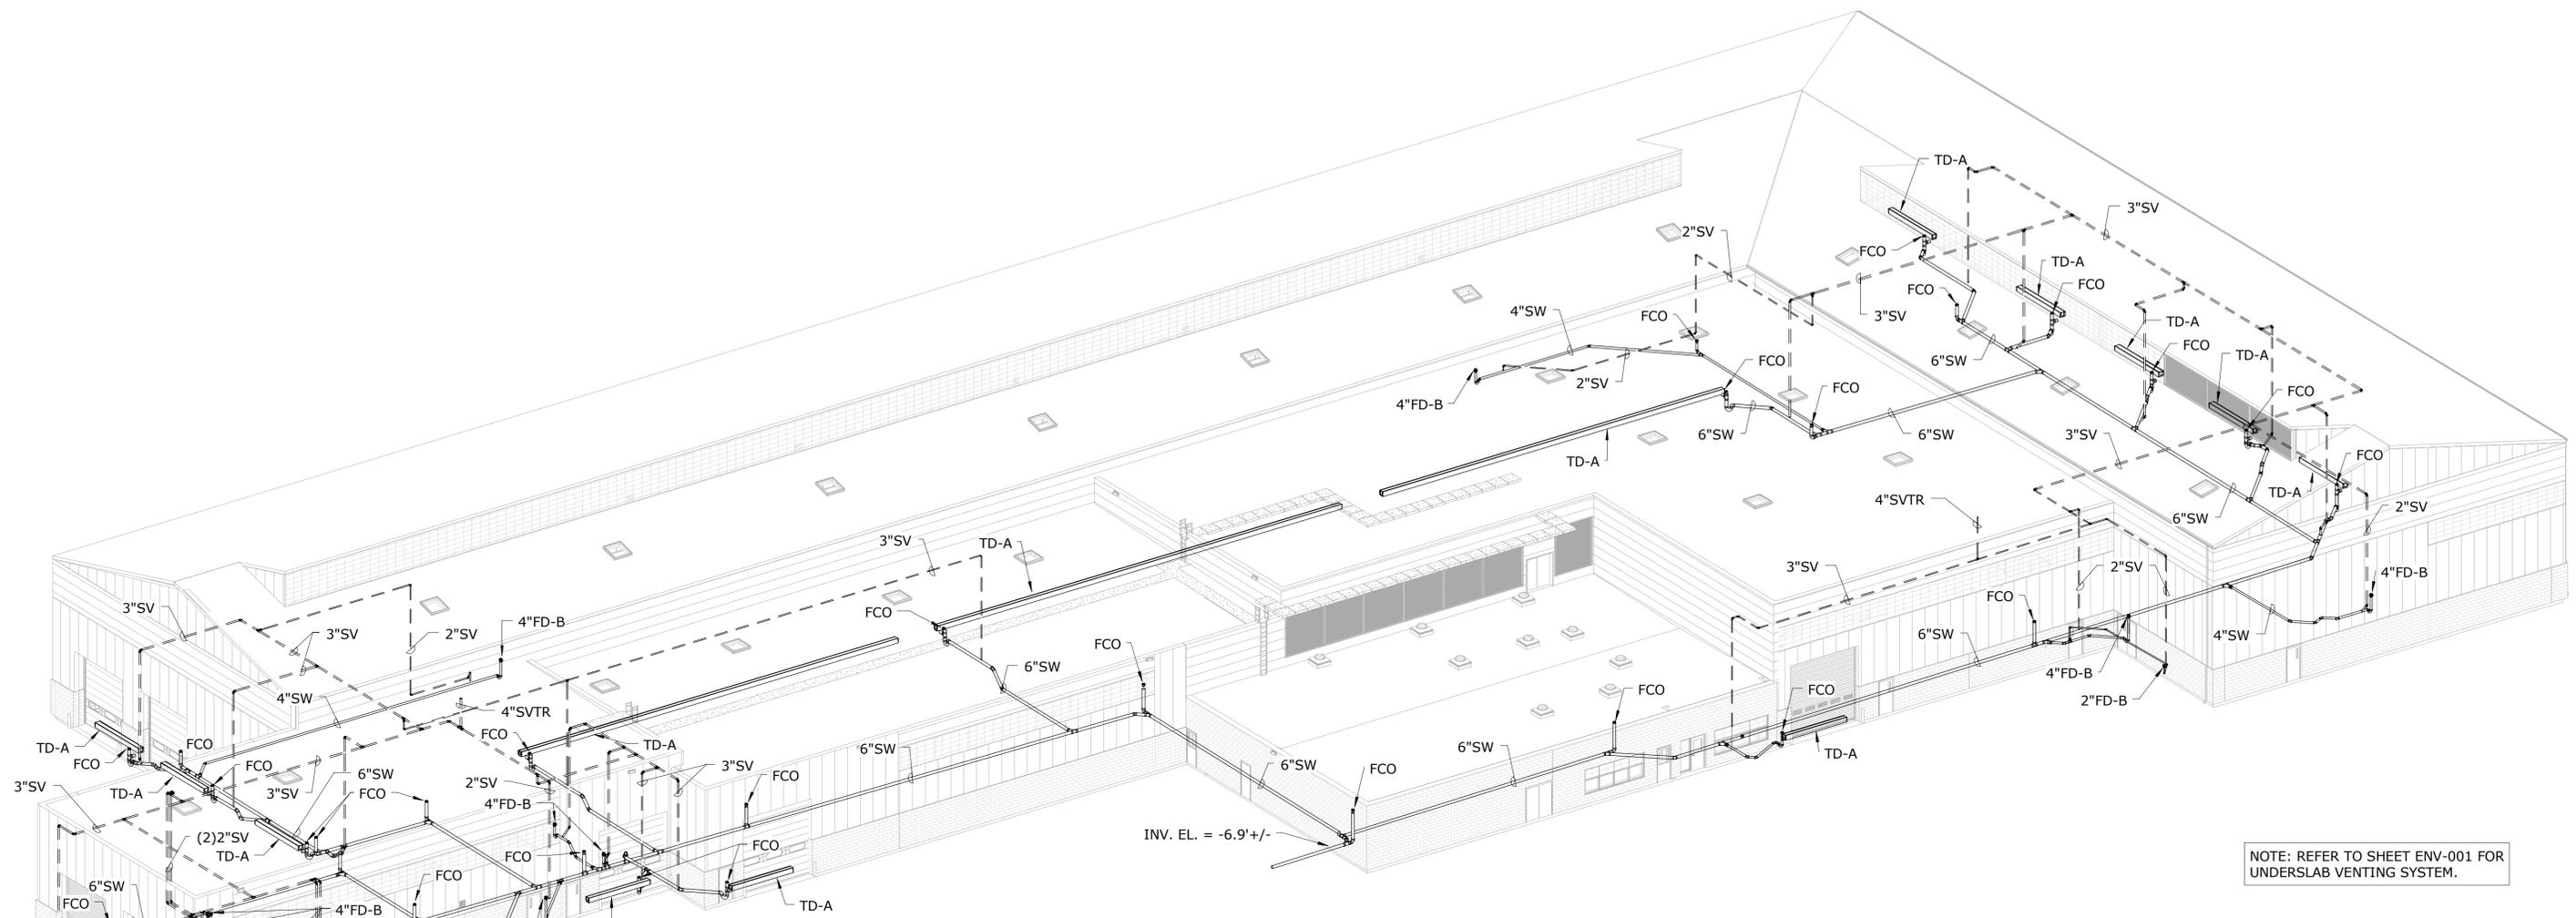

INV. EL. = -6.9' +/-

NOTE: REFER TO SHEET ENV-001 FOR UNDERSLAB VENTING SYSTEM.

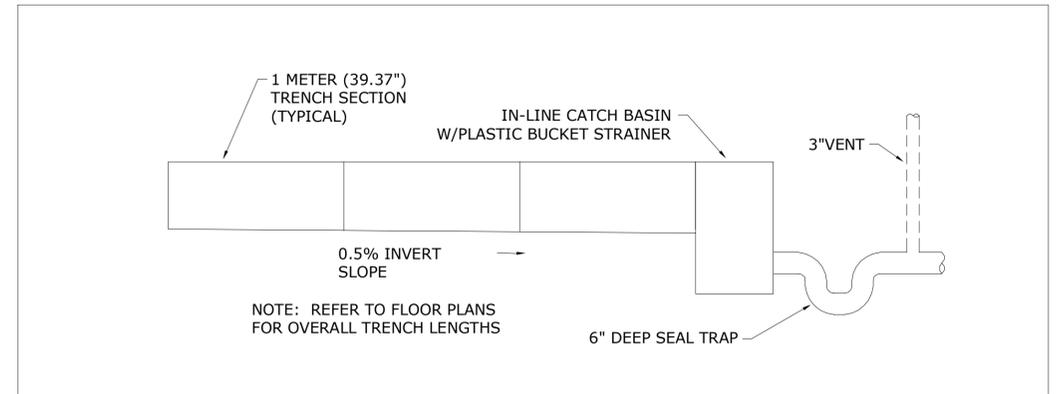

RDK

TRENCH DRAIN DETAIL

01

NO.	Revision Description	Date

THE INFORMATION, INCLUDING ESTIMATED QUANTITIES OF WORK, SHOWN ON THESE SHEETS IS BASED ON LIMITED INVESTIGATIONS BY THE STATE AND IS IN NO WAY WARRANTED TO INDICATE THE CONDITIONS OF ACTUAL QUANTITIES OF WORK WHICH WILL BE REQUIRED.

Plotted: 10/21/2014 3:43:49 PM

DESIGNER/DRAFTER
RHL

CHECKED BY:
RSL

SCALE
1/8" = 1'-0"



SIGNATURE/BLOCK:

PROJECT TITLE
REPAIR FACILITY


TOWN
ROCKY HILL

DRAWING TITLE
**PLUMBING RISER DIAGRAM
- SPECIAL WASTE**


PROJECT NO.
118-0167

DRAWING NO.
PLM-503


SHEET NO.
09.41

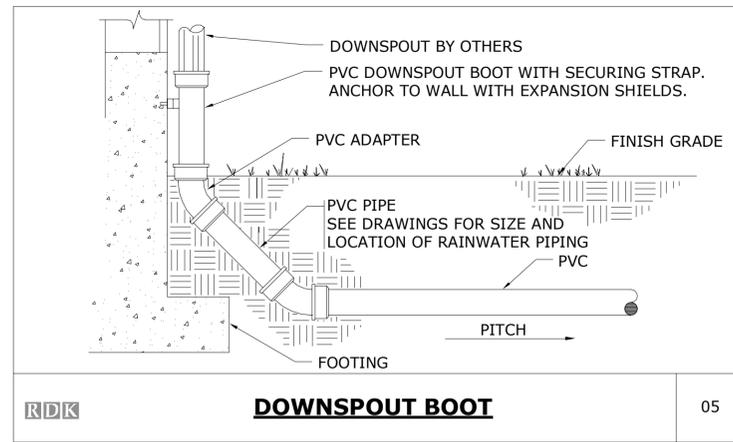


RD&K **DOWNSPOUT BOOT** 05

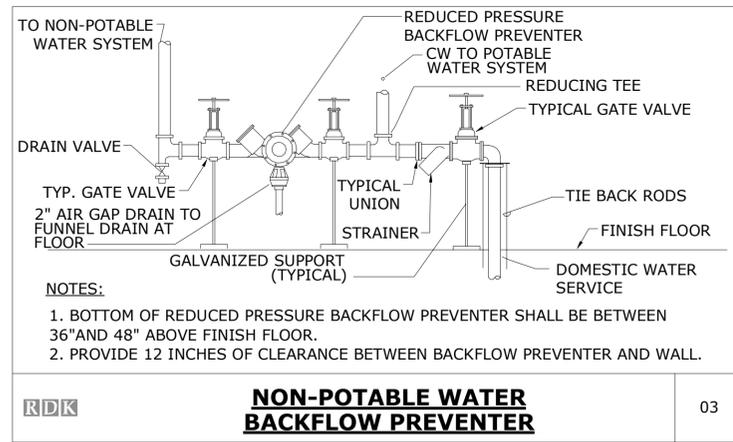


RD&K **NON-POTABLE WATER BACKFLOW PREVENTER** 03

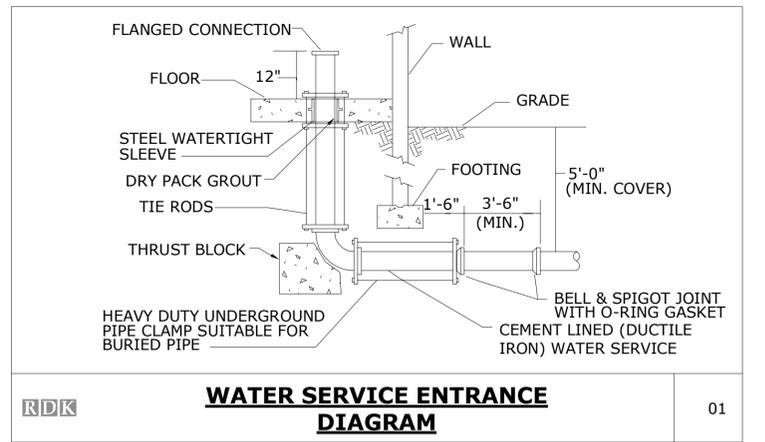


RD&K **WATER SERVICE ENTRANCE DIAGRAM** 01

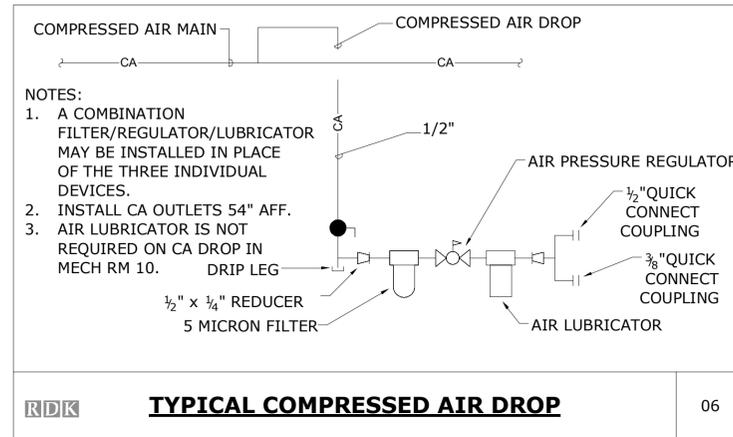


RD&K **TYPICAL COMPRESSED AIR DROP** 06

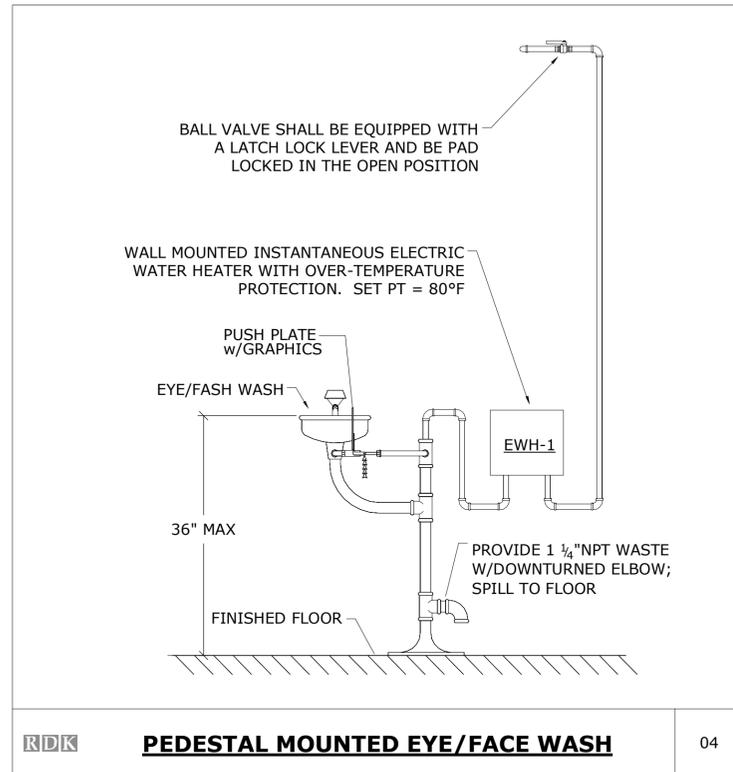


RD&K **PEDESTAL MOUNTED EYE/FACE WASH** 04

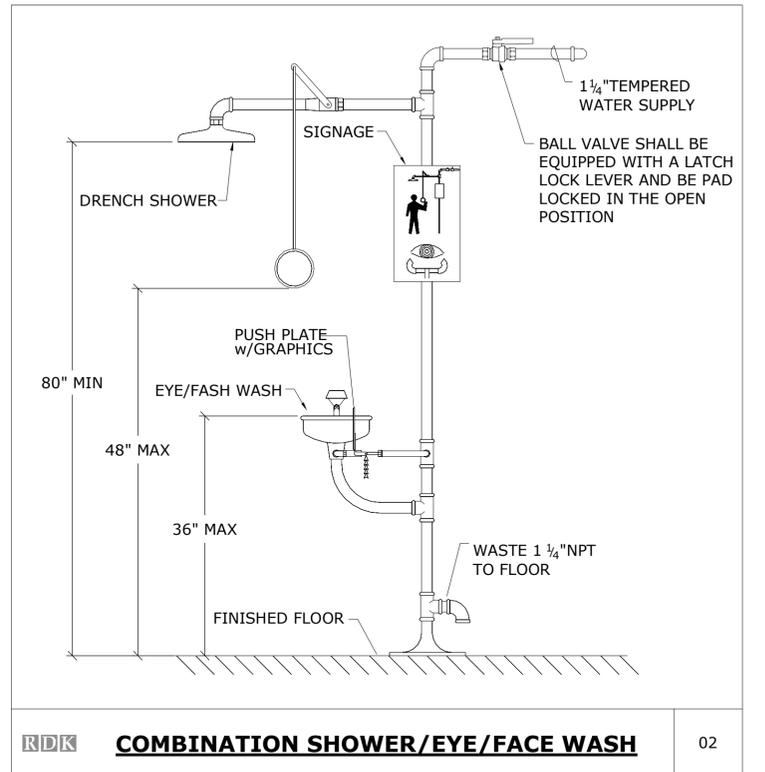


RD&K **COMBINATION SHOWER/EYE/FACE WASH** 02

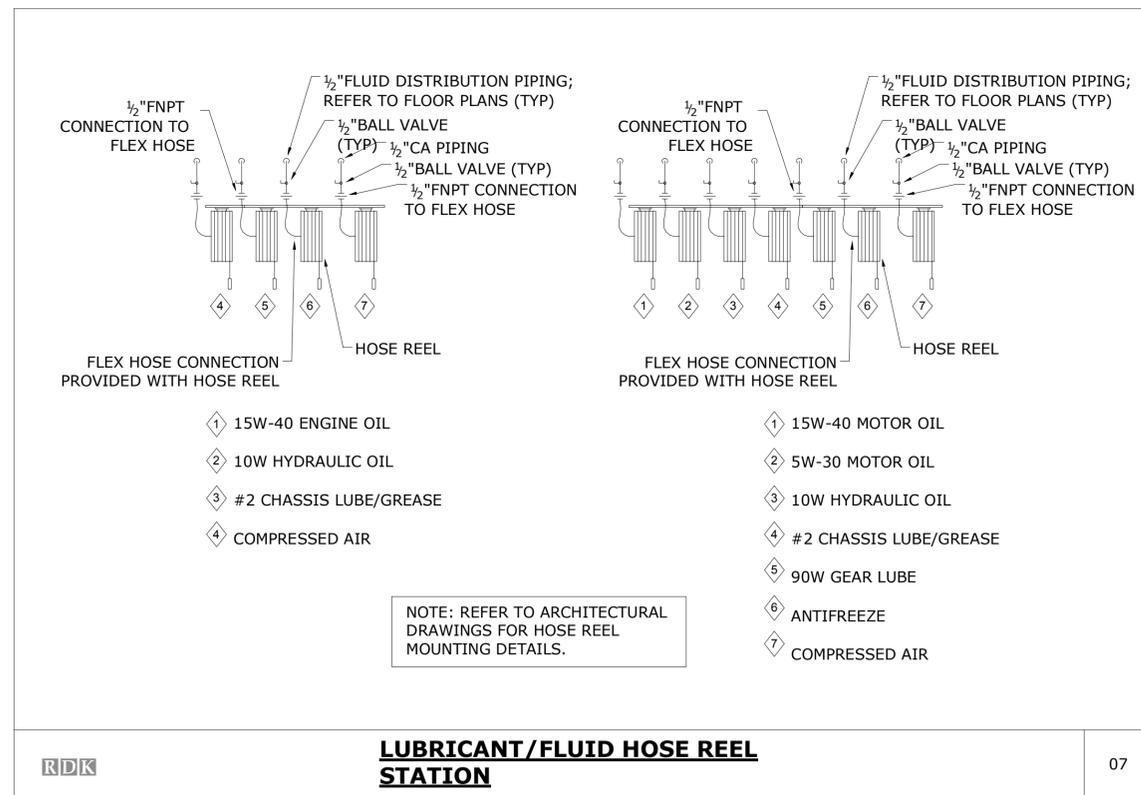

RD&K **LUBRICANT/FLUID HOSE REEL STATION** 07

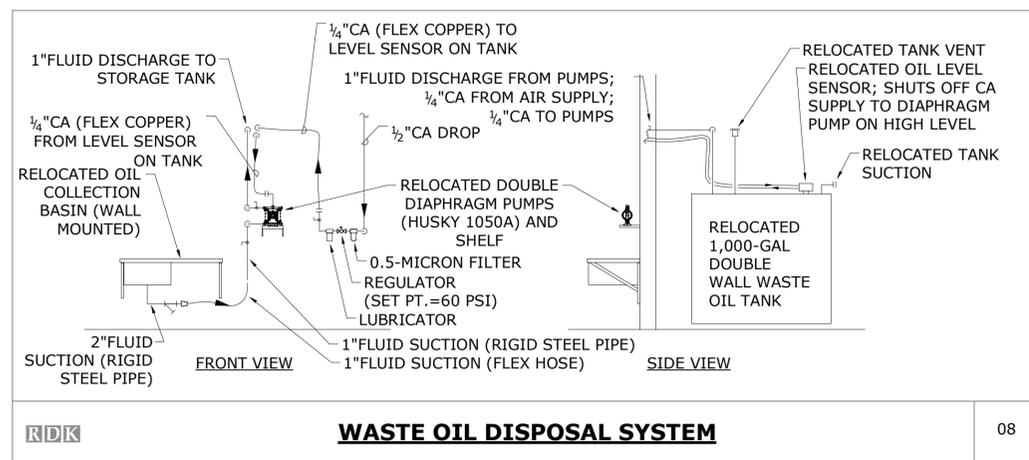

RD&K **WASTE OIL DISPOSAL SYSTEM** 08

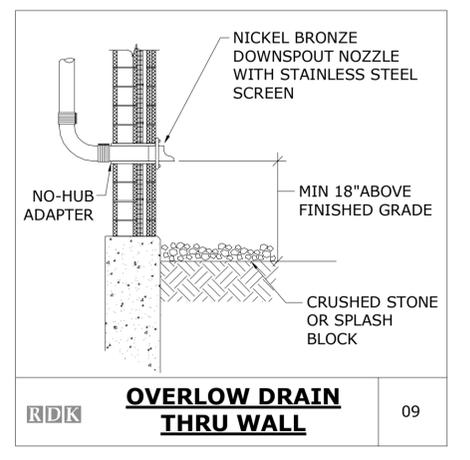

RD&K **OVERFLOW DRAIN THRU WALL** 09

NO.	Revision Description	Date

THE INFORMATION, INCLUDING ESTIMATED QUANTITIES OF WORK, SHOWN ON THESE SHEETS IS BASED ON LIMITED INVESTIGATIONS BY THE STATE AND IS IN NO WAY WARRANTED TO INDICATE THE CONDITIONS OF ACTUAL QUANTITIES OF WORK WHICH WILL BE REQUIRED.

DESIGNER/DRAFTER
RSL
 CHECKED BY:
RSL
 SCALE
N.T.S.








SIGNATURE/BLOCK:
[Signature]

PROJECT TITLE
REPAIR FACILITY

TOWN
ROCKY HILL
 DRAWING TITLE
PLUMBING DETAILS

PROJECT NO.
118-0167
 DRAWING NO.
PLM-600
 SHEET NO.
09.42

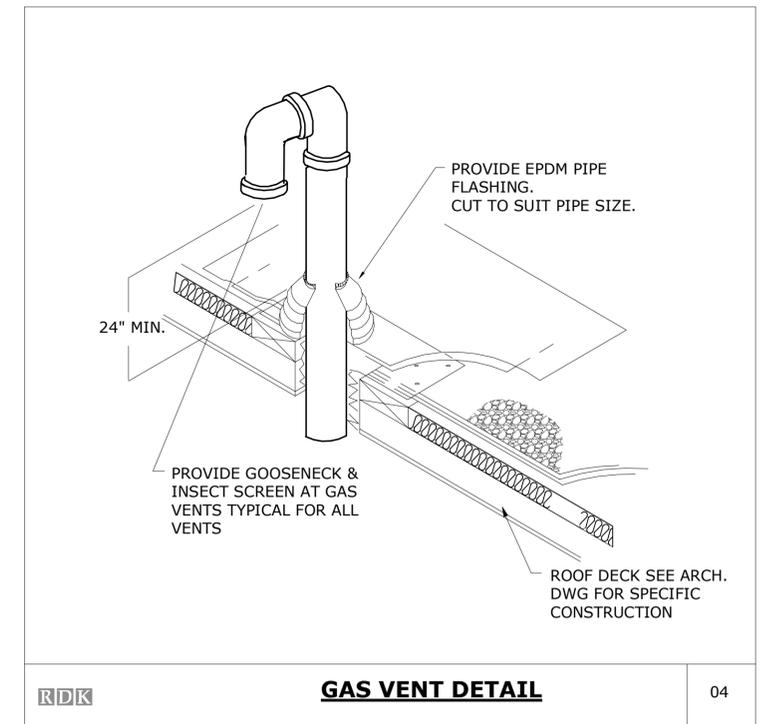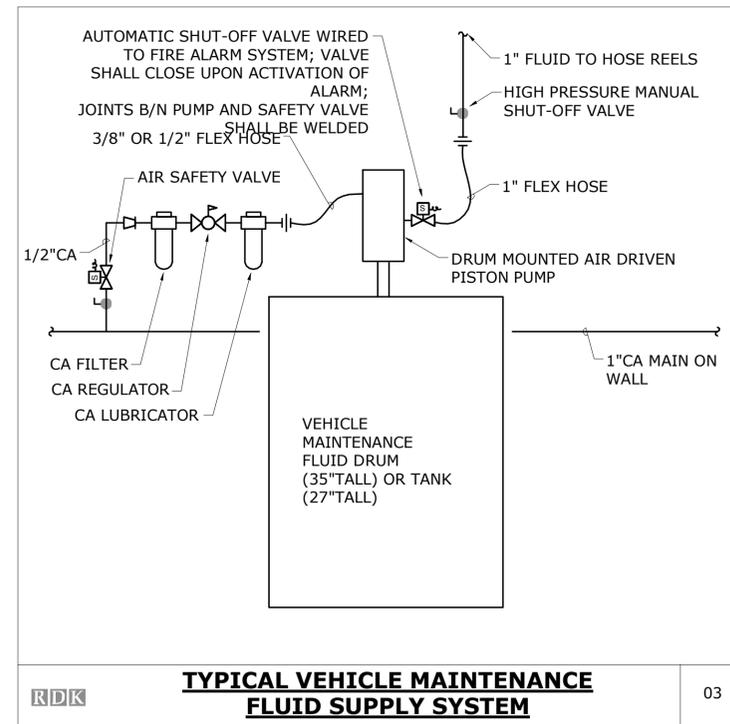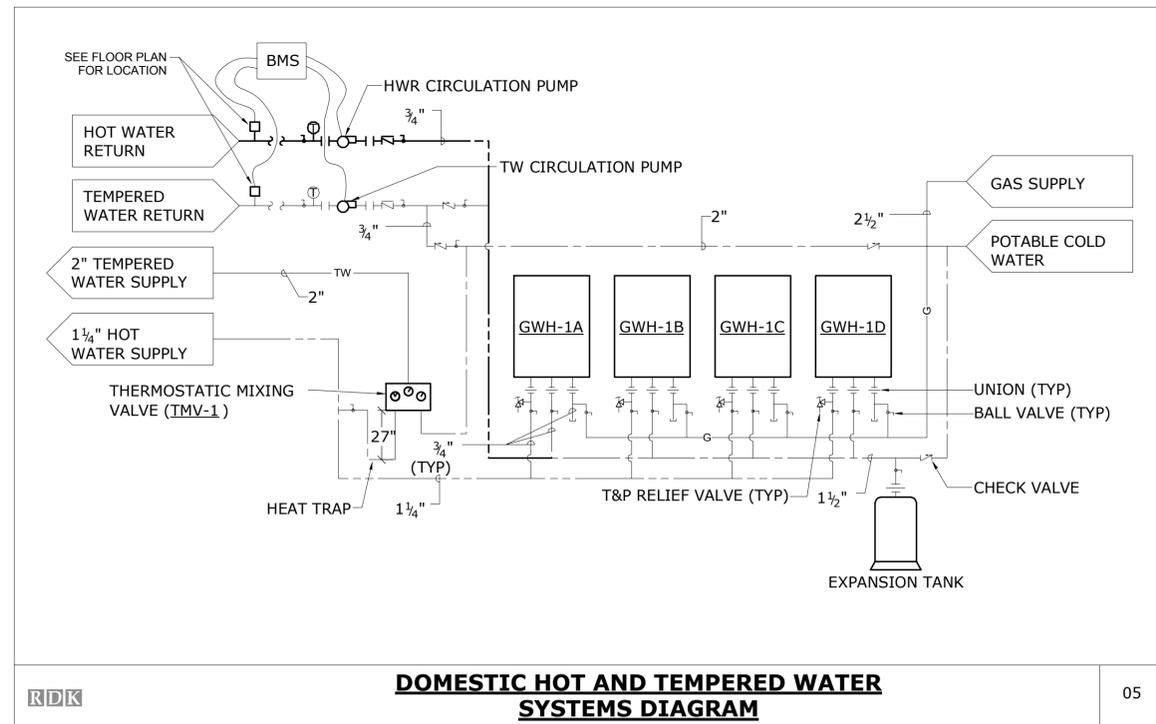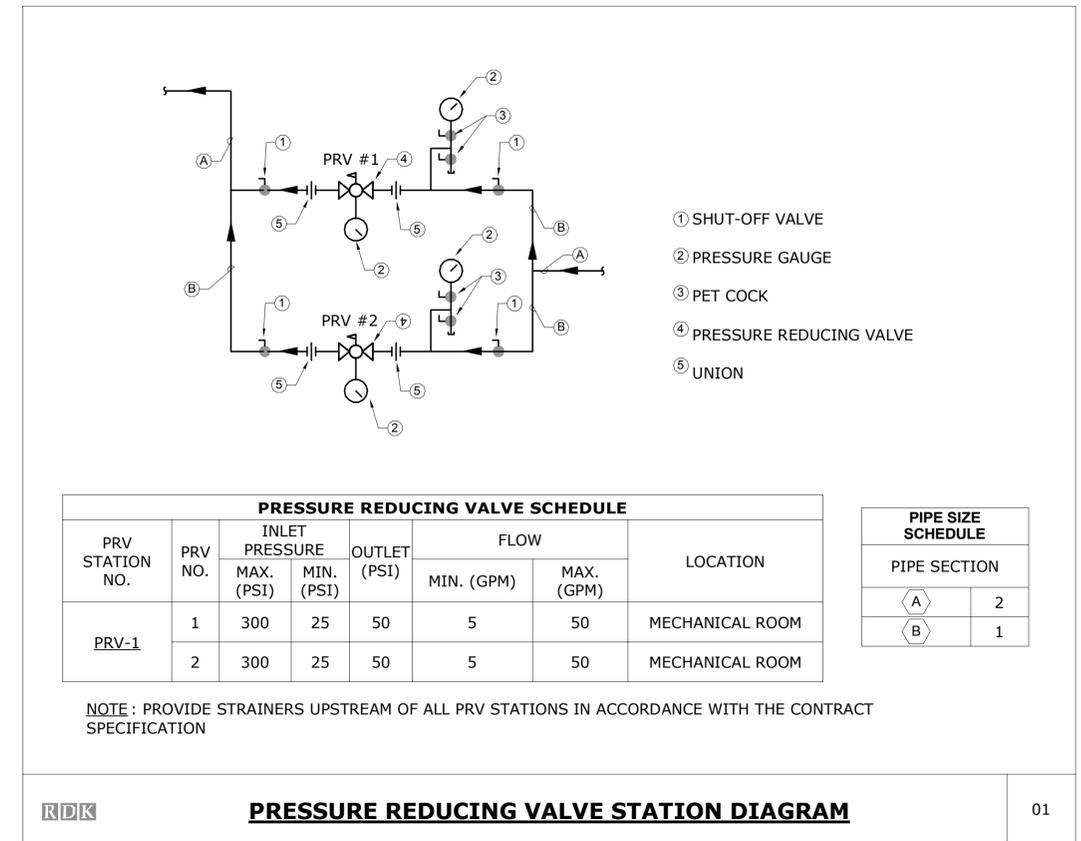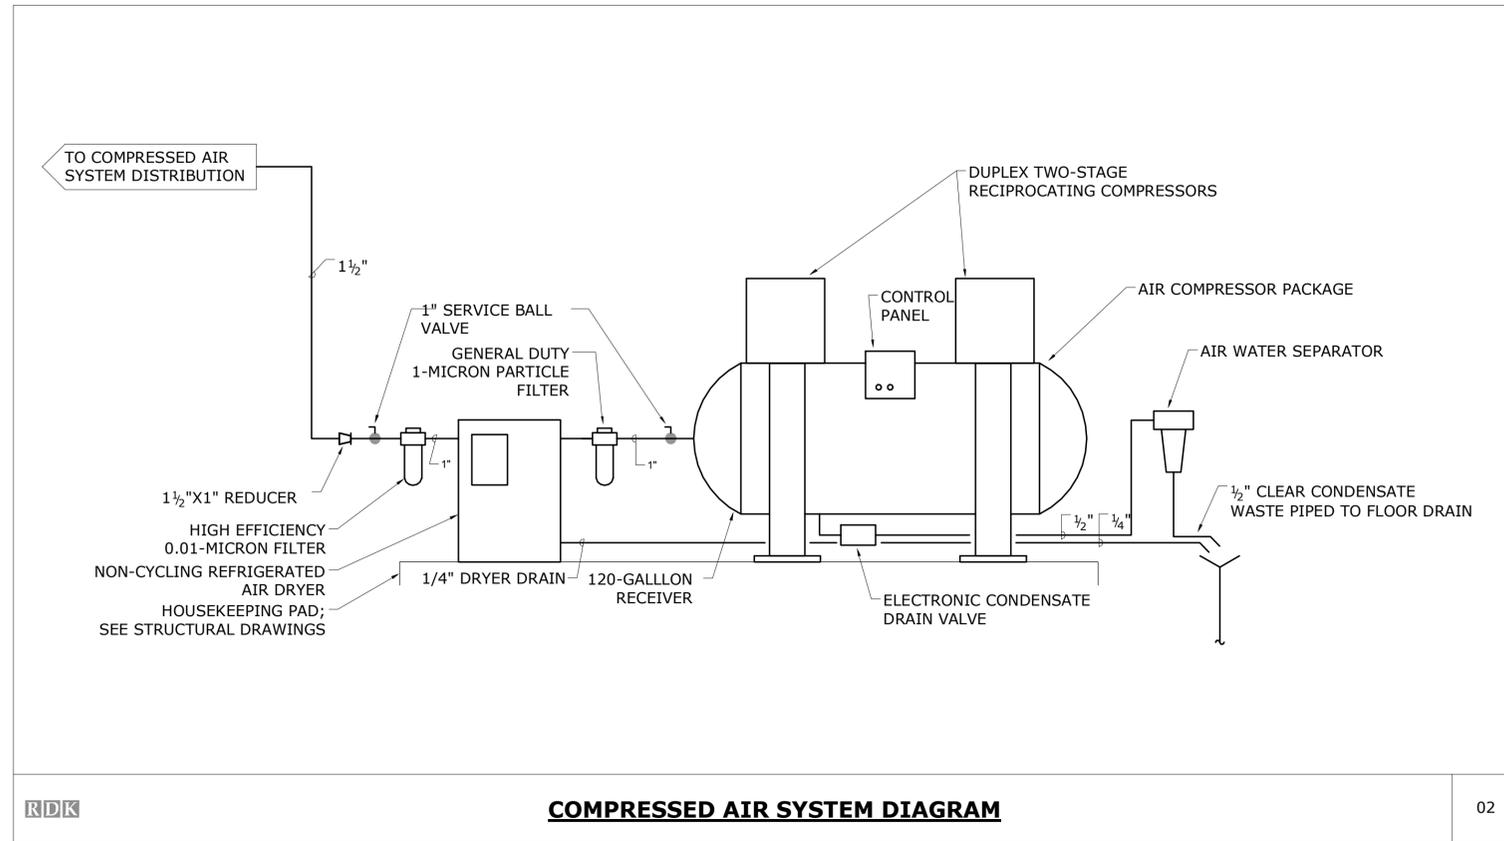

GAS FIRED EQUIPMENT SCHEDULE					
TAG NO. / EQUIPMENT	QTY.	INPUT (EA.) CFH	TOTAL INPUT CFH	REQ'D PRESS. "W.C.	LOCATION
GWH-1	4	200	800	5-10.5	MECH ROOM
GWH-2	1	200	200	5-10.5	LUBRICANT STORAGE/COMPRESSOR ROOM
WB-1/2/3	3	2,200	6,600	4-14	MECH ROOM
RTU-1	1	350	350	2.5-14	ROOF
PAINT BOOTH HEATER	1	3,300	3,300	29-138.5	PAINT BOOTHS ROOM
		TOTAL LOAD	11,250	*HIGH PRESSURE GAS REQUIRED*	

PLUMBING FIXTURE SCHEDULE														
TAG NO.	FIXTURE			FITTING			TRAP	CONNECTIONS						REMARKS
	TYPE	MANUFACTURER	MODEL	TYPE	MANUFACTURER	MODEL		WASTE	VENT	CW	HW	HW140	TW	
P-1	WATER CLOSET	KOHLER	K-4406	MANUAL FLUSH VALVE	SLOAN	ROYAL 111-1.28	INTEGRAL	4"	2"	1"	-	-	-	PROVIDE WAX RING, BOLTS AND SEAT
P-1A	HC WATER CLOSET	KOHLER	K-4405	MANUAL FLUSH VALVE	SLOAN	ROYAL 111-1.28	INTEGRAL	4"	2"	1"	-	-	-	PROVIDE WAX RING, BOLTS AND SEAT; MOUNT AT ADA HEIGHT
P-2	URINAL	KOHLER	K-4904-ET	MANUAL FLUSH VALVE	SLOAN	ROYAL 186-0.5	INTEGRAL	2"	2"	3/4"	-	-	-	
P-3	WALL MOUNT LAVATORY	KOHLER	K-2032	LAVATORY FAUCET	SYMMONS	S-20-2-G-W-.5	1 1/4" X 1 1/2"	1 1/2"	1 1/2"	1/2"	1/2"	-	-	
P-4	MOP SINK	FIAT	MSB-3624	MOP BASIN FAUCET	FIAT	830-AA	3"	3"	2"	1/2"	1/2"	-	-	
P-5	WATER COOLER	HALSEY TAYLOR	HAC8FS-Q-ADA	-	-	-	1 1/4" X 1 1/2"	1 1/2"	1 1/2"	1/2"	-	-	-	
P-6	EMERGENCY EYE/FACE WASH STATION	BRADLEY	S19-210BF	-	-	-	-	-	-	-	-	-	1/2"	EACH EYEWASH SHALL BE EQUIPPED WITH A DEDICATED INSTANTANEOUS ELECTRIC WATER HEATER (EWH-1).
P-7	WASH BASIN	BRADLEY	WF2603	-	-	-	-	1 1/2"	1 1/2"	1"	1"	-	-	
P-8	KITCHEN SINK	JUST MFG	SL-ADA-1921-A-GR	FAUCET	KOHLER	K-15172-TL	1 1/2"	1 1/2"	1 1/2"	1/2"	1/2"	-	-	
P-9	SHOWER	FIAT	A3636.01F	SHOWER CONTROL	SYMMONS	S-96-300-B30-L-V-1.5	-	2"	2"	1/2"	1/2"	-	-	PROVIDE CAST BRASS DRAIN W/ CHROME STRAINER (H30000) W/ ENCLOSURE
P-10	EMERGENCY SHOWER/EYE/FACEWASH	BRADLEY	S19-310BF	-	-	-	-	-	-	-	-	-	1 1/4"	COMBINATION UNITS FED FROM CIRCULATING TEMPERED WATER SYSTEM

AIR COMPRESSOR SCHEDULE											
TAG NO.	TYPE	CAPACITY (ACFM)	DISCHARGE PRESSURE (PSI)	MANUFACTURER	MODEL NO.	ELECTRICAL				AIR RECEIVER TANK (GALS)	LOCATION
						HP	VOLTS	PHASE	HZ		
AC-1	DUPLEX 2-STAGE RECIPROCATING PISTON-TYPE	50.5	125	INGERSOLL RAND	2-7100E15 FP	7.5(x2)	208	3	60	120	LUBRICANT STORAGE/COMPRESSOR ROOM

GAS FIRED WATER HEATER SCHEDULE												
TAG NO.	INPUT (MBH)	RECOVERY		GAS PRESSURE ("W.C.)	FLUE SIZE	TEMP. SETTING (°F)	ELECTRICAL DATA			MANUFACTURER	MODEL NO.	REMARKS
		RATE	DEG. RISE (°F)				VOLTS	PHASE	HZ			
GWH-1	200	5 GPM	80	5.0 - 10.5	4"	120	120	1	60	A.O. SMITH	ATI-540H-N	CENTRAL DOMESTIC HOT WATER. PROVIDE NON-RETURN VALVE ON EACH EXHAUST.
GWH-2	200	5 GPM	80	5.0 - 10.5	4"	120	120	1	60	A.O. SMITH	ATI-540H-N	WASH BAY HOT WATER


WATER HAMMER ARRESTER SCHEDULE		
TYPE	FIXTURE UNIT RATING	MODEL
SA "A"	1-11	JAY R. SMITH 5005
SA "B"	12-32	JAY R. SMITH 5010
SA "C"	33-60	JAY R. SMITH 5020

ELECTRIC WATER HEATER SCHEDULE												
TAG NO.	STORAGE CAPACITY (gal.)	RECOVERY		ELECTRICAL DATA					TEMP. SETTING (°F)	MANUFACTURER	MODEL NO.	REMARKS
		RATE	DEG. RISE (°F)	NO. OF ELEMENTS	TOTAL KW	VOLTS	PHASE	HZ				
EWH-1	0	3 GPM	40	3	18	208	3	60	80	EEMAX	EX180T3 EE	TANKLESS WATER HEATER FOR EMERGENCY EYE/FACE WASH STATIONS


MIXING VALVE SCHEDULE							
TAG NO.	CW INLET	HW INLET	TEMPERED OUTLET	FLOW (GPM) LO/HI	MIXED TEMP. (°F)	MANUFACTURER	MODEL NO.
TMV-1	1 1/4"	1 1/4"	1 1/4"	5/60	85	LAWLER	911-8334

DRAIN SCHEDULE					
TAG NO.	TYPE	MANUFACTURER	MODEL NO.	STRAINER	REMARKS
FD-A	FLOOR DRAIN	WATTS	FD-100-M	6" SQUARE	TOILET ROOM FLOOR DRAIN
FD-B	FLOOR DRAIN	WATTS	FD-330-Y	8" SQUARE	MECHANICAL ROOM FLOOR DRAIN
TD-C	TRENCH DRAIN	ACO POLYMER PRODUCTS, INC.	S300K	12" WIDE	HEAVY DUTY TRENCH DRAIN
RD-D	ROOF DRAIN	WATTS	RD-300	15" □ DOME	FLAT ROOF PRIMARY DRAIN
RD-E	ROOF DRAIN	WATTS	RD-300-W	15" □ DOME	FLAT ROOF OVERFLOW DRAIN

THE INFORMATION, INCLUDING ESTIMATED QUANTITIES OF WORK, SHOWN ON THESE SHEETS IS BASED ON LIMITED INVESTIGATIONS BY THE STATE AND IS IN NO WAY WARRANTED TO INDICATE THE CONDITIONS OF ACTUAL QUANTITIES OF WORK WHICH WILL BE REQUIRED.		DESIGNER/DRAFTER RHL CHECKED BY: RSL SCALE NONE	 STATE OF CONNECTICUT DEPARTMENT OF TRANSPORTATION <small>File Name: MPPP_CTDOT_Rocky Hill Repair Facility_Central.rvt</small>	SIGNATURE/BLOCK: 	PROJECT TITLE REPAIR FACILITY	TOWN ROCKY HILL	PROJECT NO. 118-0167
NO. Revision Description Date		Plotted: 10/21/2014 3:43:57 PM		DRAWING TITLE PLUMBING SCHEDULES		DRAWING NO. PLM-700	SHEET NO. 09.44

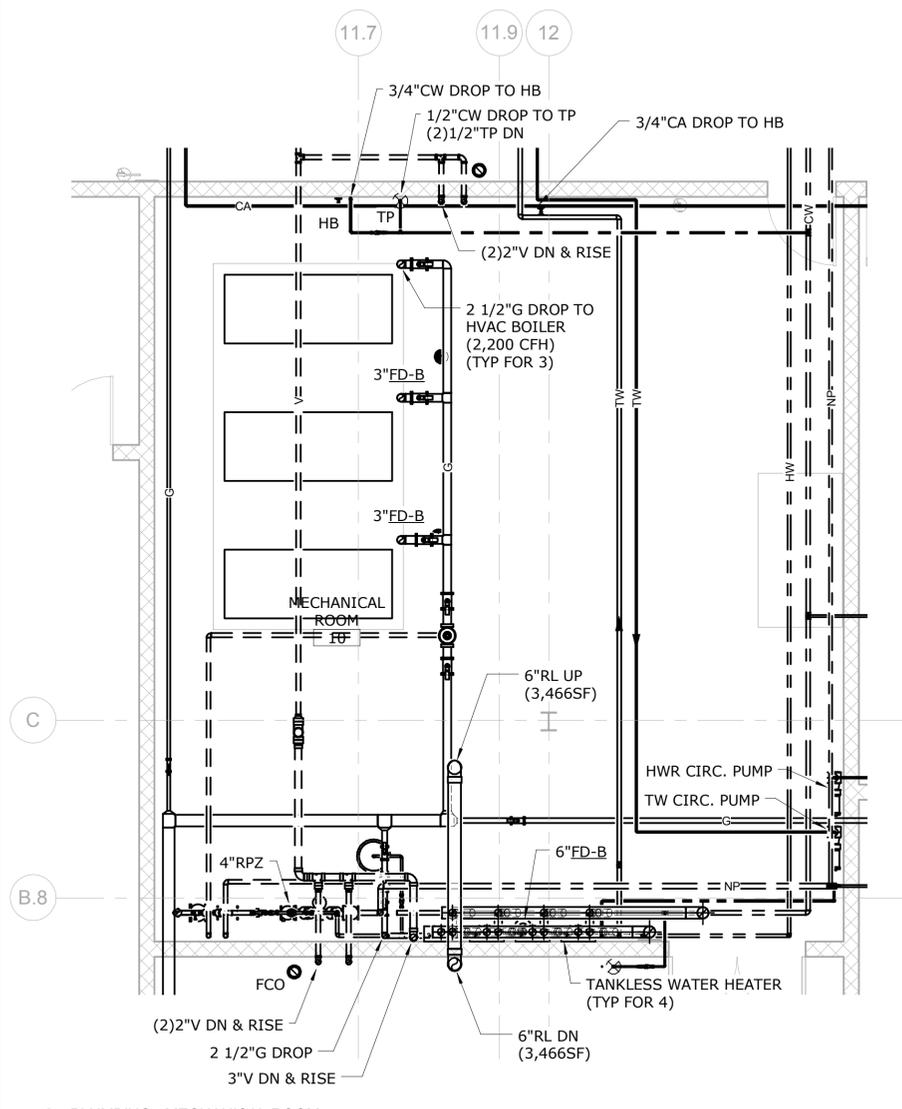

1 PLUMBING - MECHANICAL ROOM
SCALE: 1/4" = 1'-0"

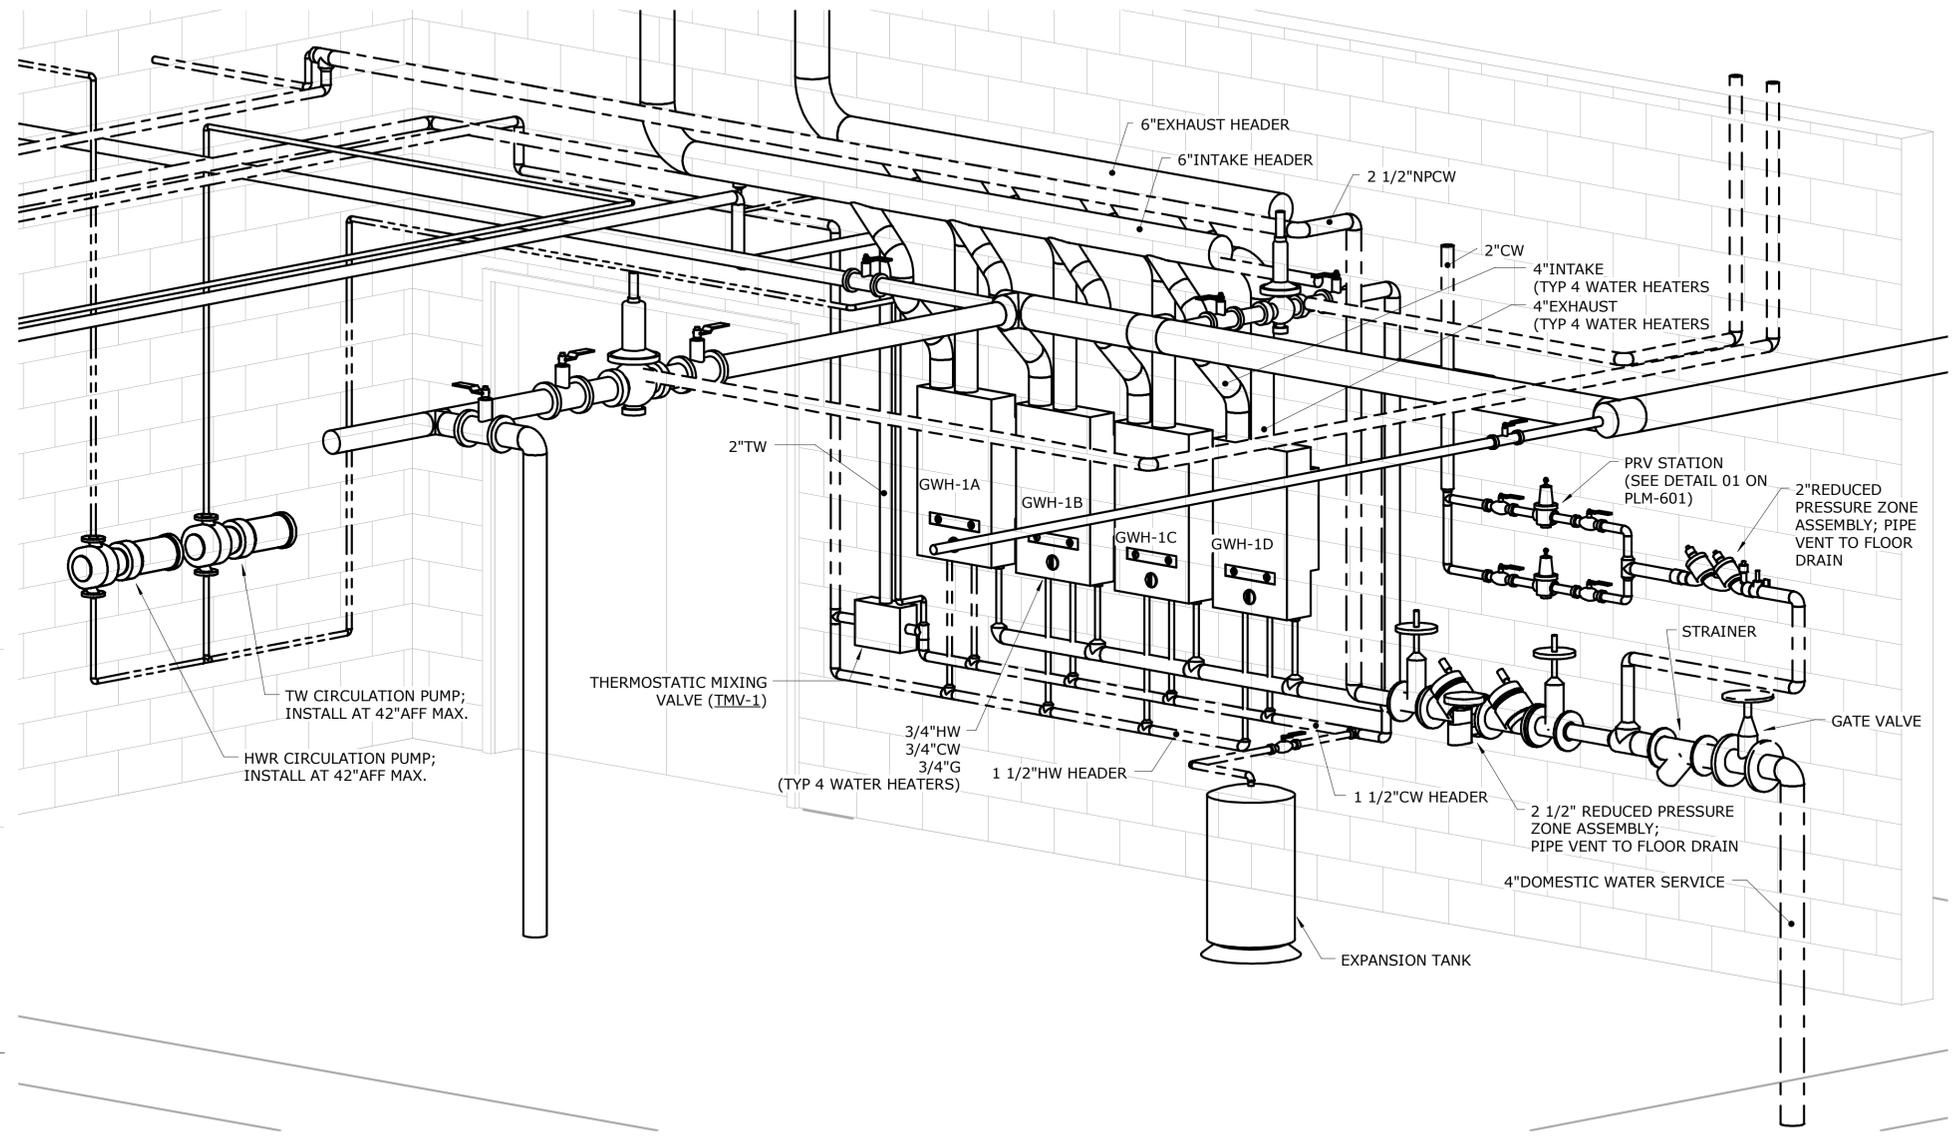

2 WATER SERVICE ISOMETRIC VIEW
SCALE:

NO.	Revision Description	Date

THE INFORMATION, INCLUDING ESTIMATED QUANTITIES OF WORK, SHOWN ON THESE SHEETS IS BASED ON LIMITED INVESTIGATIONS BY THE STATE AND IS IN NO WAY WARRANTED TO INDICATE THE CONDITIONS OF ACTUAL QUANTITIES OF WORK WHICH WILL BE REQUIRED.

Plotted: 10/21/2014 3:44:03 PM

DESIGNER/DRAFTER
RHL

CHECKED BY:
RSL

SCALE
AS NOTED



SIGNATURE/BLOCK:

PROJECT TITLE
REPAIR FACILITY


TOWN
ROCKY HILL

DRAWING TITLE
PLUMBING PART PLANS


PROJECT NO.
118-0167

DRAWING NO.
PLM-800


SHEET NO.
09.45

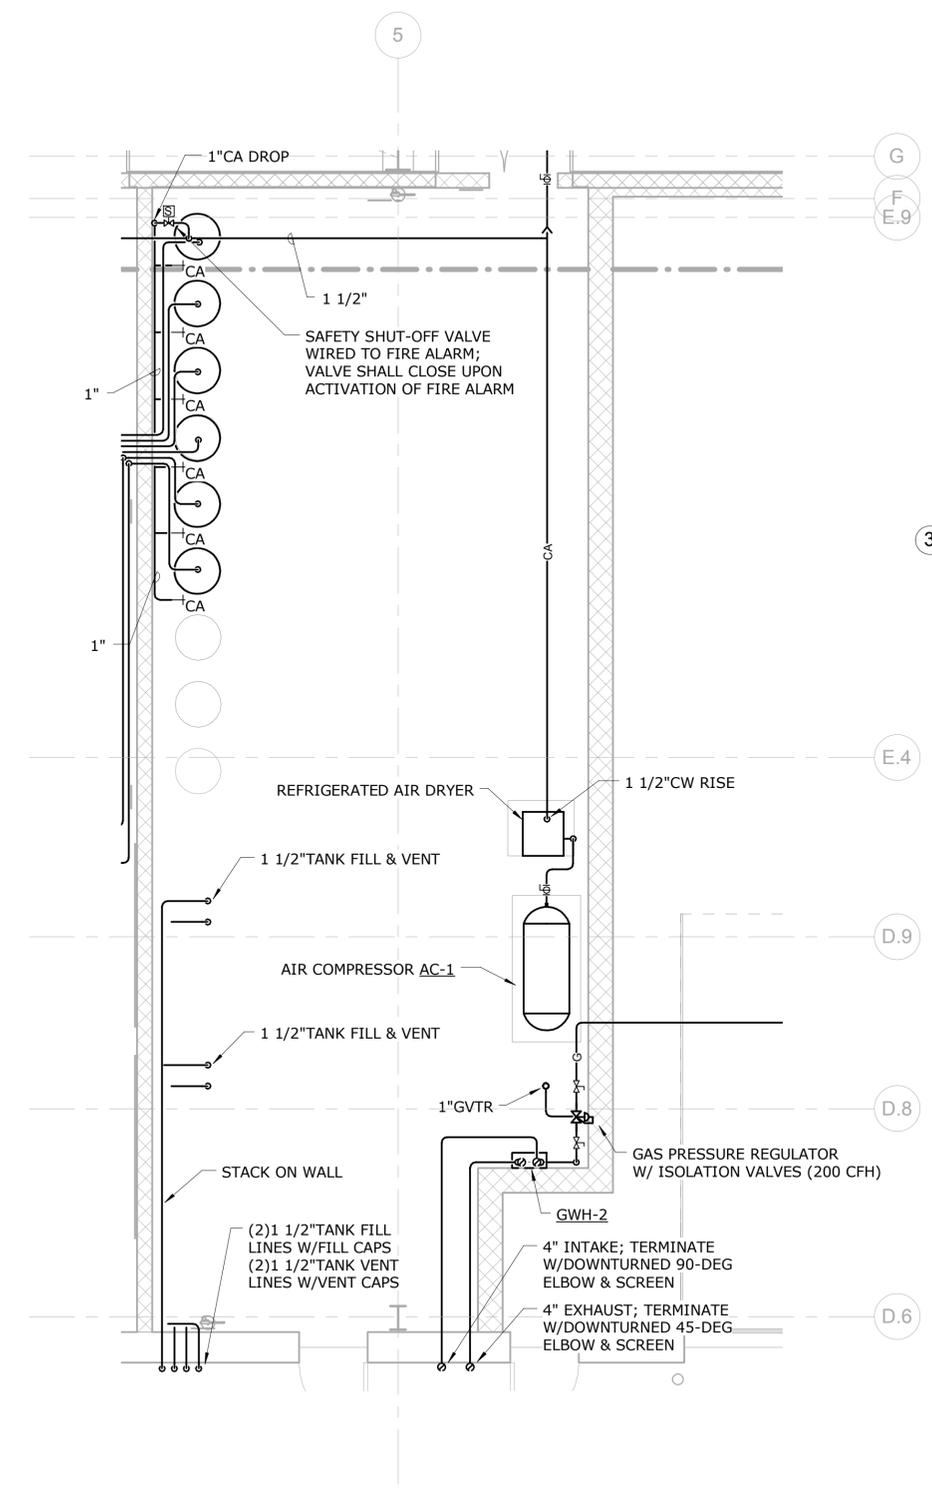

1 PLUMBING - LUBRICANT STORAGE ROOM
SCALE: 1/4" = 1'-0"

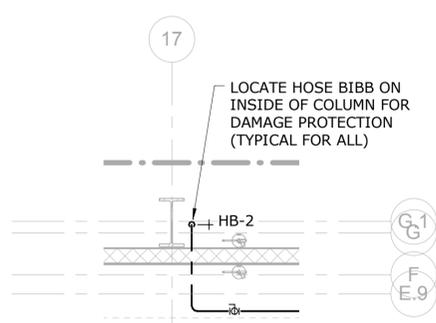

3 HOSE BIBB DETAIL
SCALE: 1/4" = 1'-0"

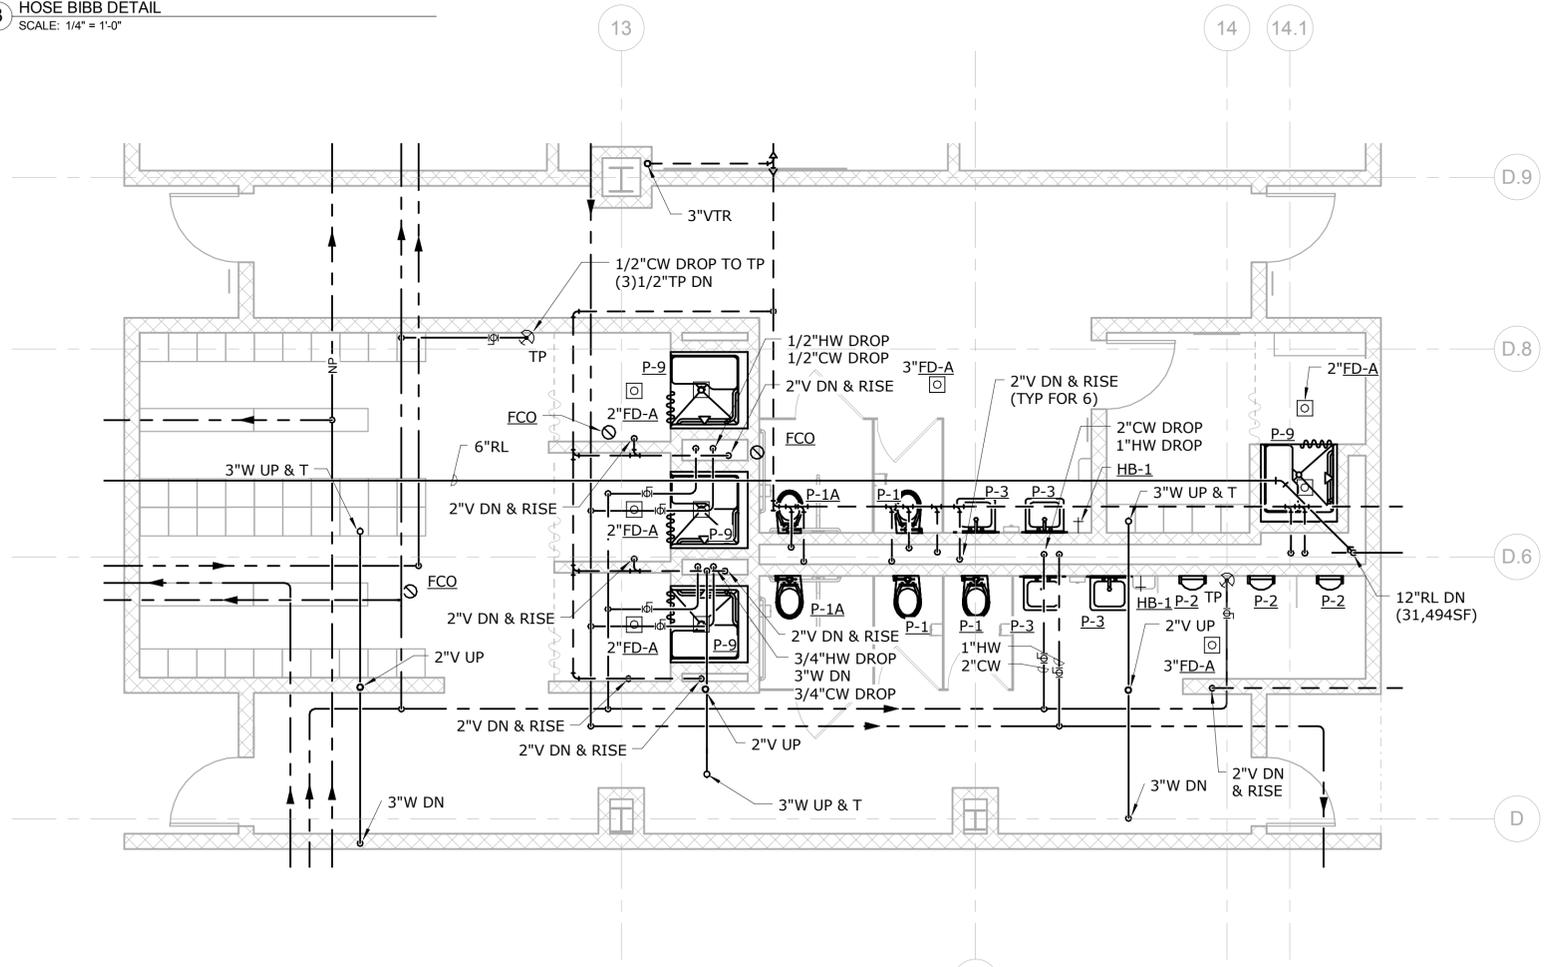

2 PLUMBING - TOILET ROOMS
SCALE: 1/4" = 1'-0"

NO.	Revision Description	Date

THE INFORMATION, INCLUDING ESTIMATED QUANTITIES OF WORK, SHOWN ON THESE SHEETS IS BASED ON LIMITED INVESTIGATIONS BY THE STATE AND IS IN NO WAY WARRANTED TO INDICATE THE CONDITIONS OF ACTUAL QUANTITIES OF WORK WHICH WILL BE REQUIRED.

DESIGNER/DRAFTER
RHL
CHECKED BY:
RSL
SCALE
1/4" = 1'-0"



SIGNATURE/BLOCK:
[Signature]

PROJECT TITLE
REPAIR FACILITY

TOWN
ROCKY HILL
DRAWING TITLE
PLUMBING PART PLANS

PROJECT NO.
118-0167
DRAWING NO.
PLM-801
SHEET NO.
09.46